




03 FRONT ELEVATION
SCALE: 1:100

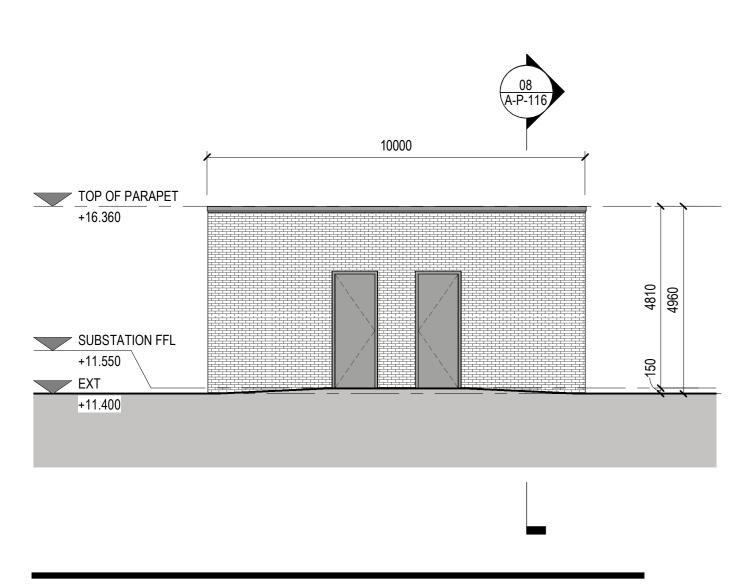


06 REAR ELEVATION SCALE: 1:100

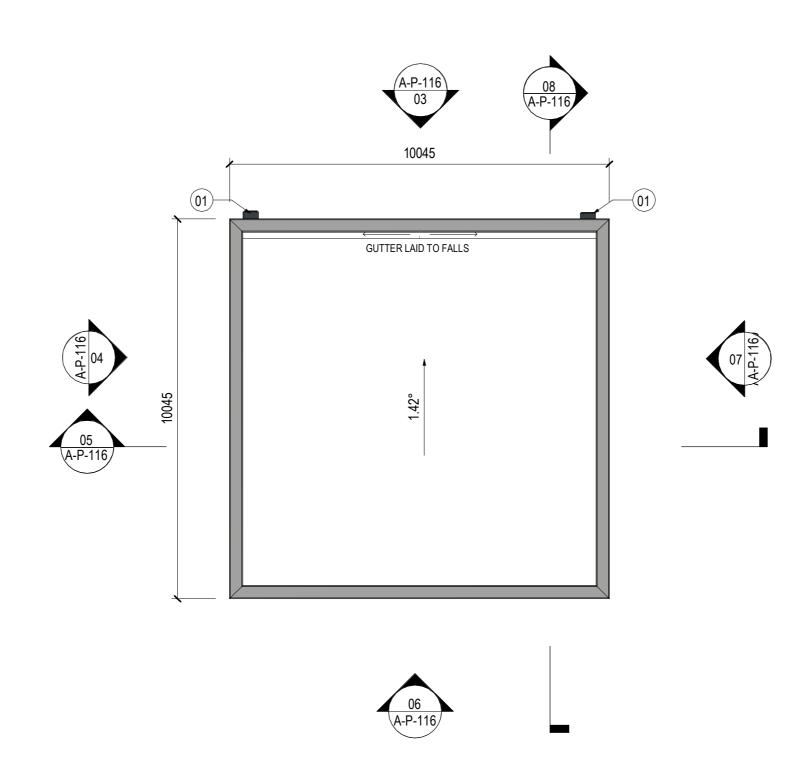


02 SUBSTATION ROOF PLAN SCALE: 1:100

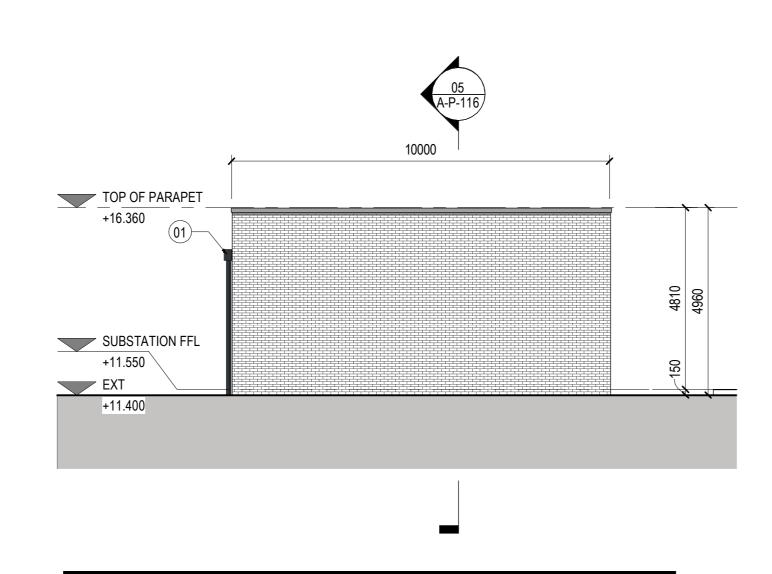


04 RIGHT ELEVATION SCALE: 1:100

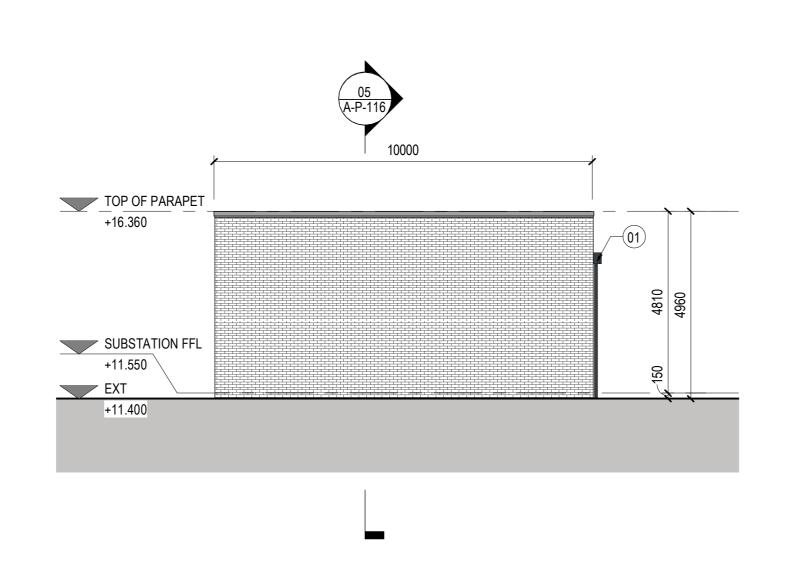


07 LEFT ELEVATION SCALE: 1:100

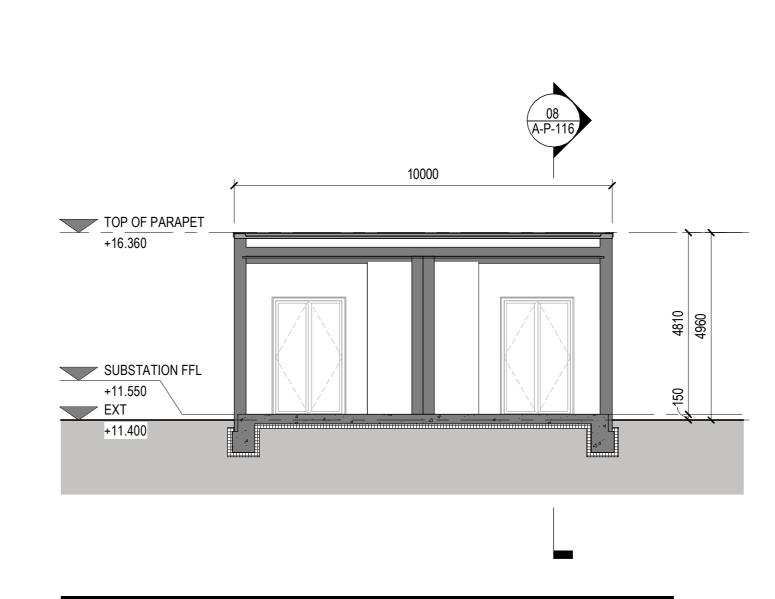

05 SECTION A SCALE: 1:100

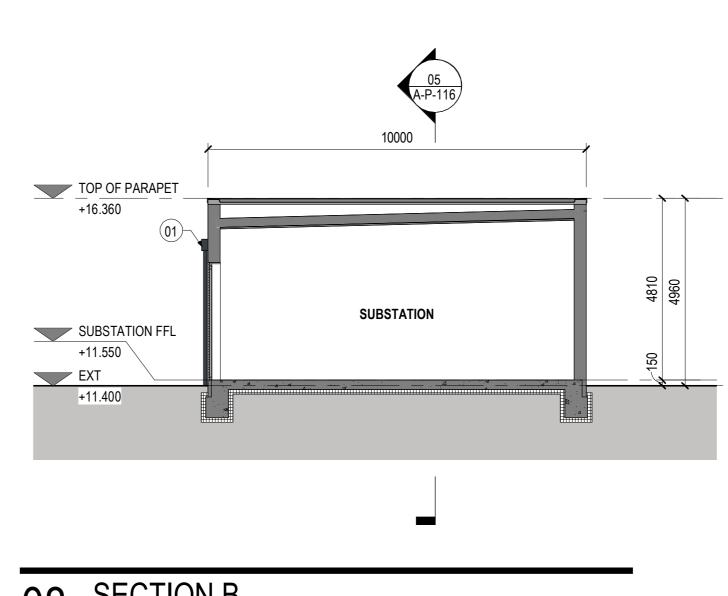

08 SECTION B SCALE: 1:100

 

SHEET NOTES

ALL VERTICAL DIMENSIONS ARE RELATIVE TO ASSOCIATED BUILDING SLAB LEVEL.

DO NOT SCALE FROM DRAWINGS.
ALL DISCREPANCIES TO BE REPORTED TO GENSLER ARCHITECTS IMMEDIATELY. ALL DIMENSIONS TO BE VERIFIED BY CONTRACTOR ON SITE PRIOR TO ANY WORKS.

Bainton Road, Bucknell

Bicester OX27 7LT, UK

www.red-eng.com

t: +44-(1869)355600

e: oxfordcad@red-eng.com

f: +44-(1869)250777

4 St Philip's Place First Floor Birmingham B3 2SL United Kingdom

Tel. +44 (0)121 260 1600

CWL01-02

DUFFRYN LANE

NEWPORT NP10 8BE

Design Team

Approvals

SHARENDRA NAIDU / STUART MCKEOWN

MARK KELLY /PAUL BISHOP

PROJECT MANAGEMENT

CUSTOMER MICROSOFT

Microsoft Design Manager LEVI HOLLAND

Microsoft Electrical Engineer MARK GLEESON

Microsoft Bas/Epms Engineer ANDREW FREEZER

Microsoft Mechanical Engineer DAVID WEST

Security Manager DAVID BEADLE

Project Planner
Project Manager

Senior Project Manager

Development Manager

Quality Control Reviewer

Quality Control FF&E

 No.
 Date
 Description

 P01
 27.10.23
 PLANNING

Project Manager

Company Project No. 026.1087.000

M.S. Project No. P.020340

FOR STRUCTURE REFER TO STRUCTURAL ENGINEERS' DRAWINGS AND SPECIFICATION SPRINKLER TANK BY SPECIALIST DESIGN.

IN GENERAL: CONCRETE FOUNDATIONS WITH STEEL STRUCTURE.

ALL EXPOSED STEEL STRUCTURES TO BE

GALVANIZED AND POWDER COATED, UNLESS SPECIFICALLY STATED OTHERWISE.

GENERAL CONTRACTOR TO CONFIRM LEVELS WITH A/E DESIGN TEAM PRIOR TO START CONSTRUCTION.

COLOURS AND MATERIALS

WALLS: GREY COMMON FACING BRICK TO MAIN WALLS

DOORS: STEEL, RAL 9006 (GREY ALUMINIUM)

FLASHINGS: STEEL, RAL 9006
(GREY ALUMINIUM)

ROOF DRAINS: COLLECTION BOX INTEGRATED WITH SCUPPER, RAL 7016

PLINTH: ENGINEERING BLUE BRICK PLINTH TO TOE BOARDS

ROOF: WARM ROOF BUILD-UP

(ANTHRACITE GREY)

Sheet notes

Number Description

01 PPC ROOF DRAINAGE AND SCUPPER, RAL 7016 (ANTHRACITE GREY)

LEGEND

DEPARTMENT LEGEND

TECHNICAL ROOM

Registration

CWL 01
SITE NORTH

Bar Code

Sheet Title/Number

SUBSTATION

CWL01-02-A-P-116

1:100@A0

© Gensler 2022
All rights reserved, including but not limited to The Copyright, Design and Patents Act 1988