


BUILDING 1803 REPAIR / REPLACE ROOF

DRAWING INDEX


SHT. REF. NO.	REVISION NO.	
GI-001		TITLE SHEET, LOCATION MAP AND DRAWING INDEX
A-100		ORIGINAL AS-BUILTS - ELEVATIONS
A-101		ORIGINAL AS-BUILTS - ROOF DETAILS
A-102		ORIGINAL AS-BUILTS - DETAILS

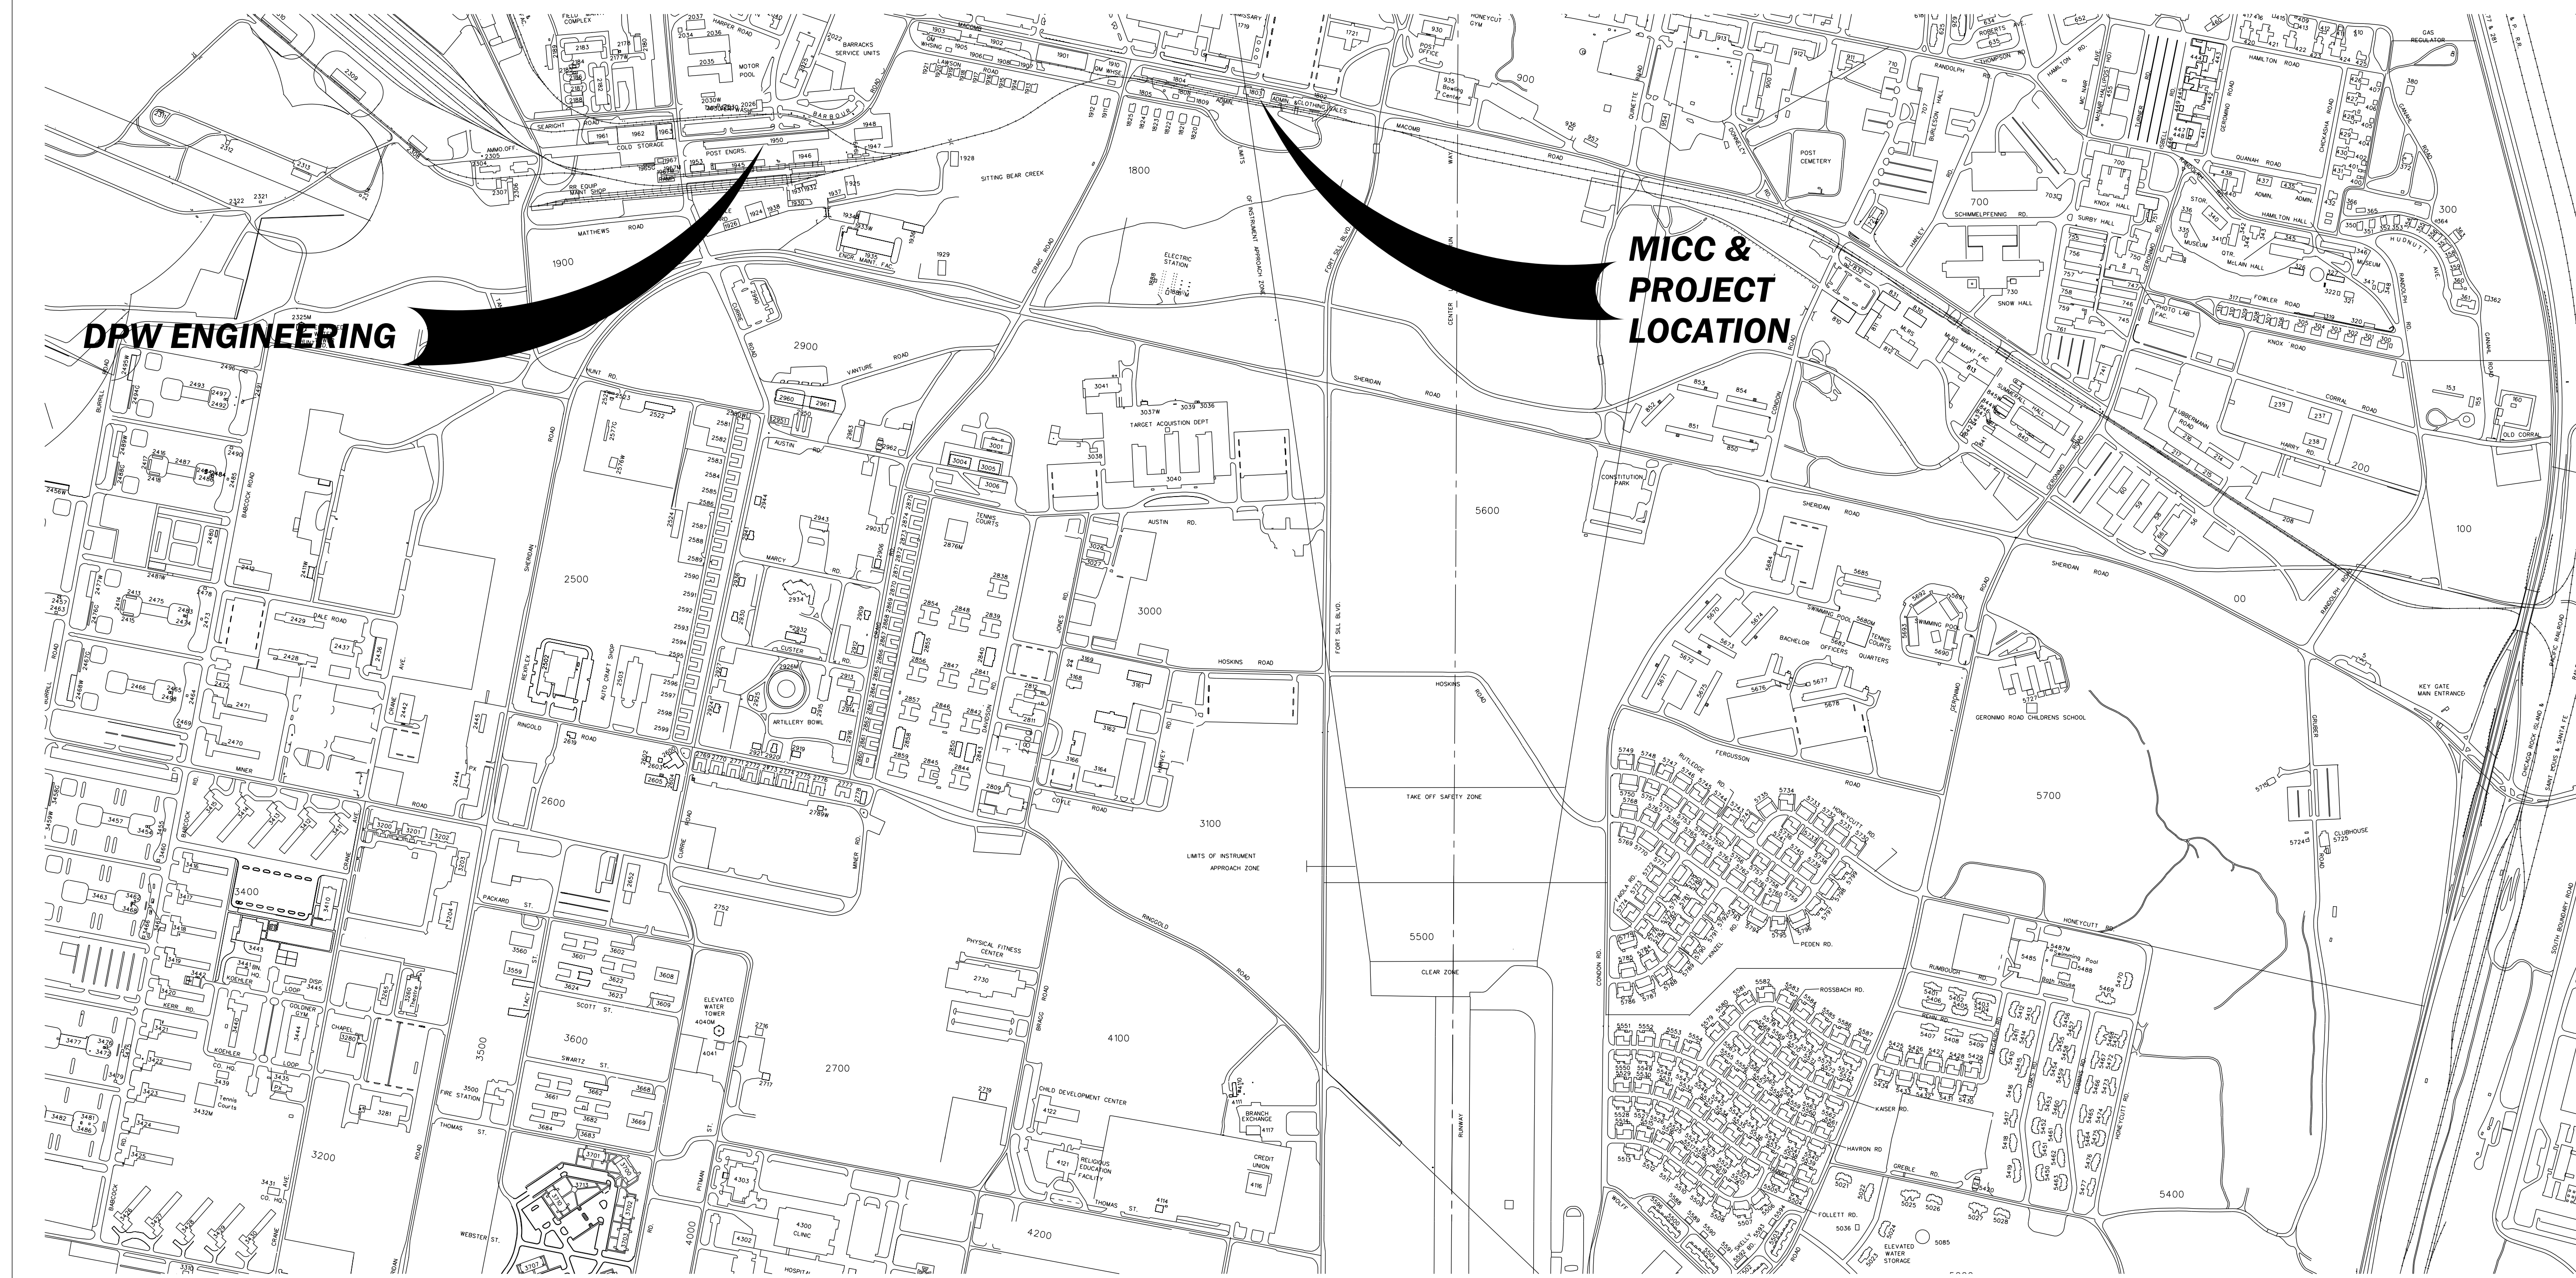


BUILDING 1803 REPAIR / REPLACE ROOF TITLE SHEET, LOCATION MAP AND DRAWING INDEX	PROJECT NO KK00940-9J	DATE JUNE 2019	DRAWN BY TLY	DESIGNED BY T. YOUNG
	DRAWING NO 19029 GI-001			

**DIRECTORATE
OF
PUBLIC WORKS**
FORT SILL, OKLAHOMA


Center of Excellence

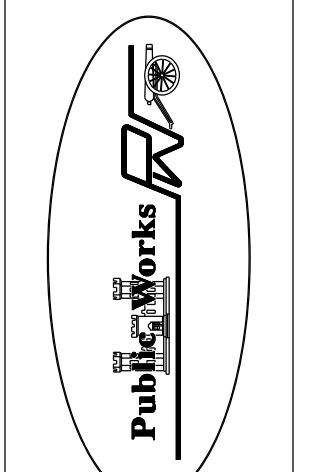


1.	4/9/2018	ADDED SHEET P-104, P-105, AND P-106.	TLY
REVISION	DATE	DESCRIPTION	BY
CHECKED BY	FIRE CH	CHIEF, ENGR DIV	

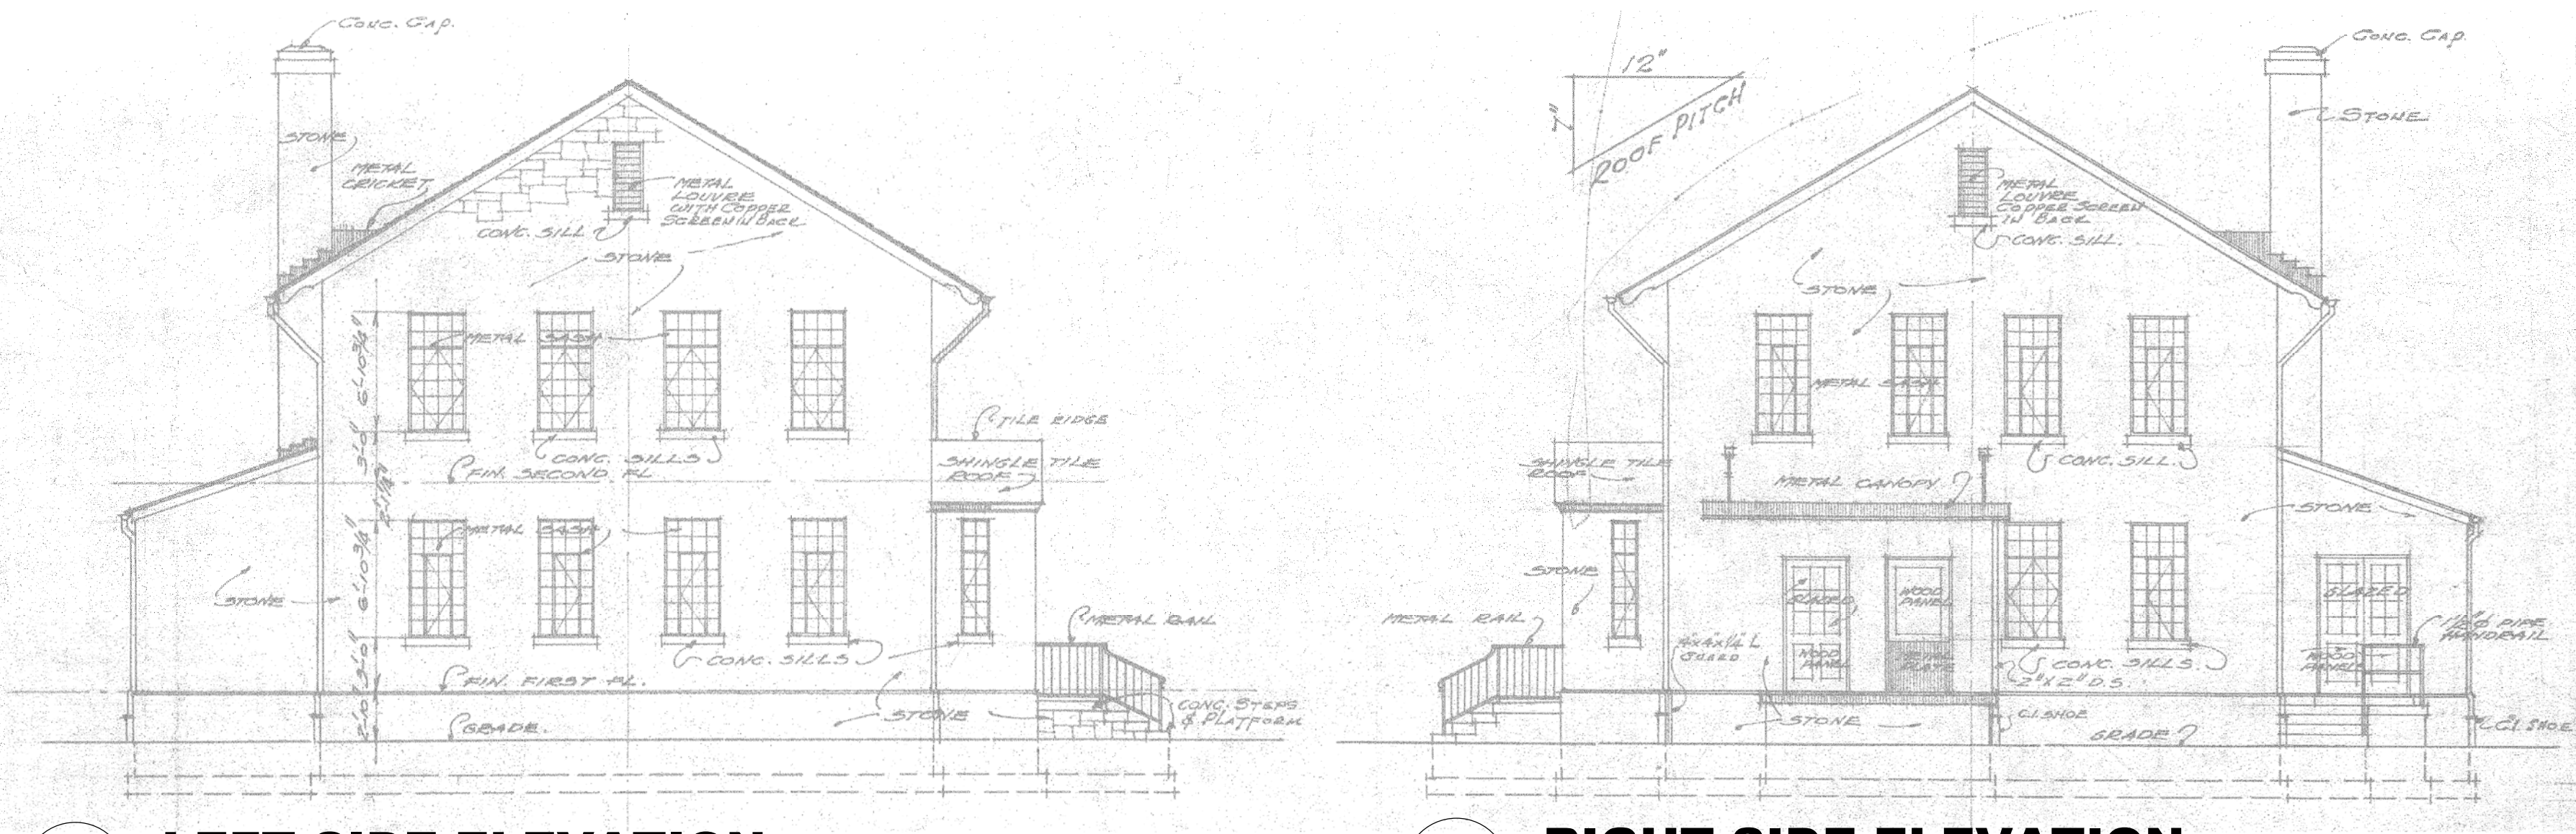


1 LEFT SIDE ELEVATION
SCALE: NOT TO SCALE


2 RIGHT SIDE ELEVATION
SCALE: NOT TO SCALE

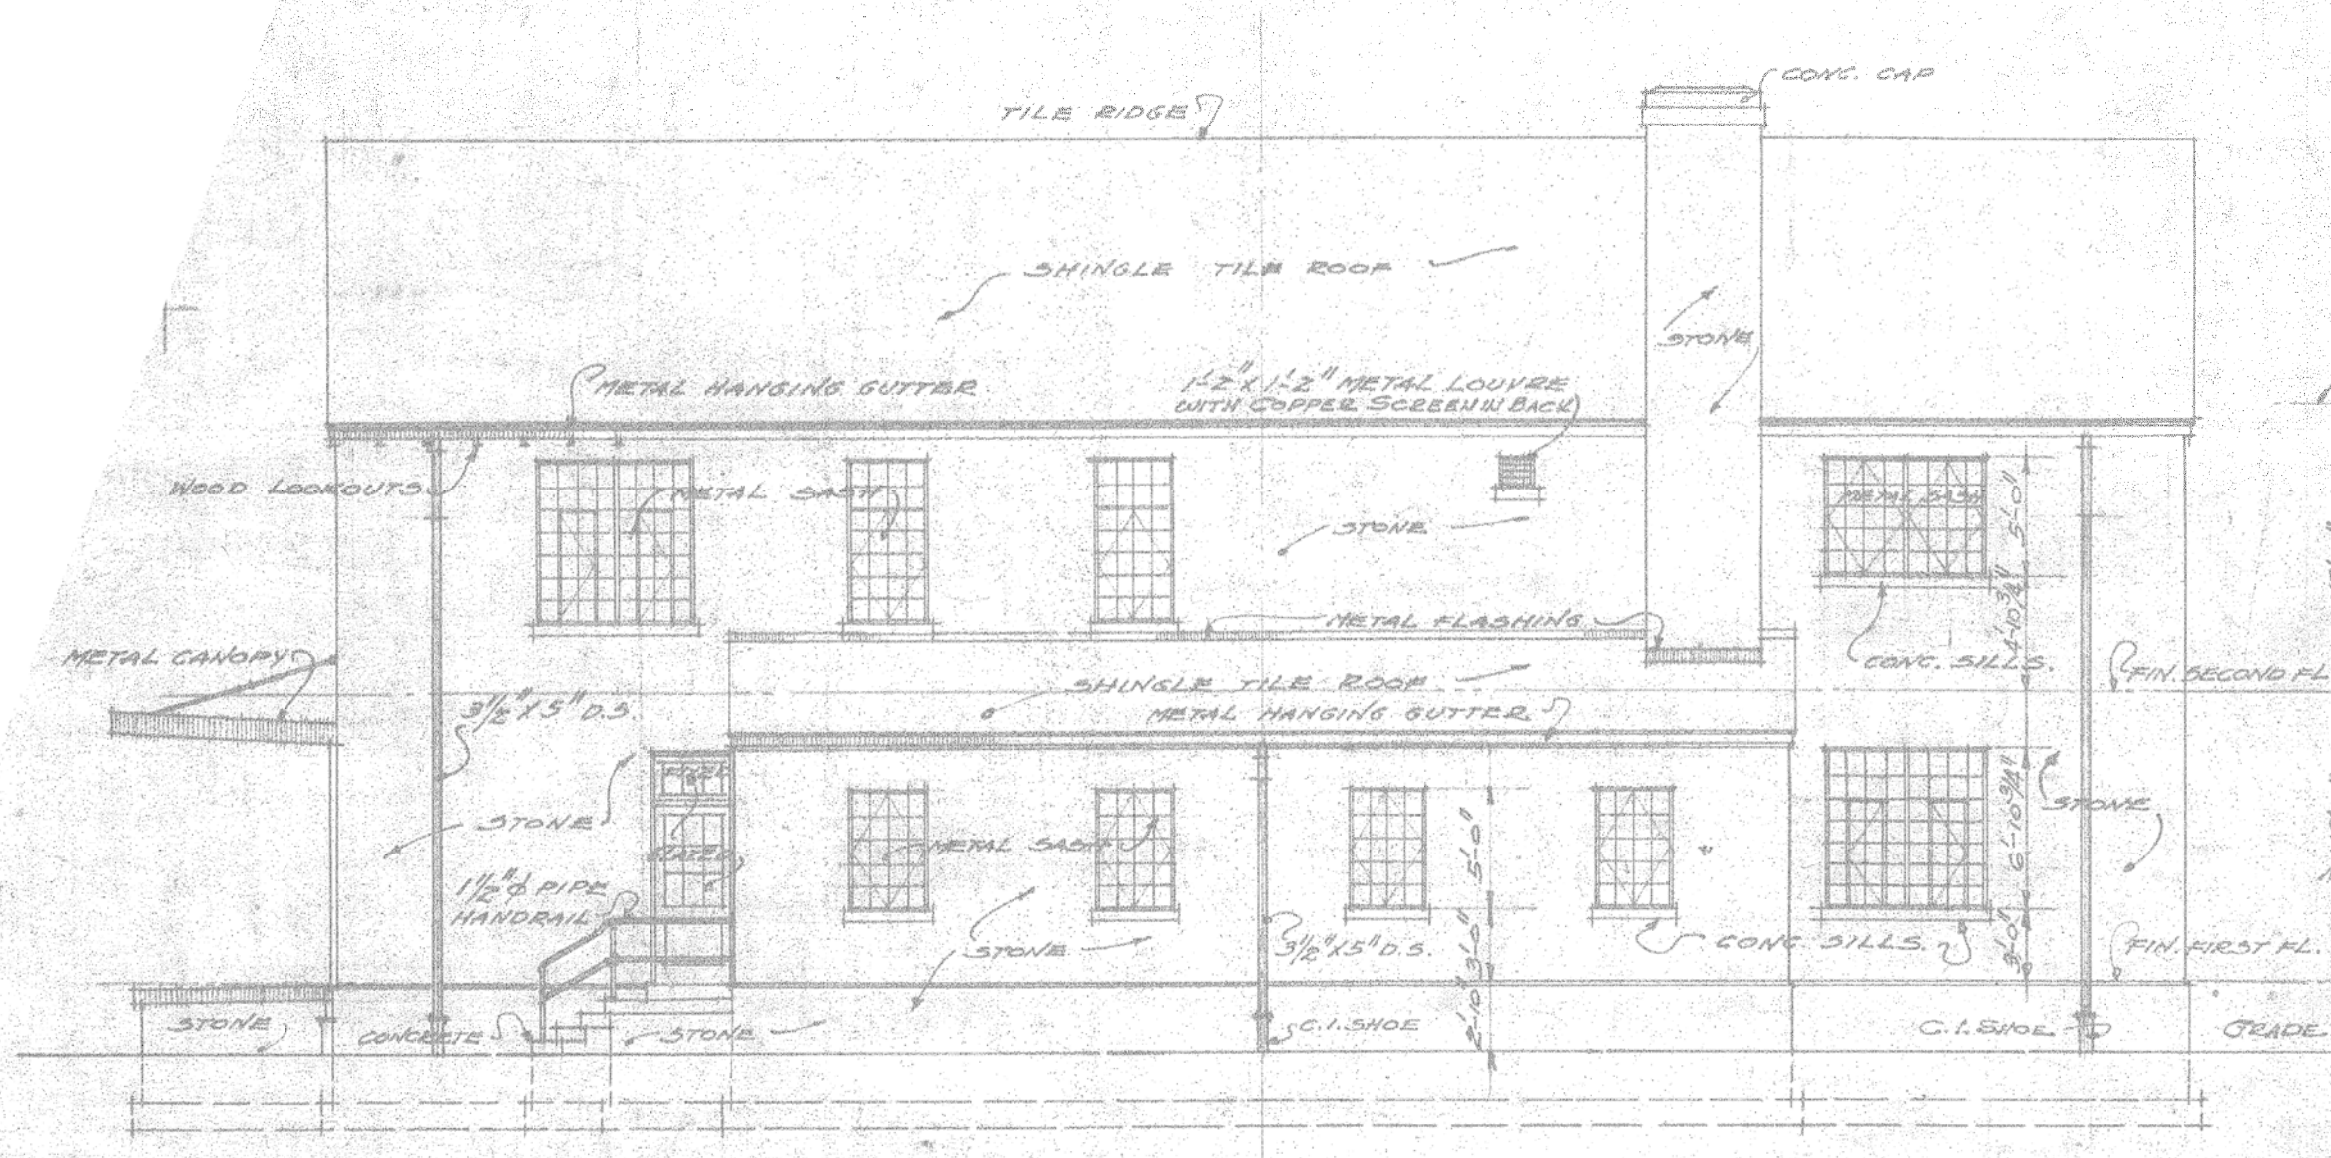


3 REAR ELEVATION
SCALE: NOT TO SCALE

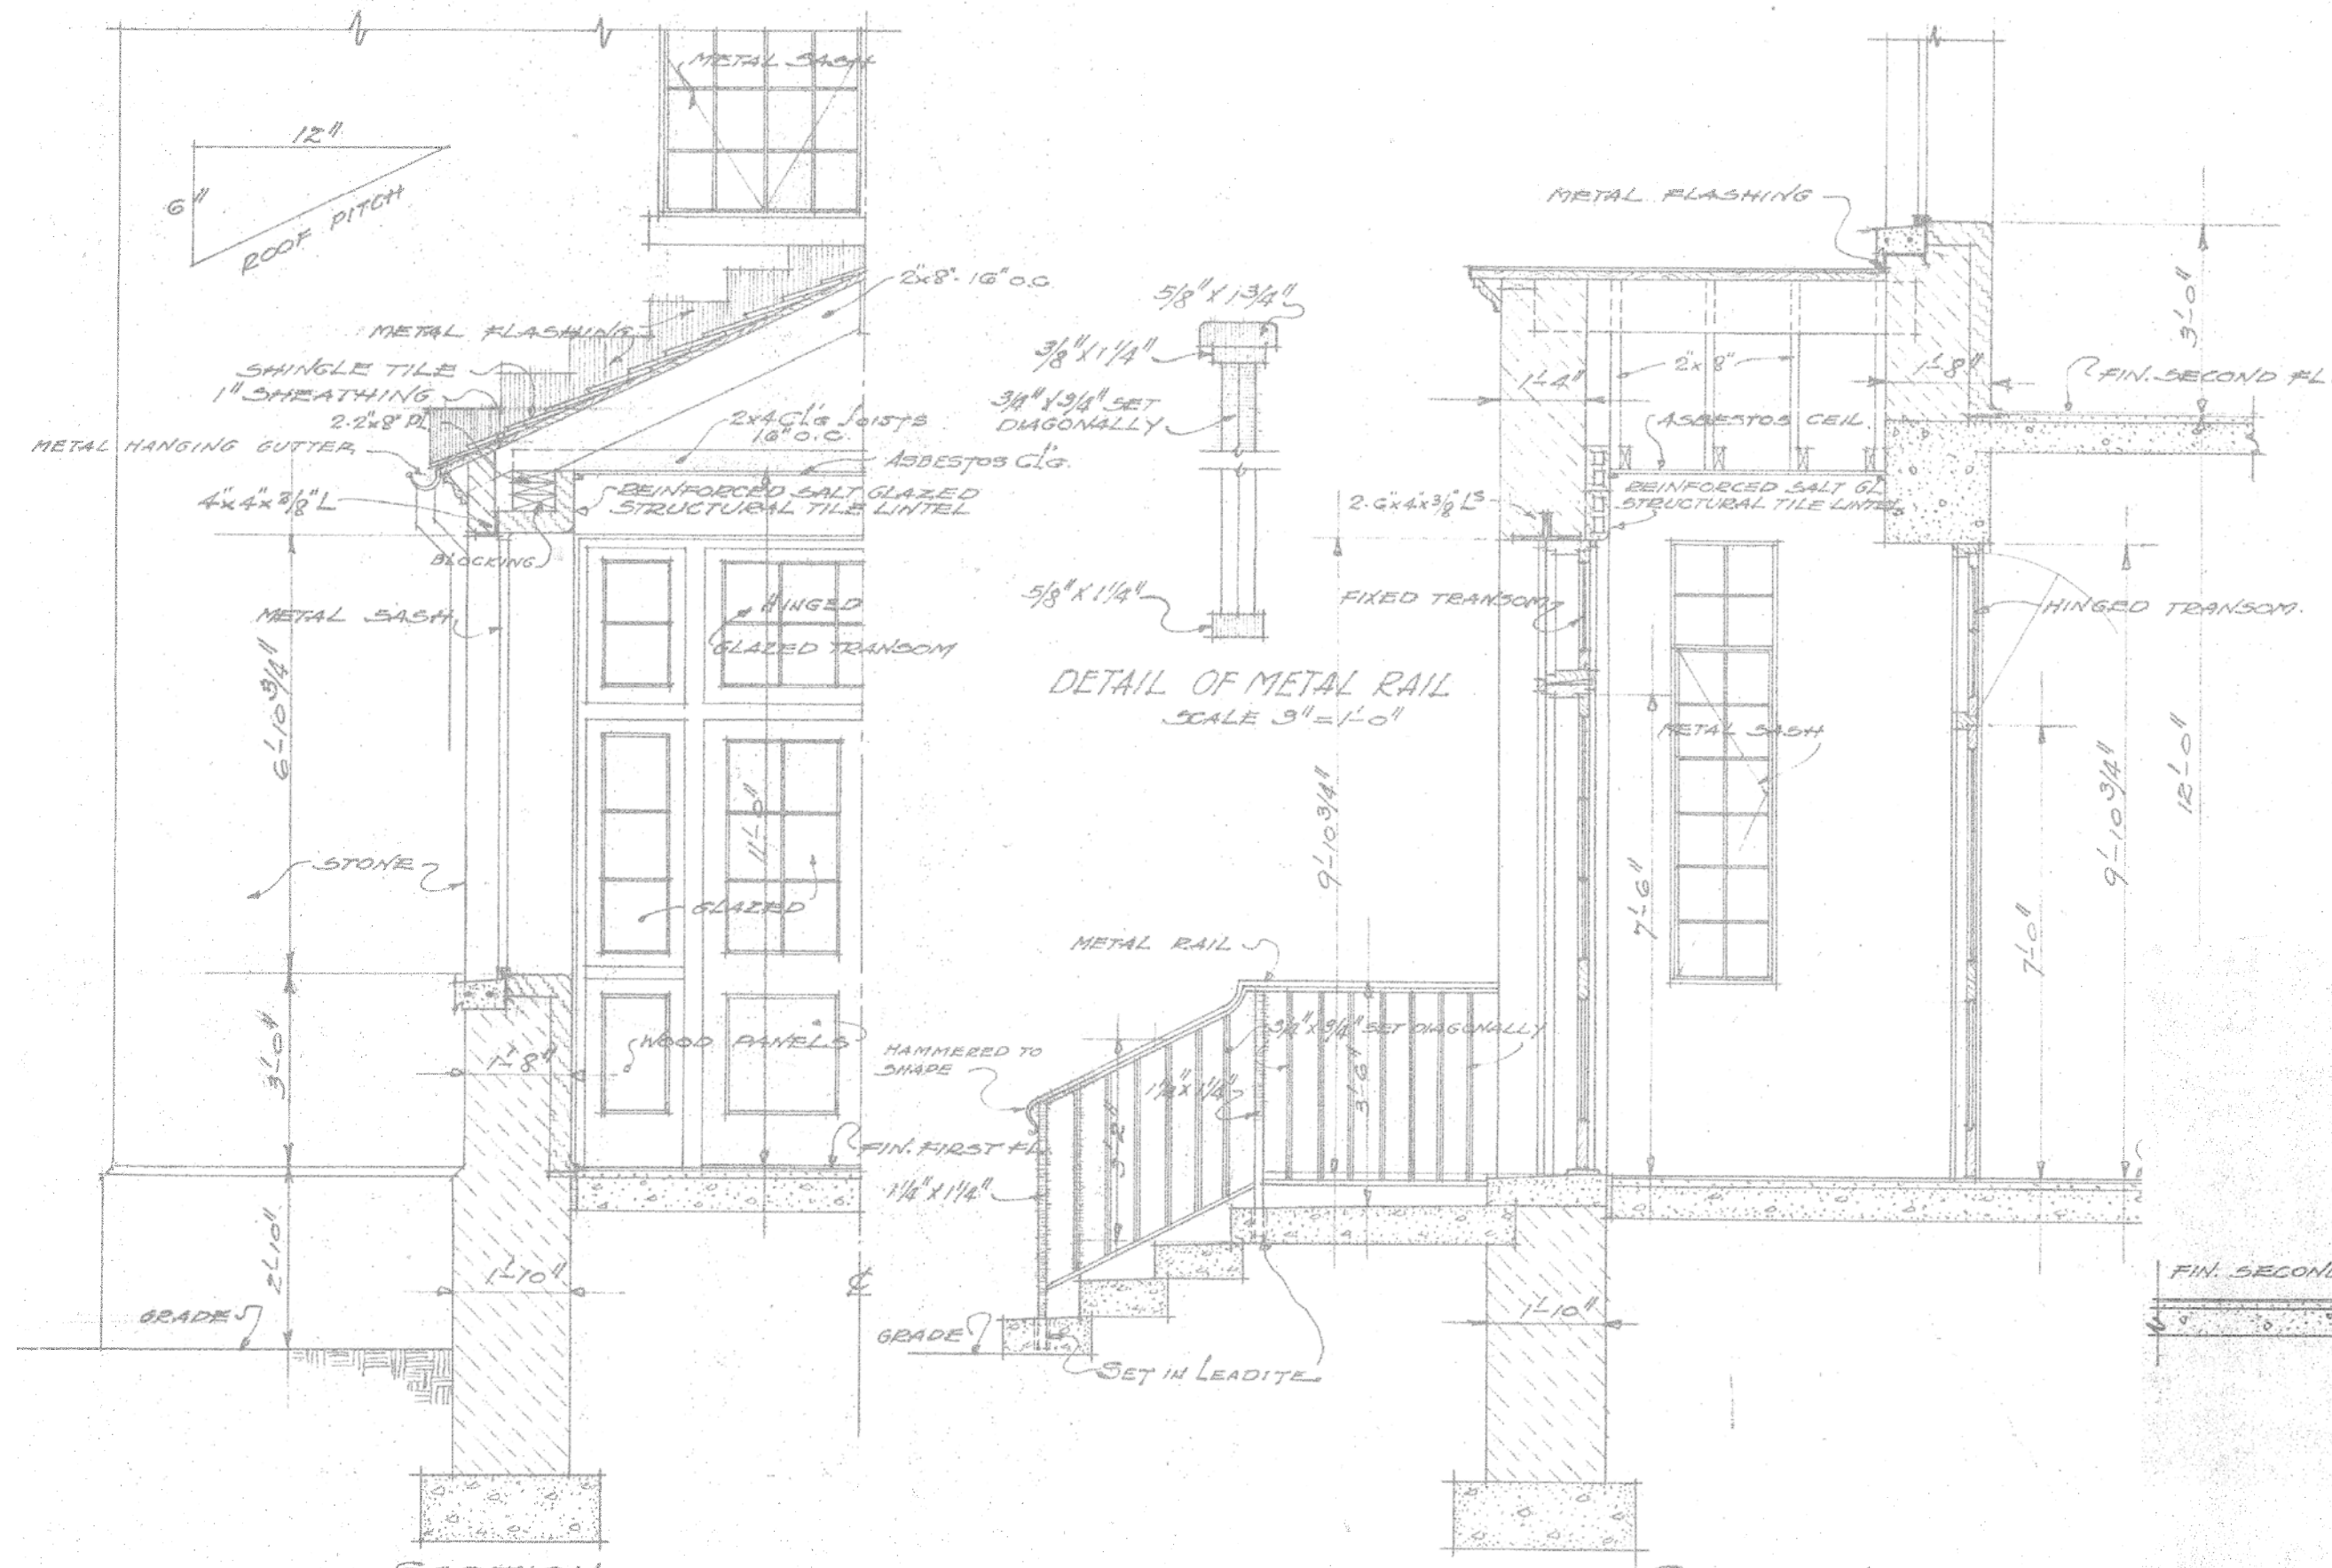


5 FRONT ENTRANCE DETAILED ELEVATION
SCALE: NOT TO SCALE

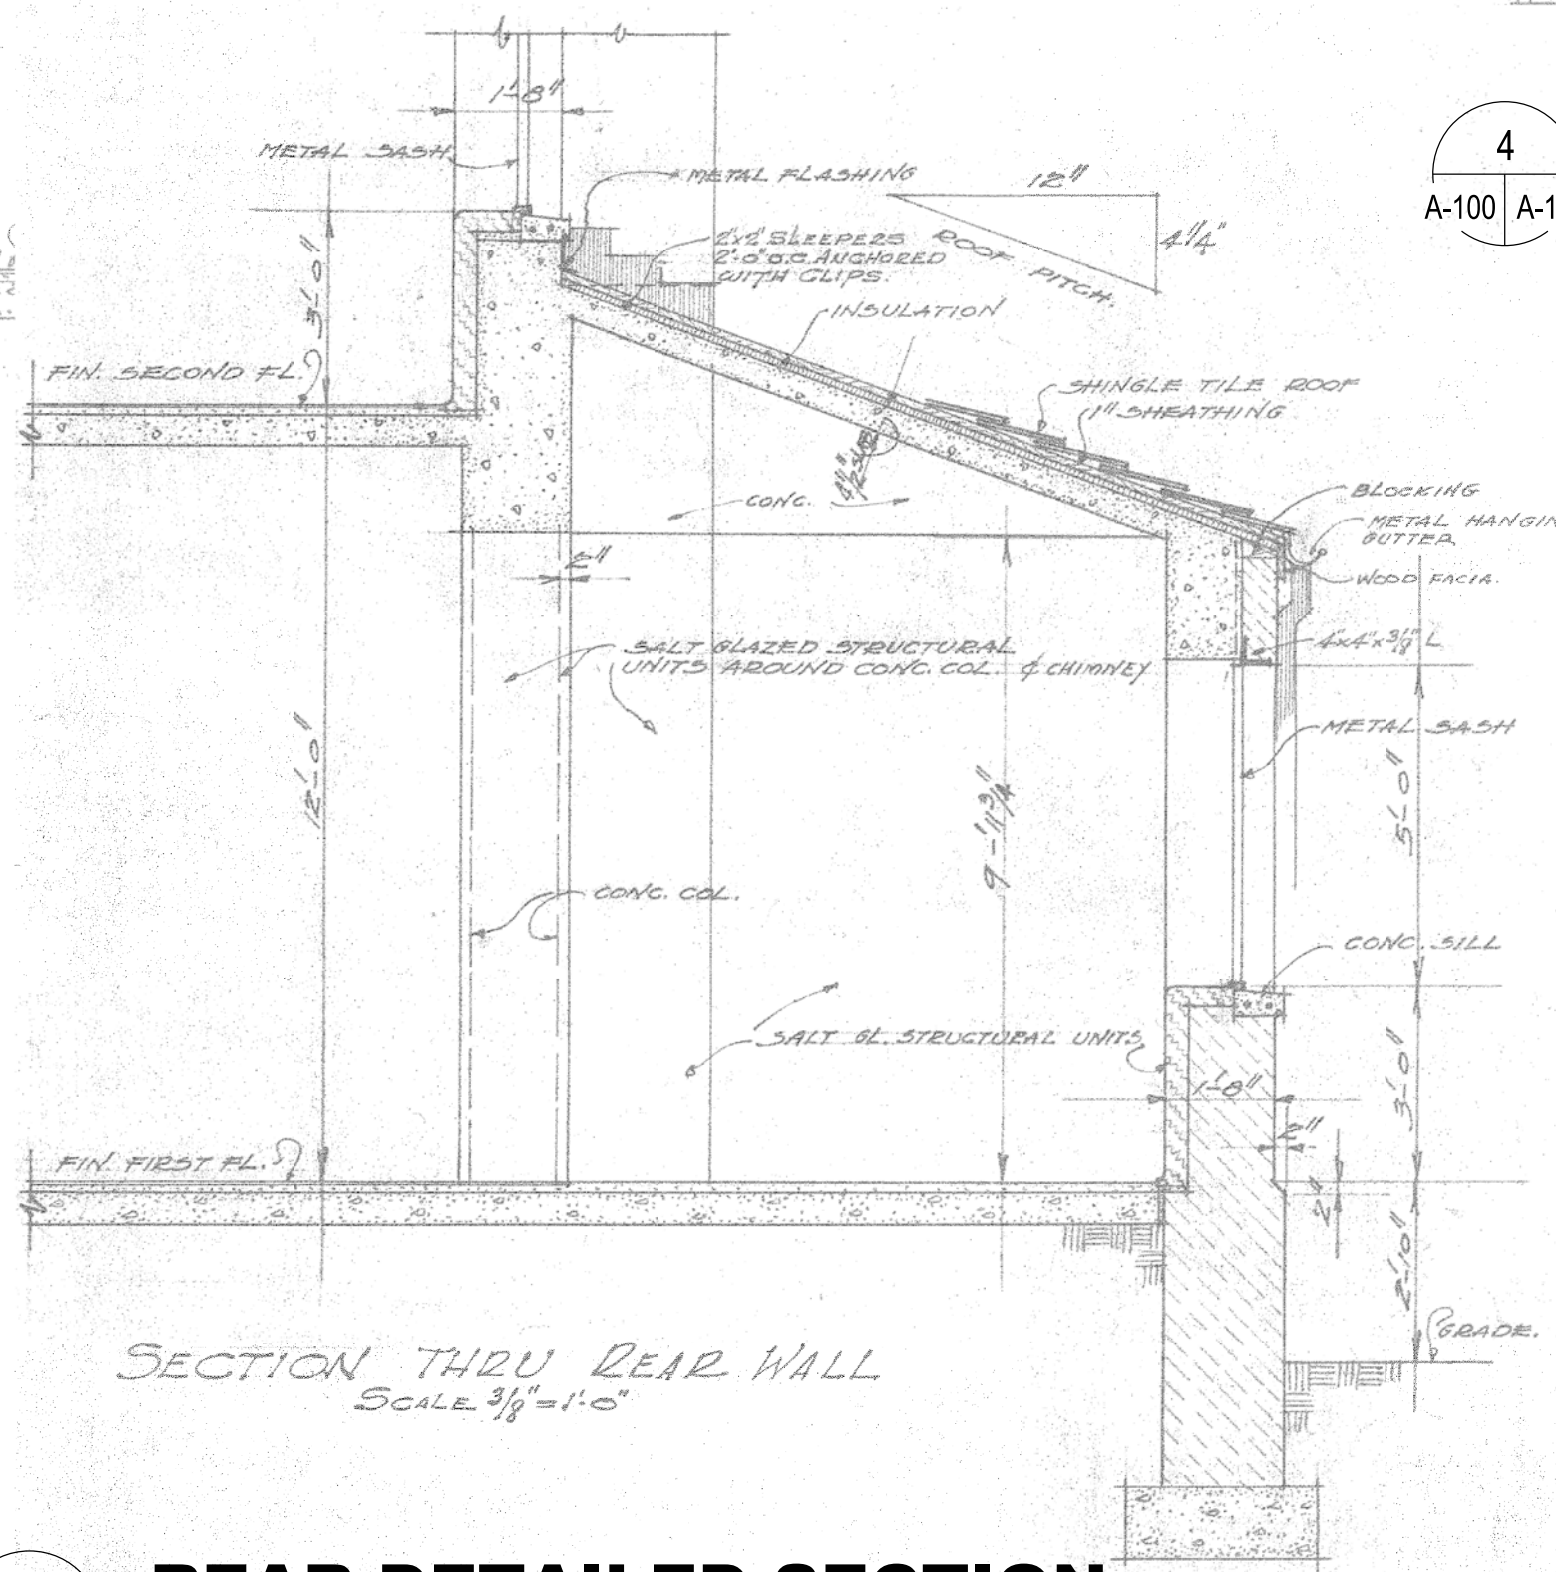

6 REAR DETAILED SECTION
SCALE: NOT TO SCALE

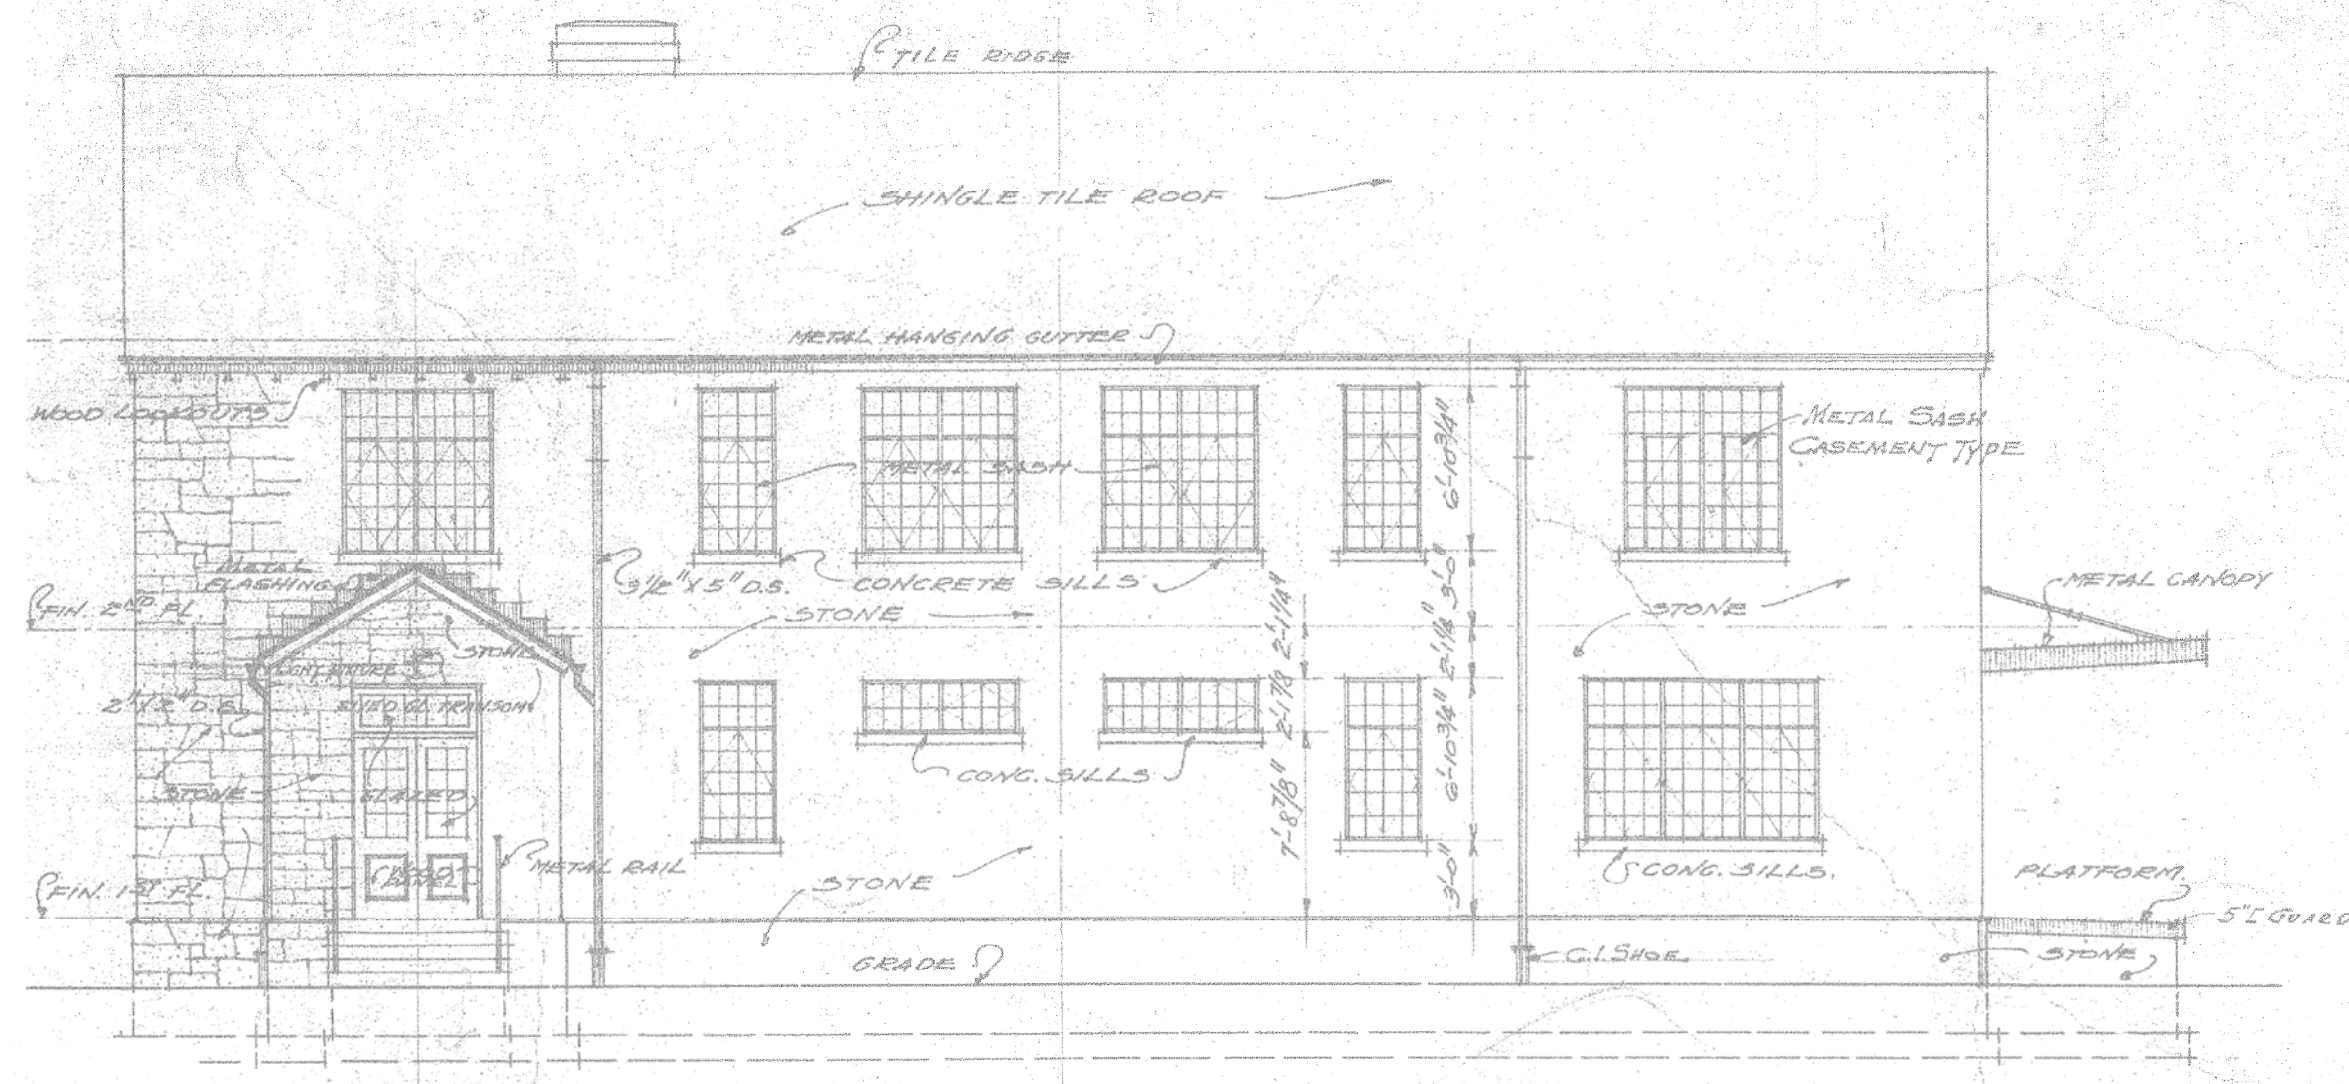

4 FRONT ELEVATION
SCALE: NOT TO SCALE

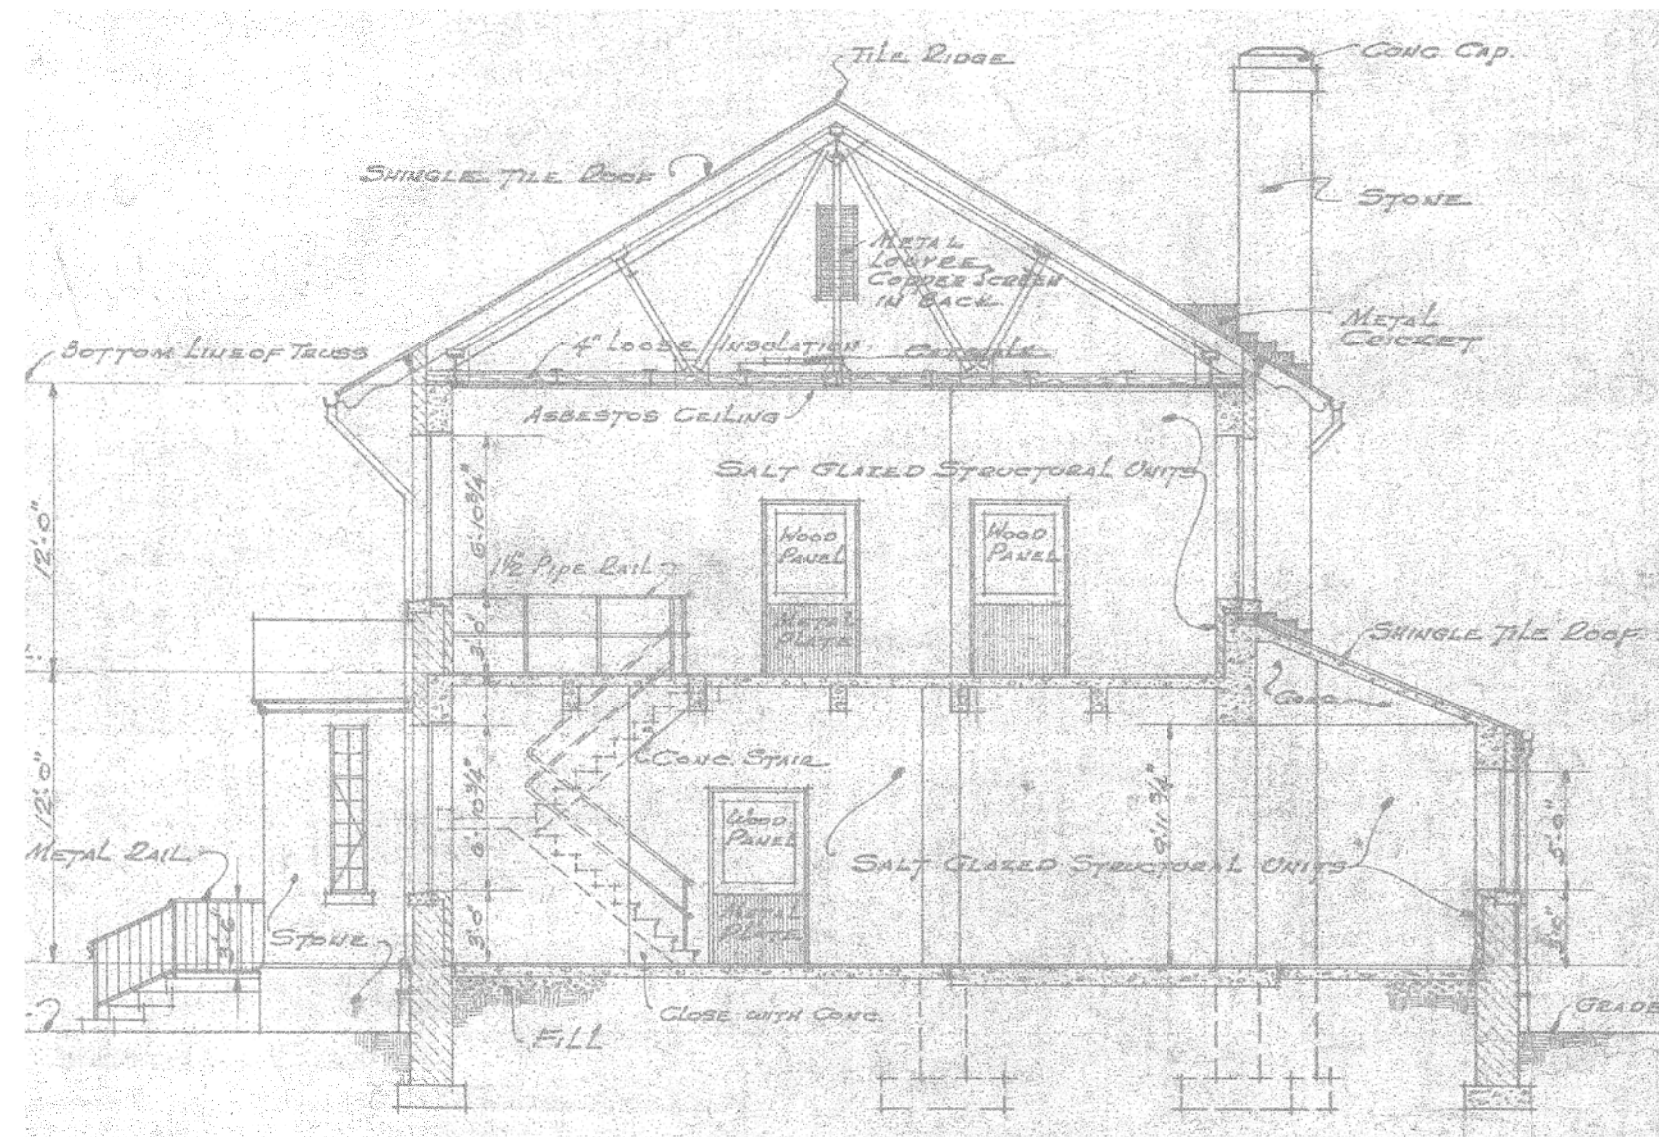

7 CROSS SECTION
SCALE: NOT TO SCALE

DRAWING NO 19029 A-100			BUILDING 1803 REPAIR / REPLACE ROOF ORIGINAL AS-BUILTS - ELEVATIONS											
PROJECT NO KK00940-9J	DATE JUNE 2019	DRAWN BY TLY	DESIGNED BY T. YOUNG											


Public Works

DIRECTORATE
OF
PUBLIC WORKS




FORT SILL, OKLAHOMA


Center of Excellence

FIRES

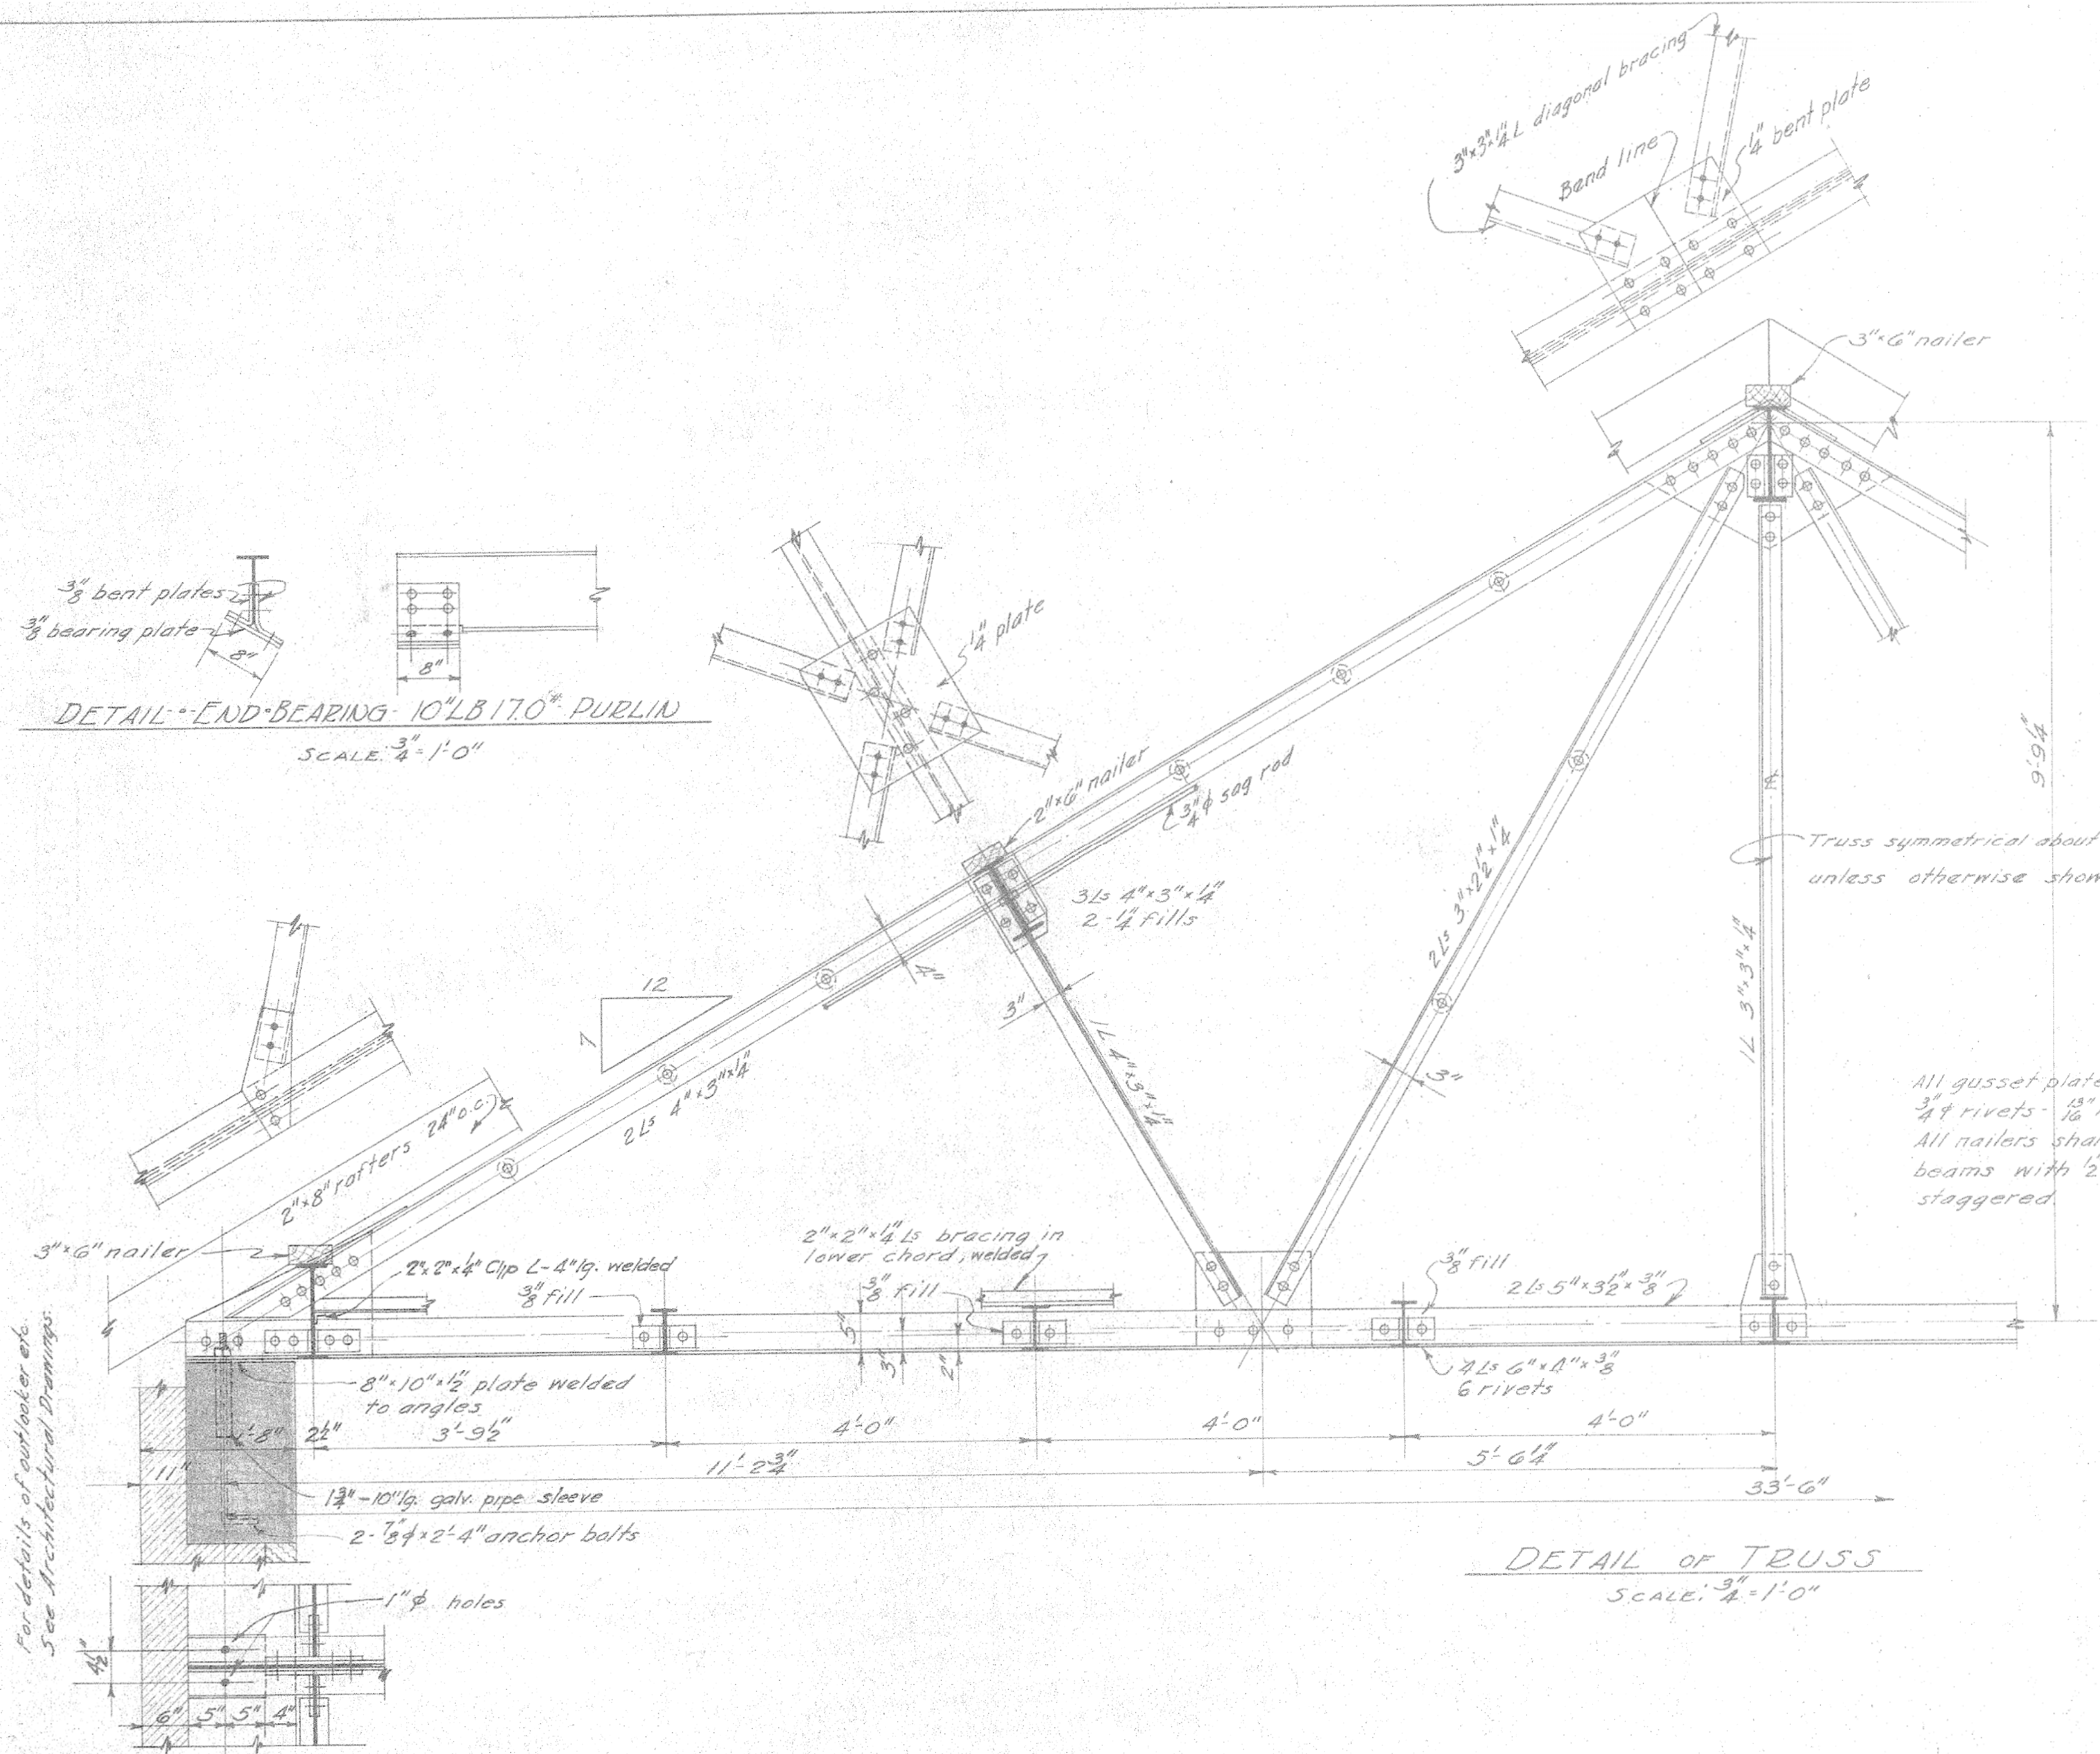

For details of end bearing, etc. See Architectural Drawings.

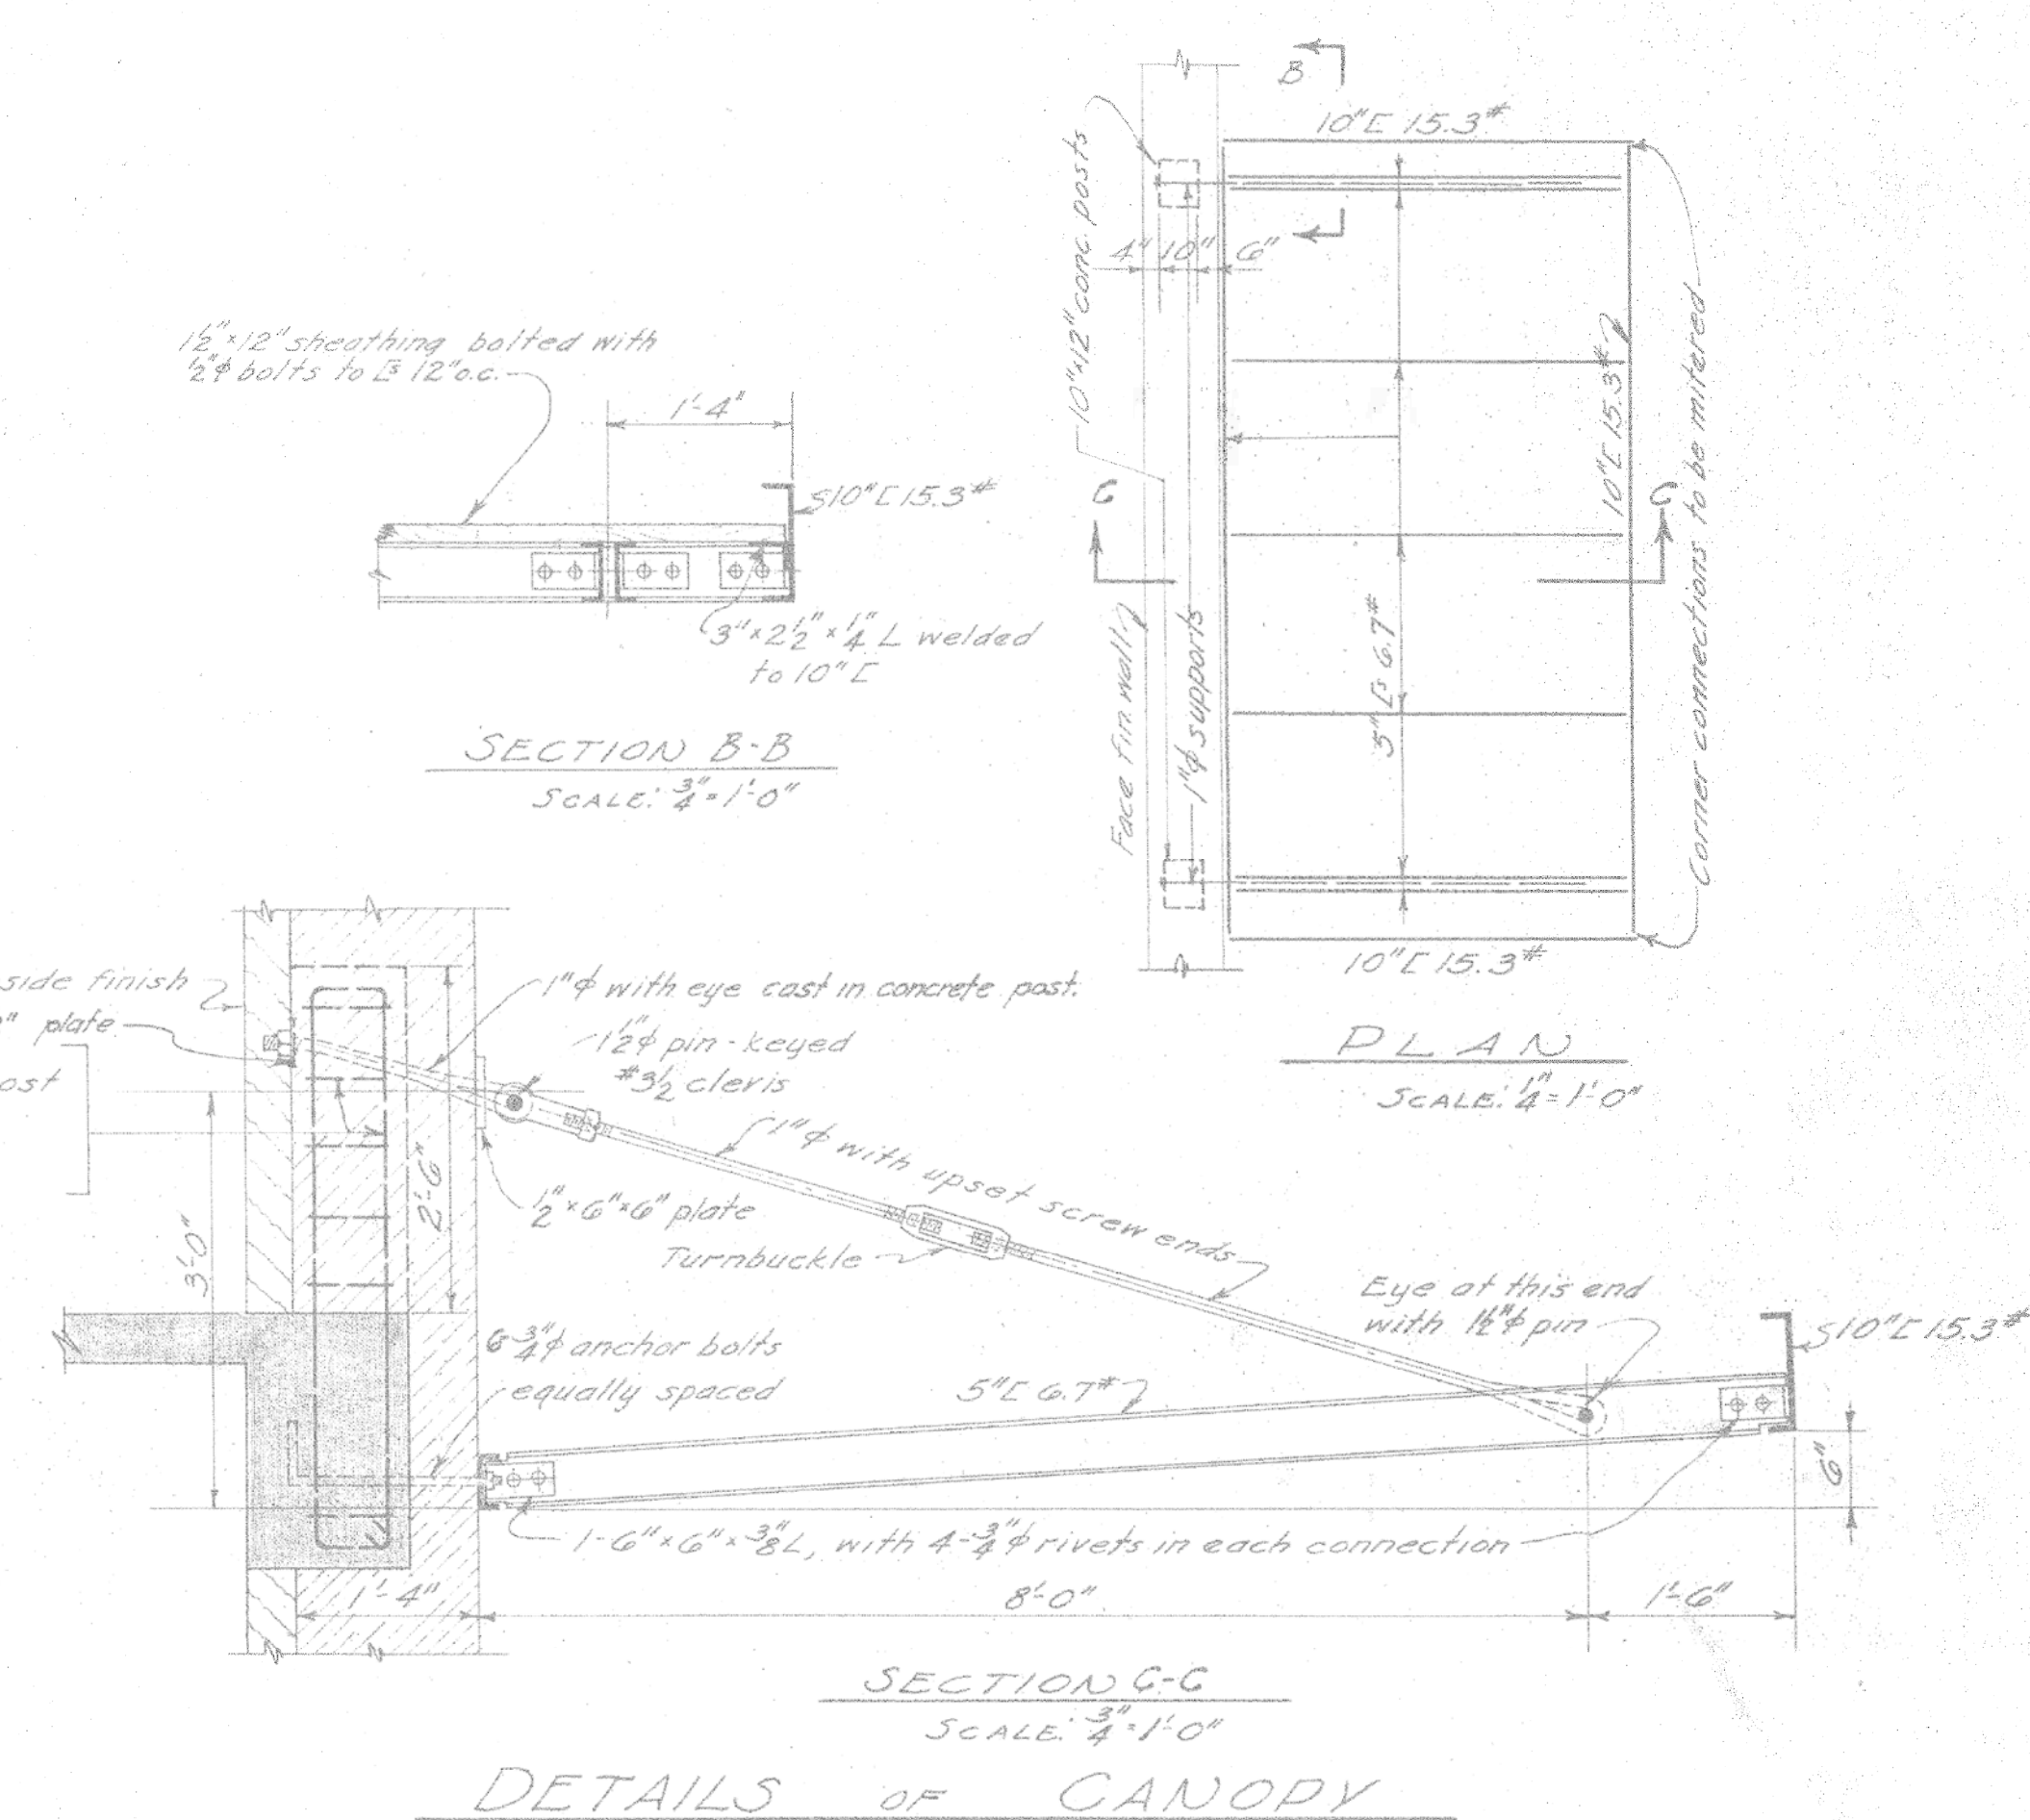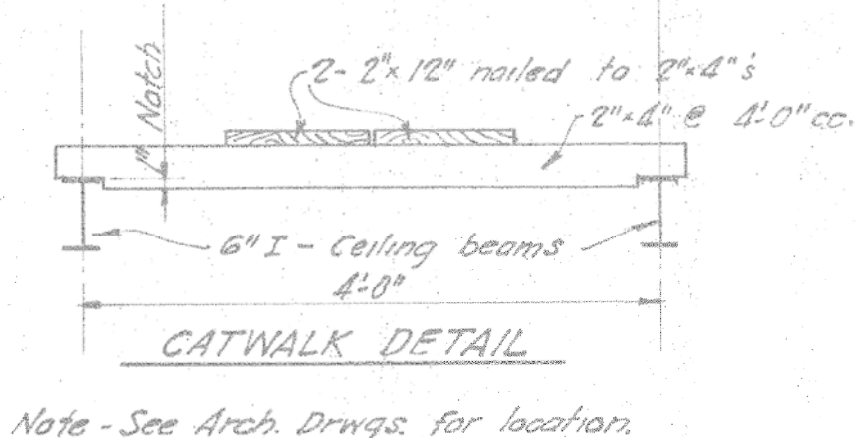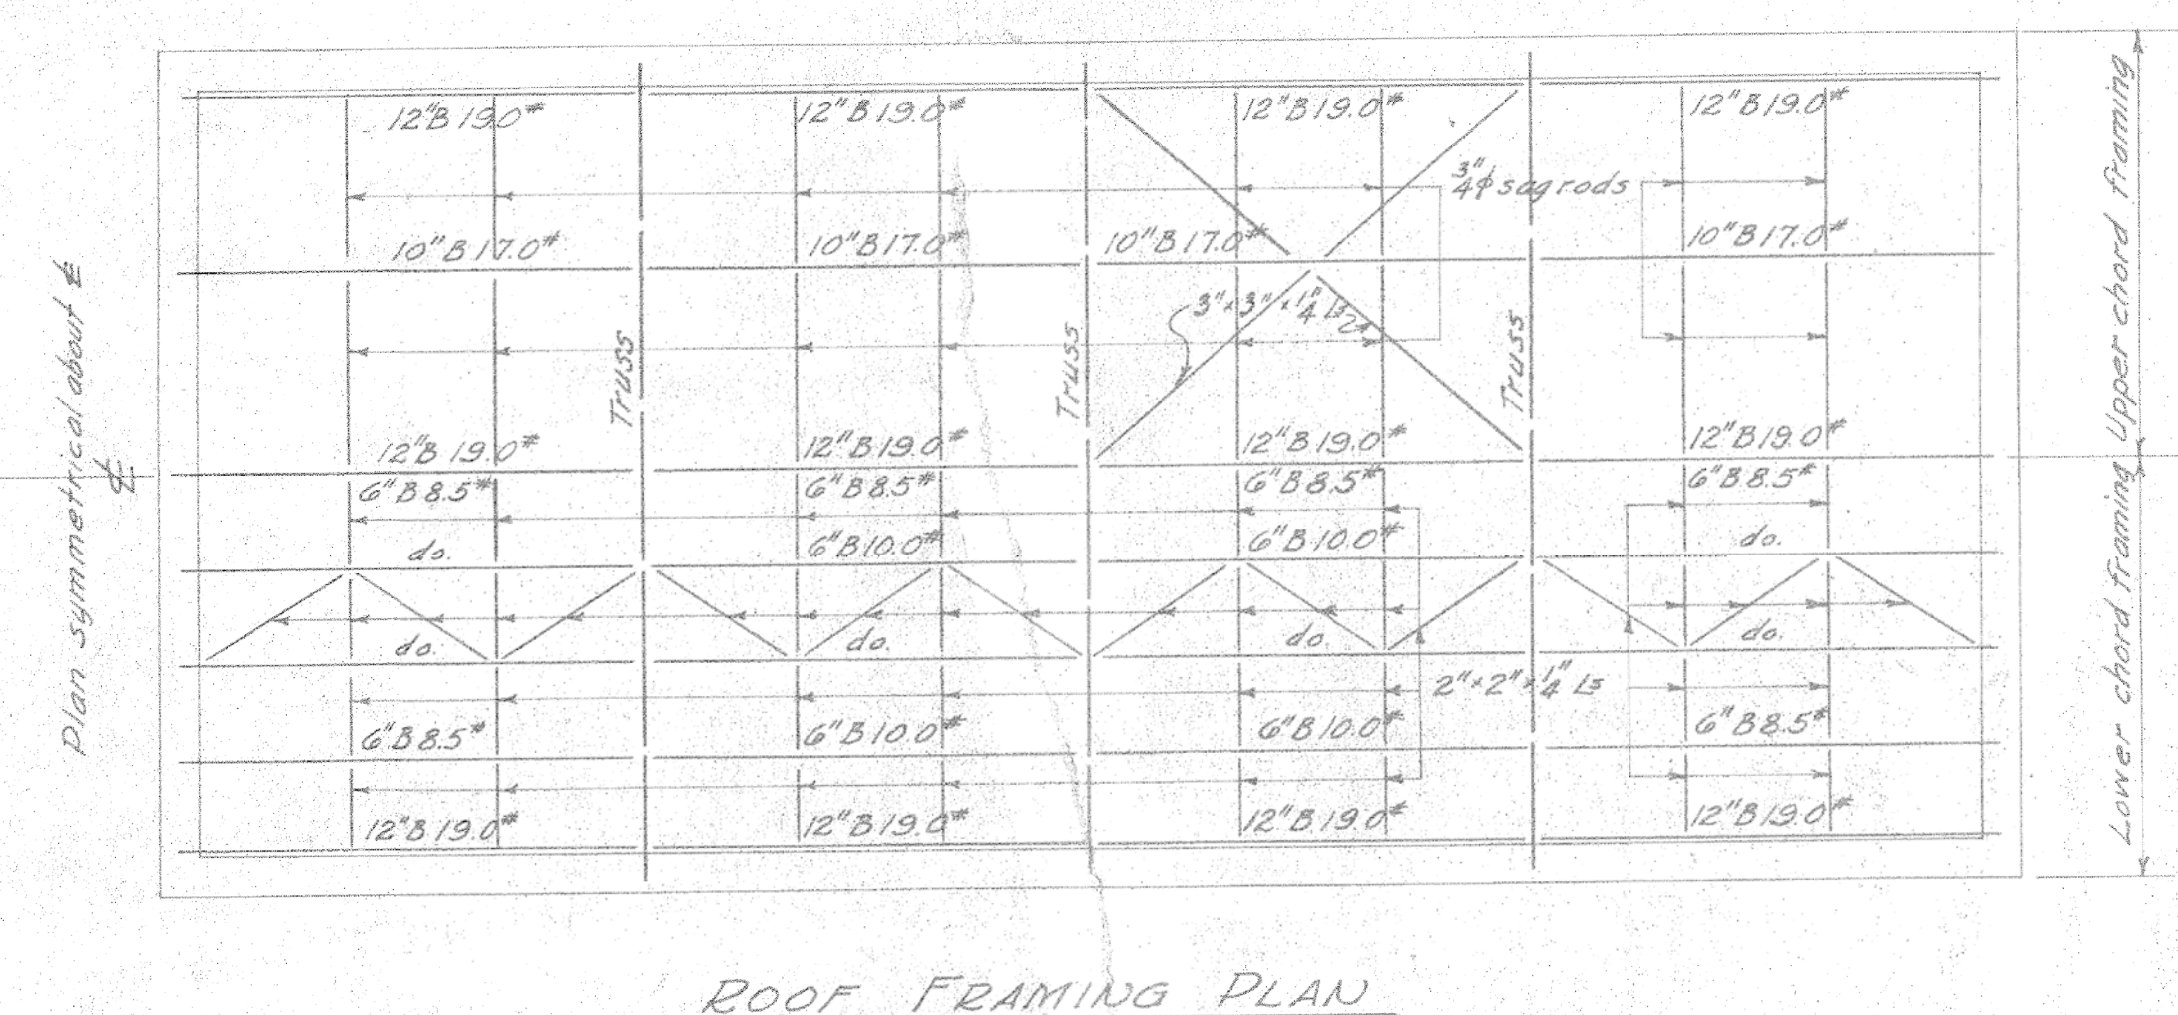

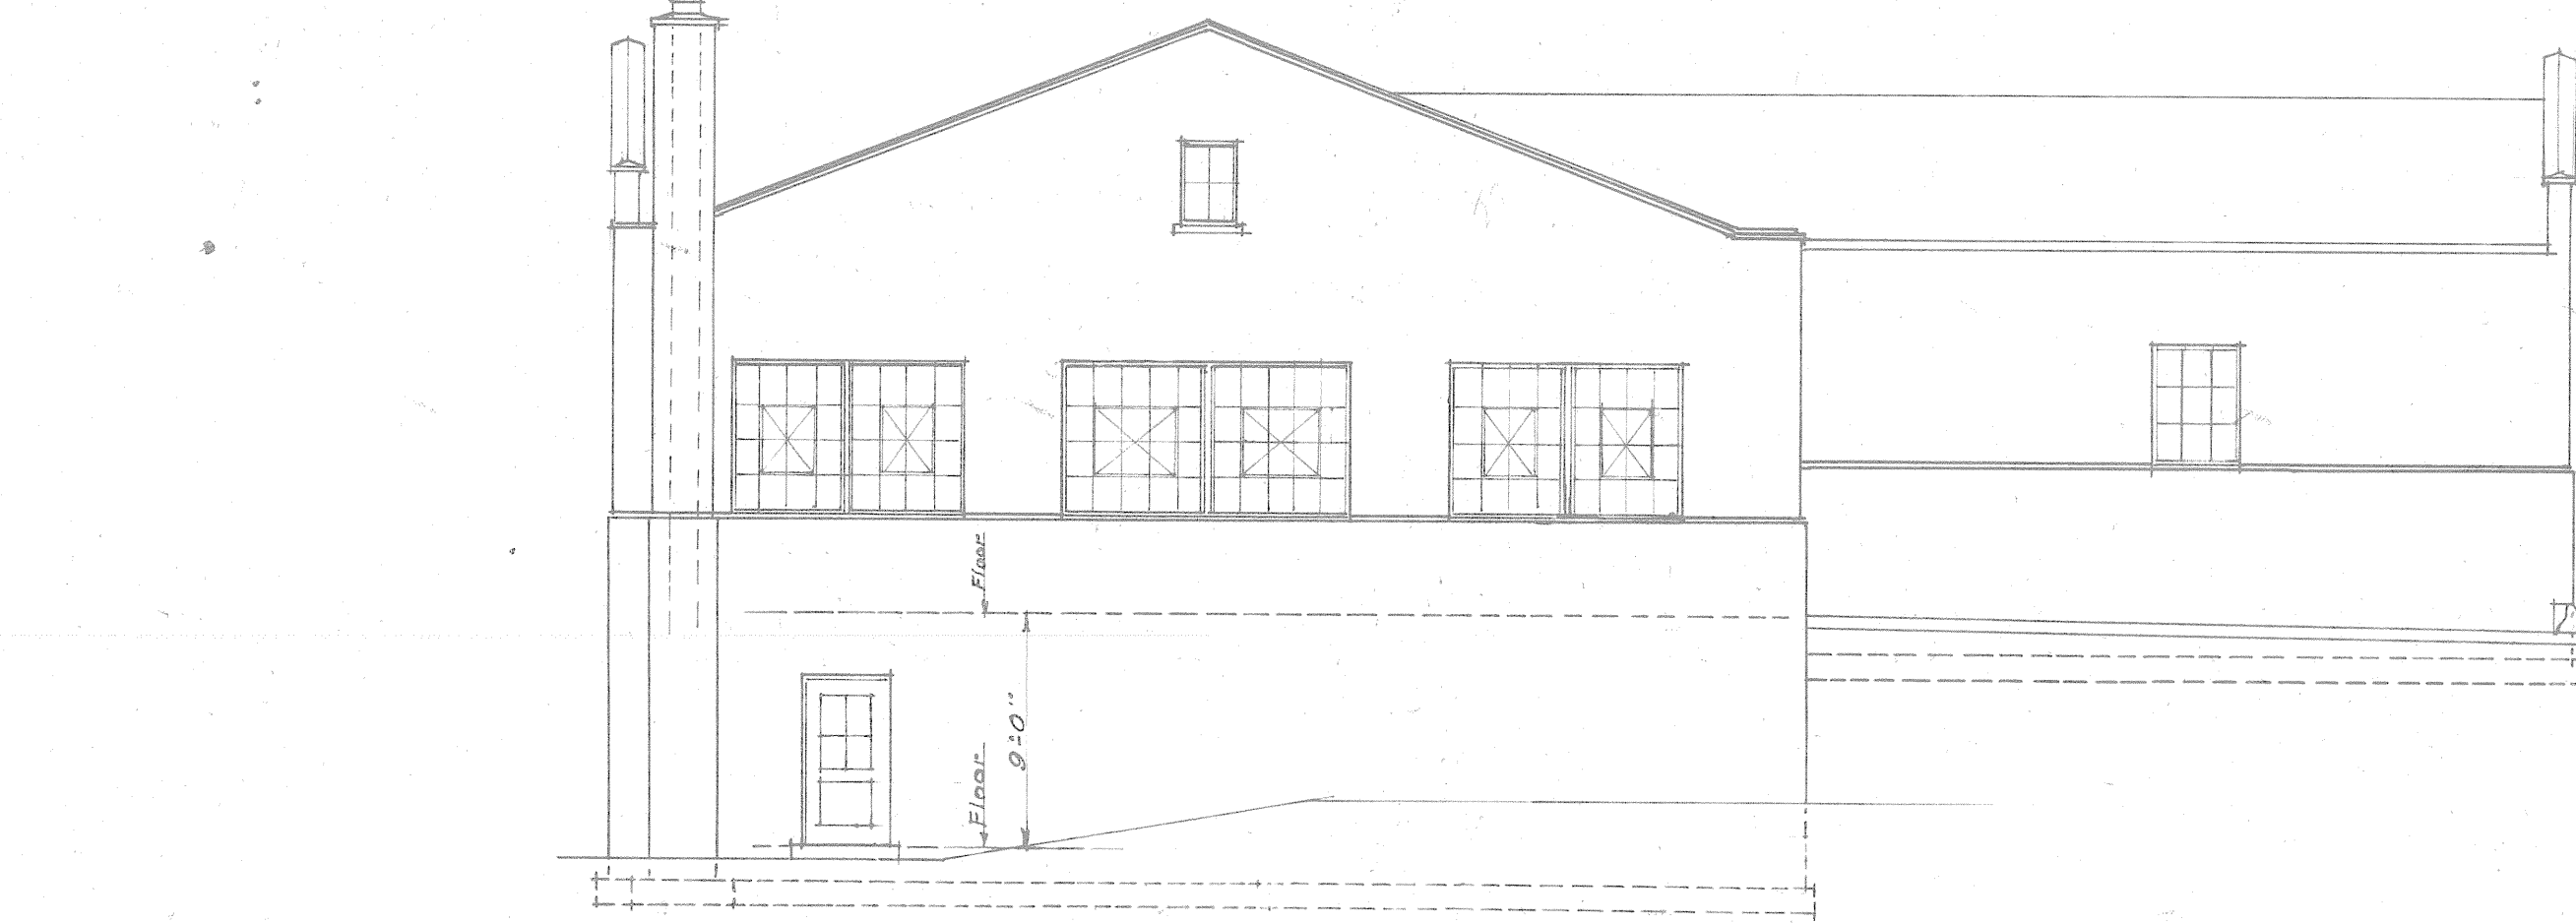

Scale $\frac{1}{8}" = 1'-0"$

Elev. 1

Elev. 2

NORTH ELEVATION
Scale $\frac{1}{4}" = 1'-0"$

SOUTH ELEVATION
Scale 1/8" = 1'-0"

Unit Heater

No. 101 Valve

Plaster walls & ceiling

Wire mesh ceiling

Smooth tile



Concrete

Concrete


Concrete

Concrete

SECTION "A-A" - FLOOR PLAN
Scale 1/8" = 1'-0"

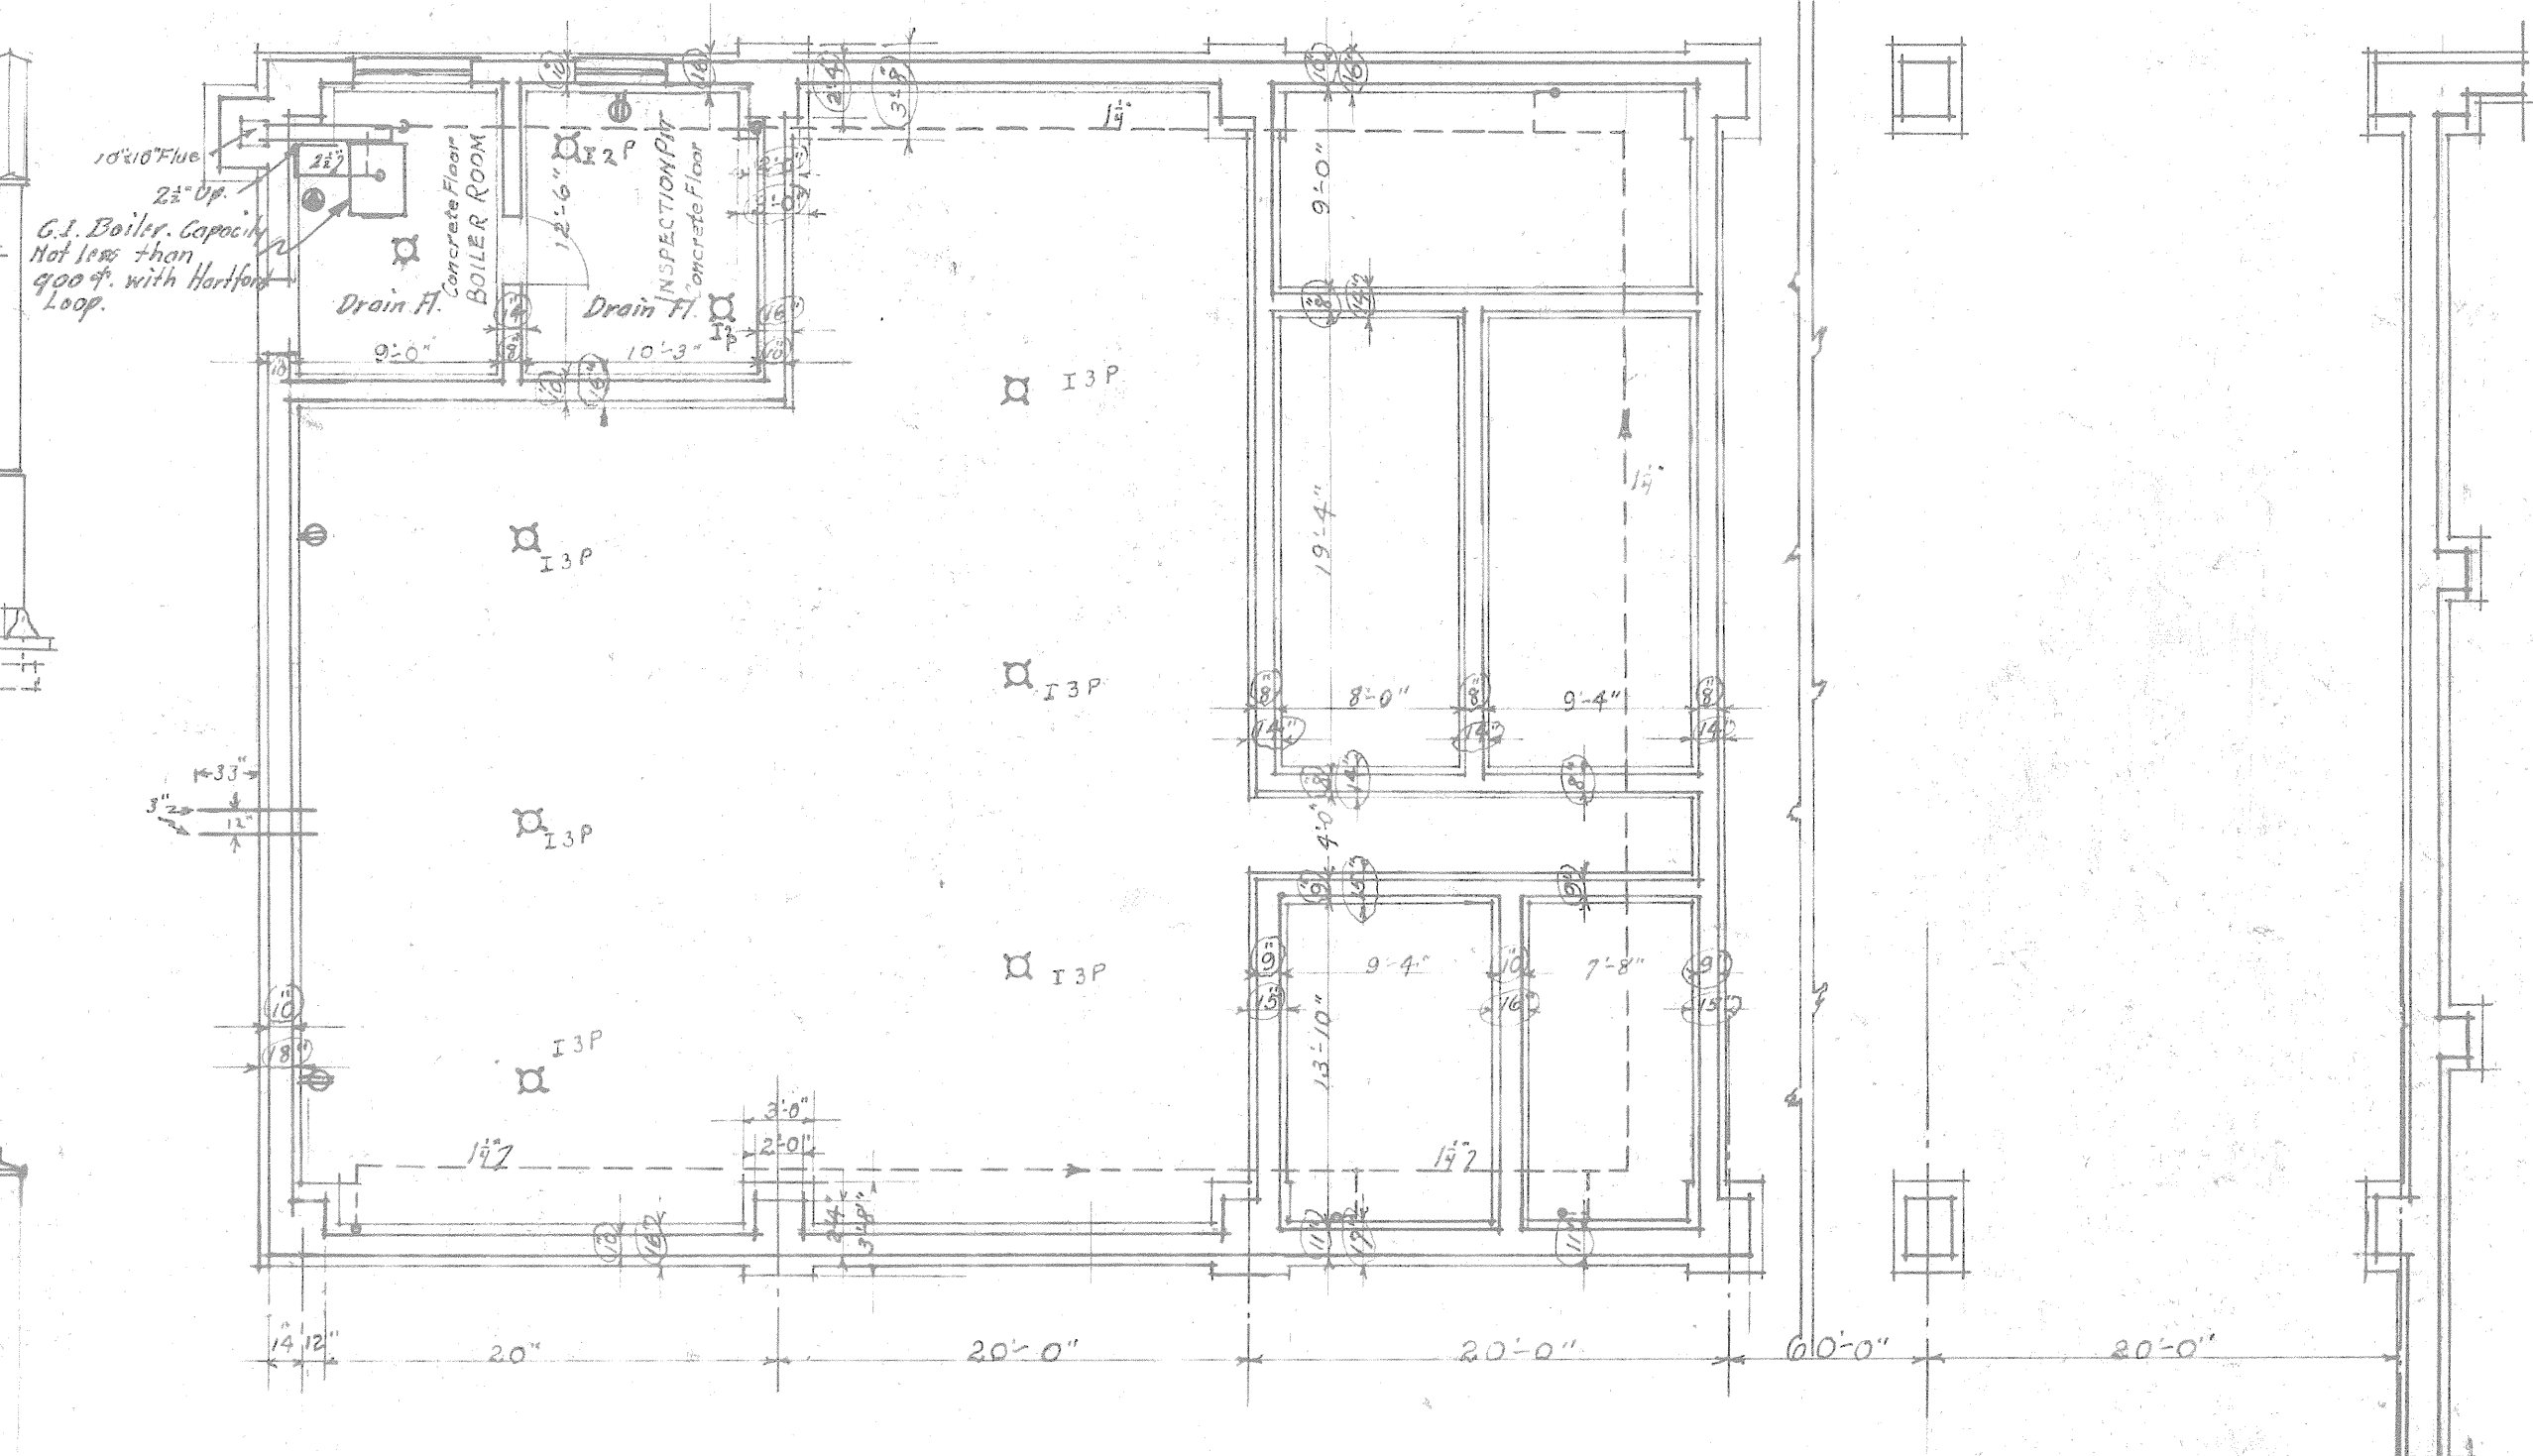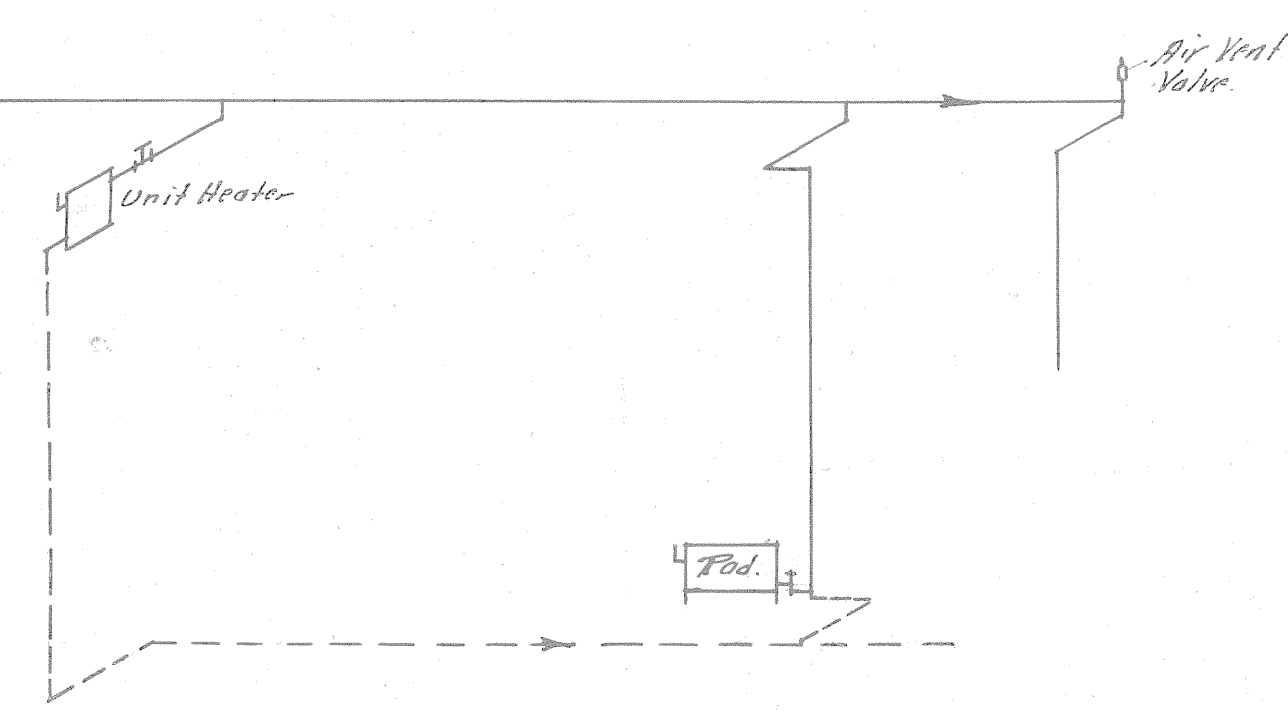


FOUNDATION PLAN
Scale $\frac{1}{8}" = 1'-0"$

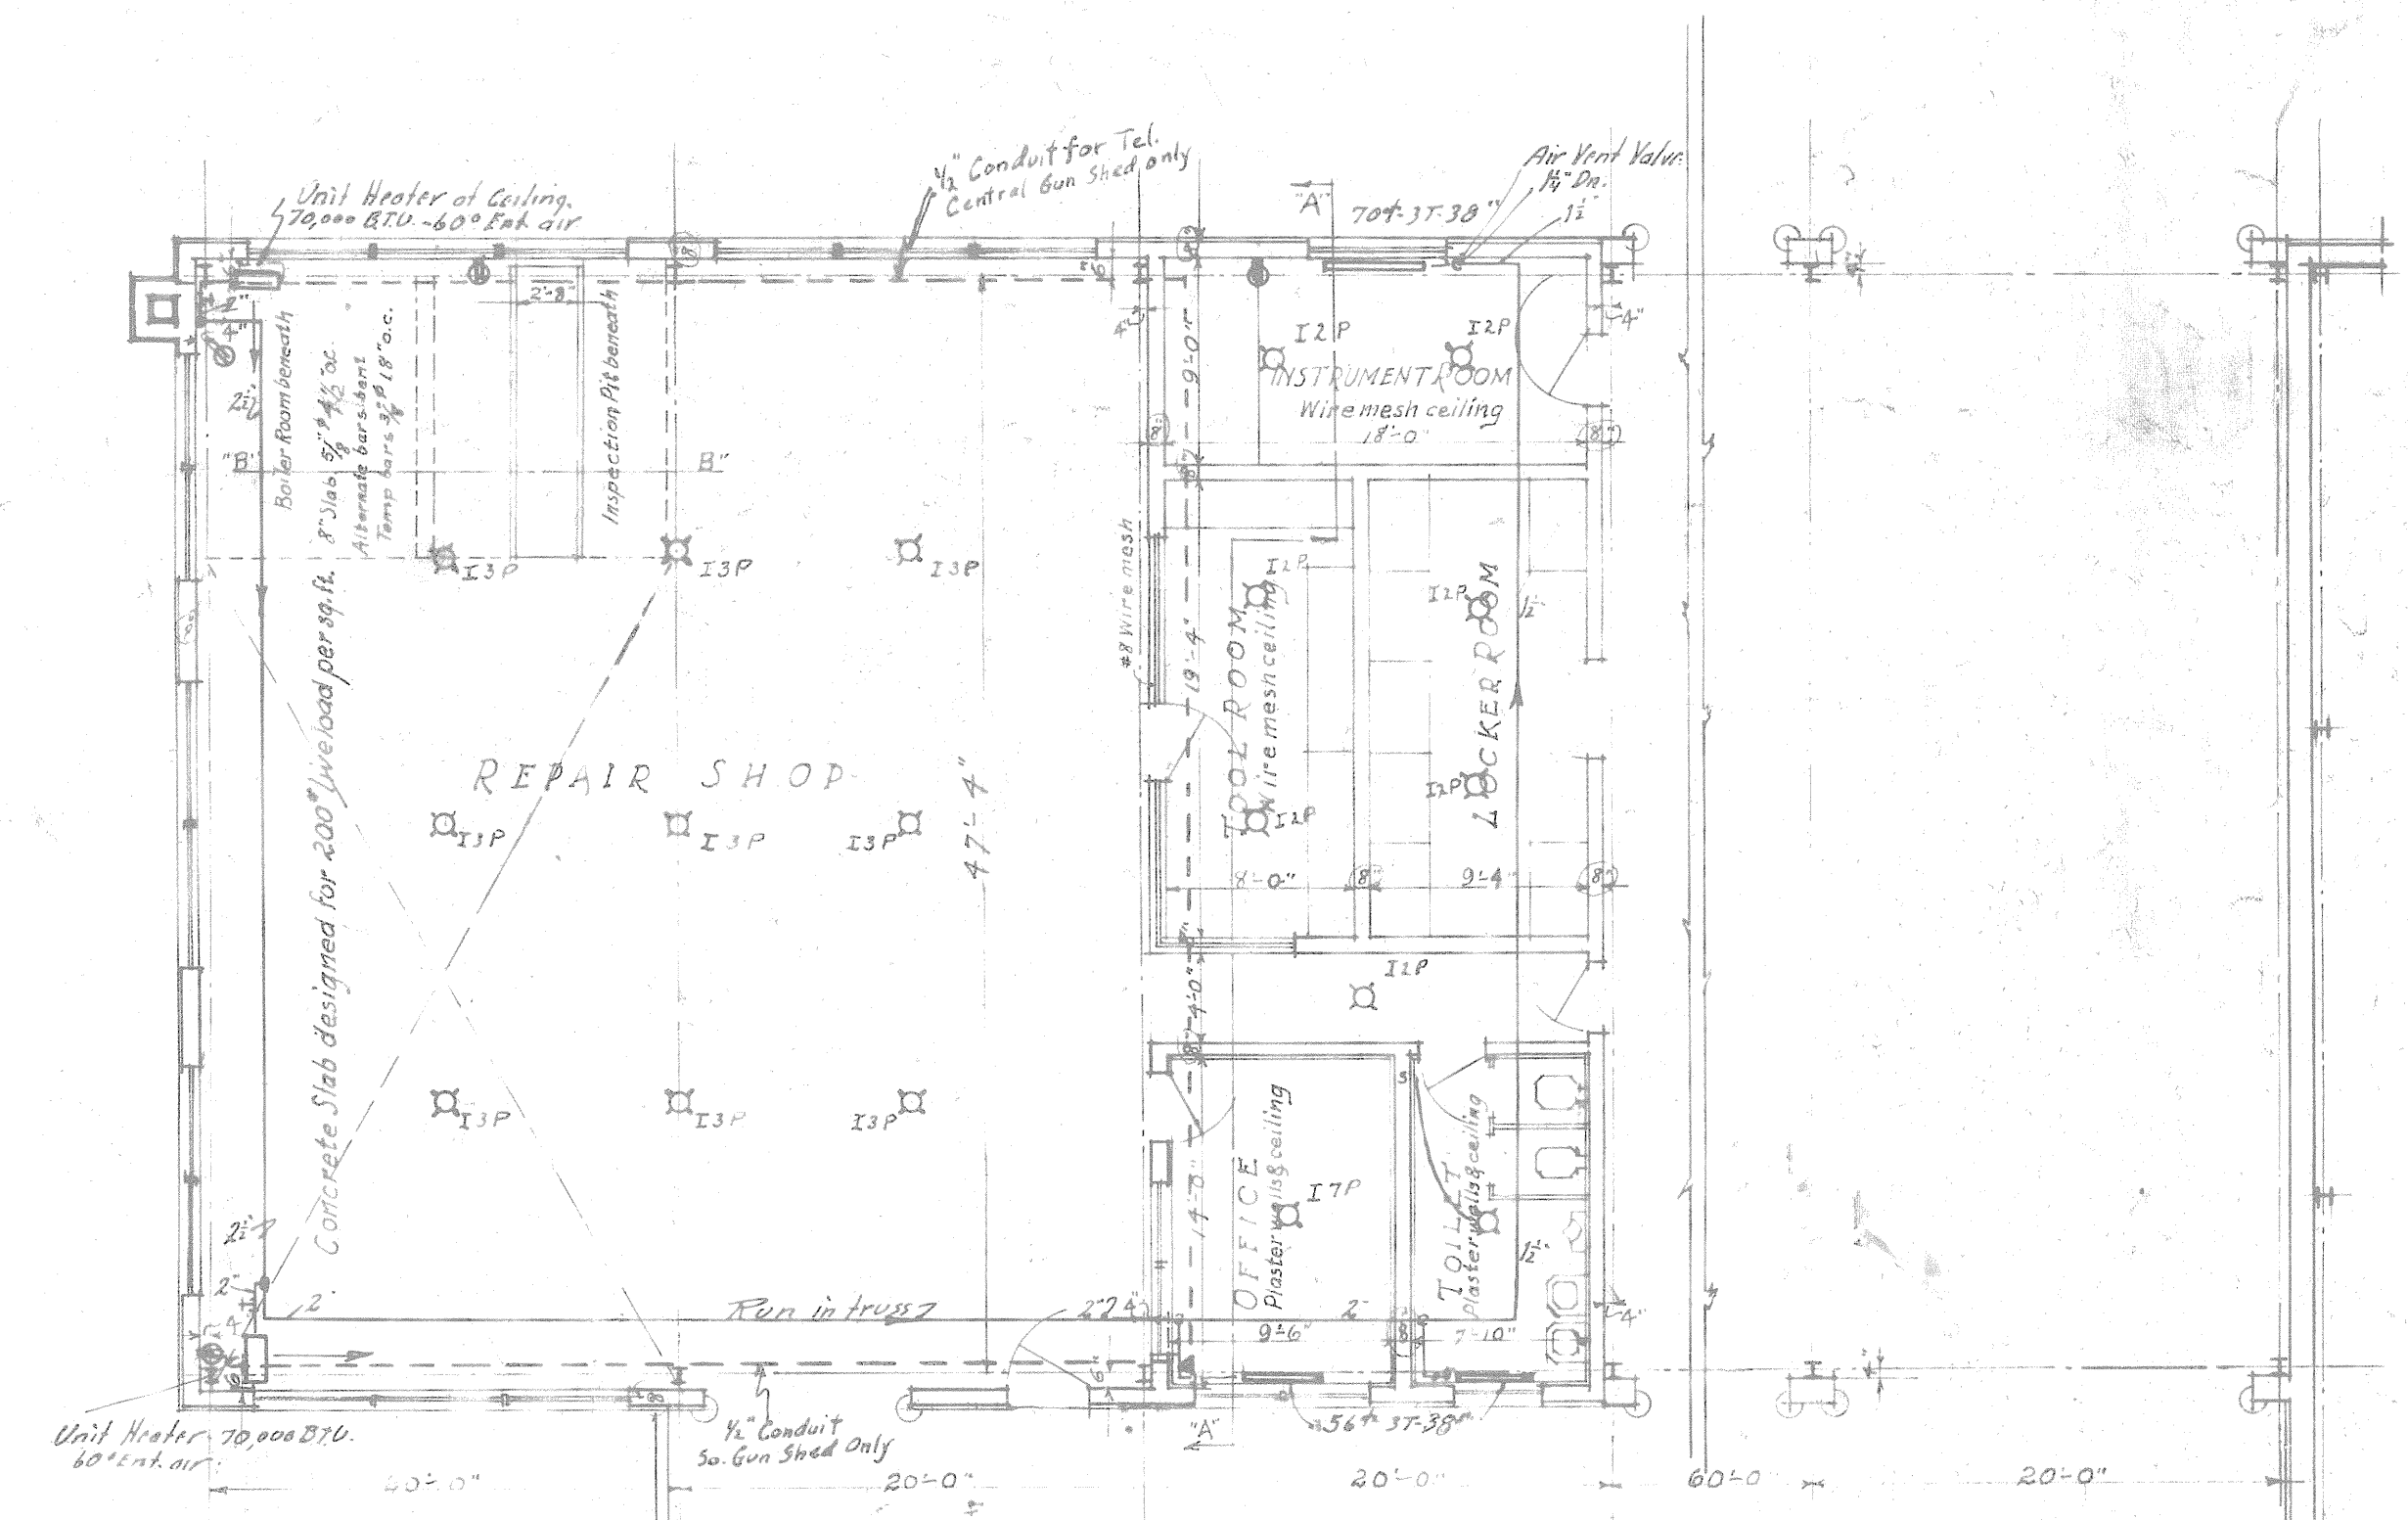


First Floor Plan
Scale 1/8" = 1'-0"

APPROVED BY:	COL. <i>W. L. F. A.</i> COM. P. A. S. P. S. SILL, OKLA. ATG	OFFICE OF THE CONSTRUCTING QUARTERMASTER		
		FORT SILL, OKLAHOMA		
		GUN SHED		
		(REVISED PLAN)		
		FORT SILL, OKLAHOMA		
	DRAWN BY GUY DALL	CHECKED BY <i>R. E. Egan</i> CONSTR. ENGR.	APPROVED: <i>Richard L. Dutton</i> MAJOR, Q. M. C. CONSTRUCTING, D. M.	DATE:
	TRACED BY GUY DALL			PLAN NUMBER: 6143-1048

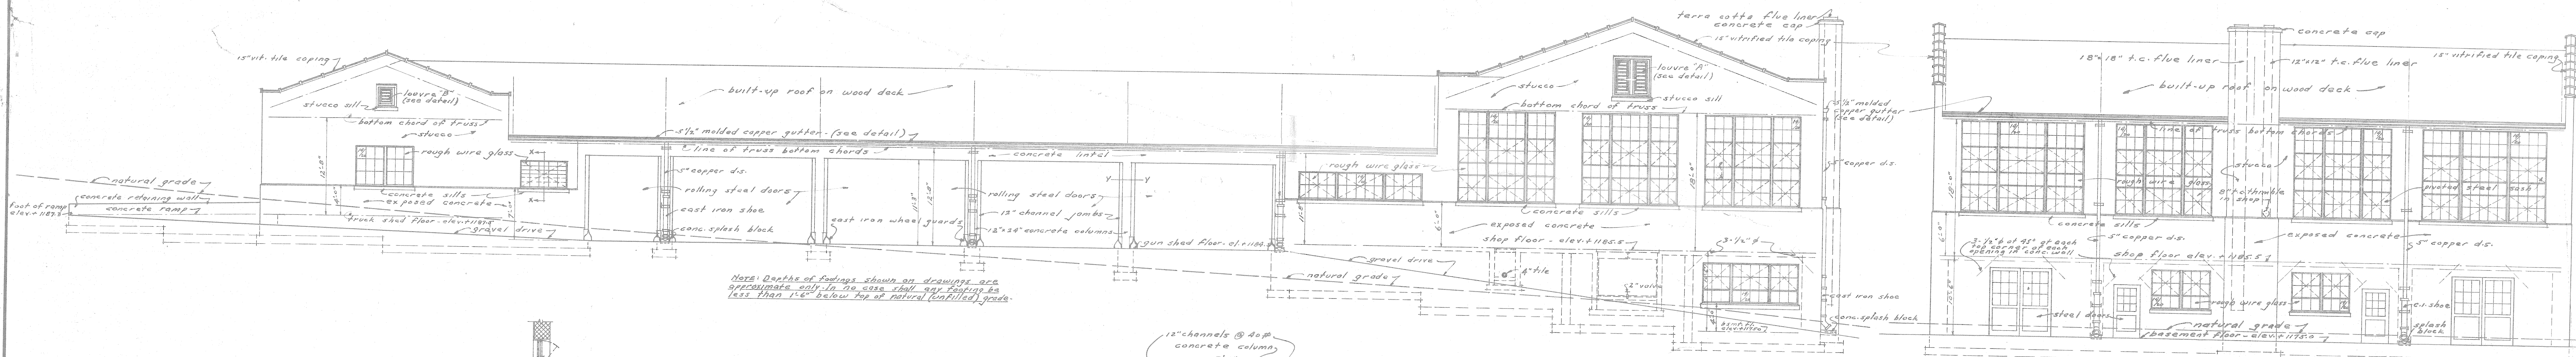


NORTH ELEVATION


WEST ELEVATION

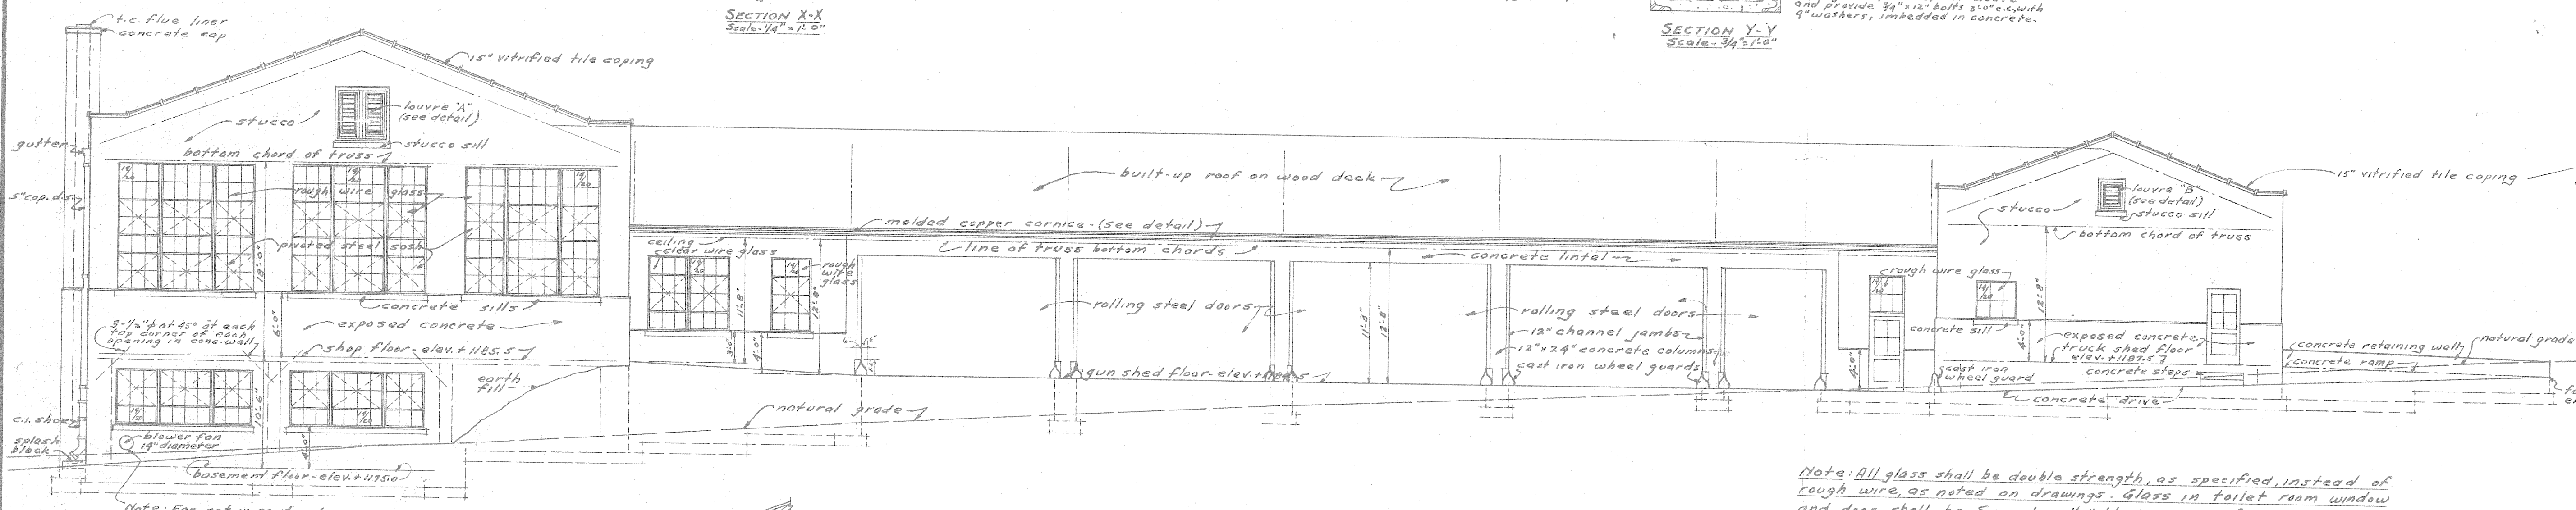


SOUTH ELEVATION

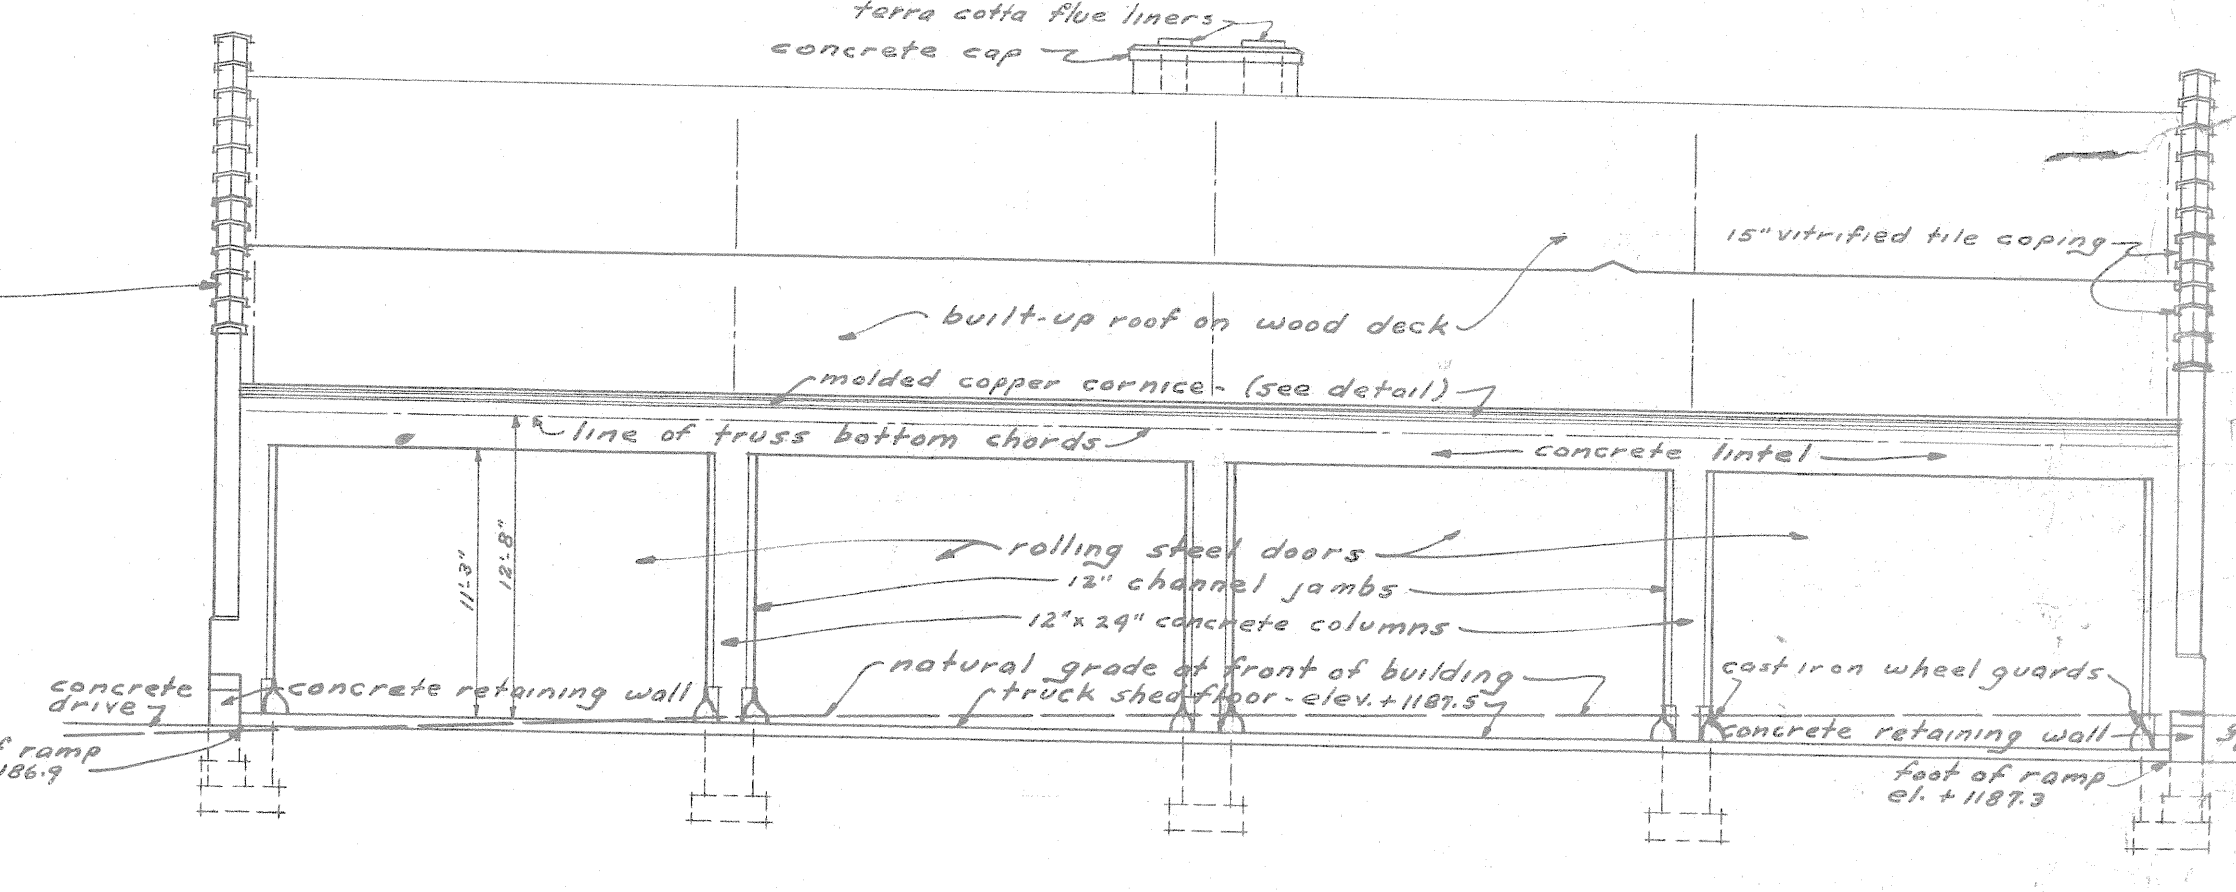

EAST ELEVATION








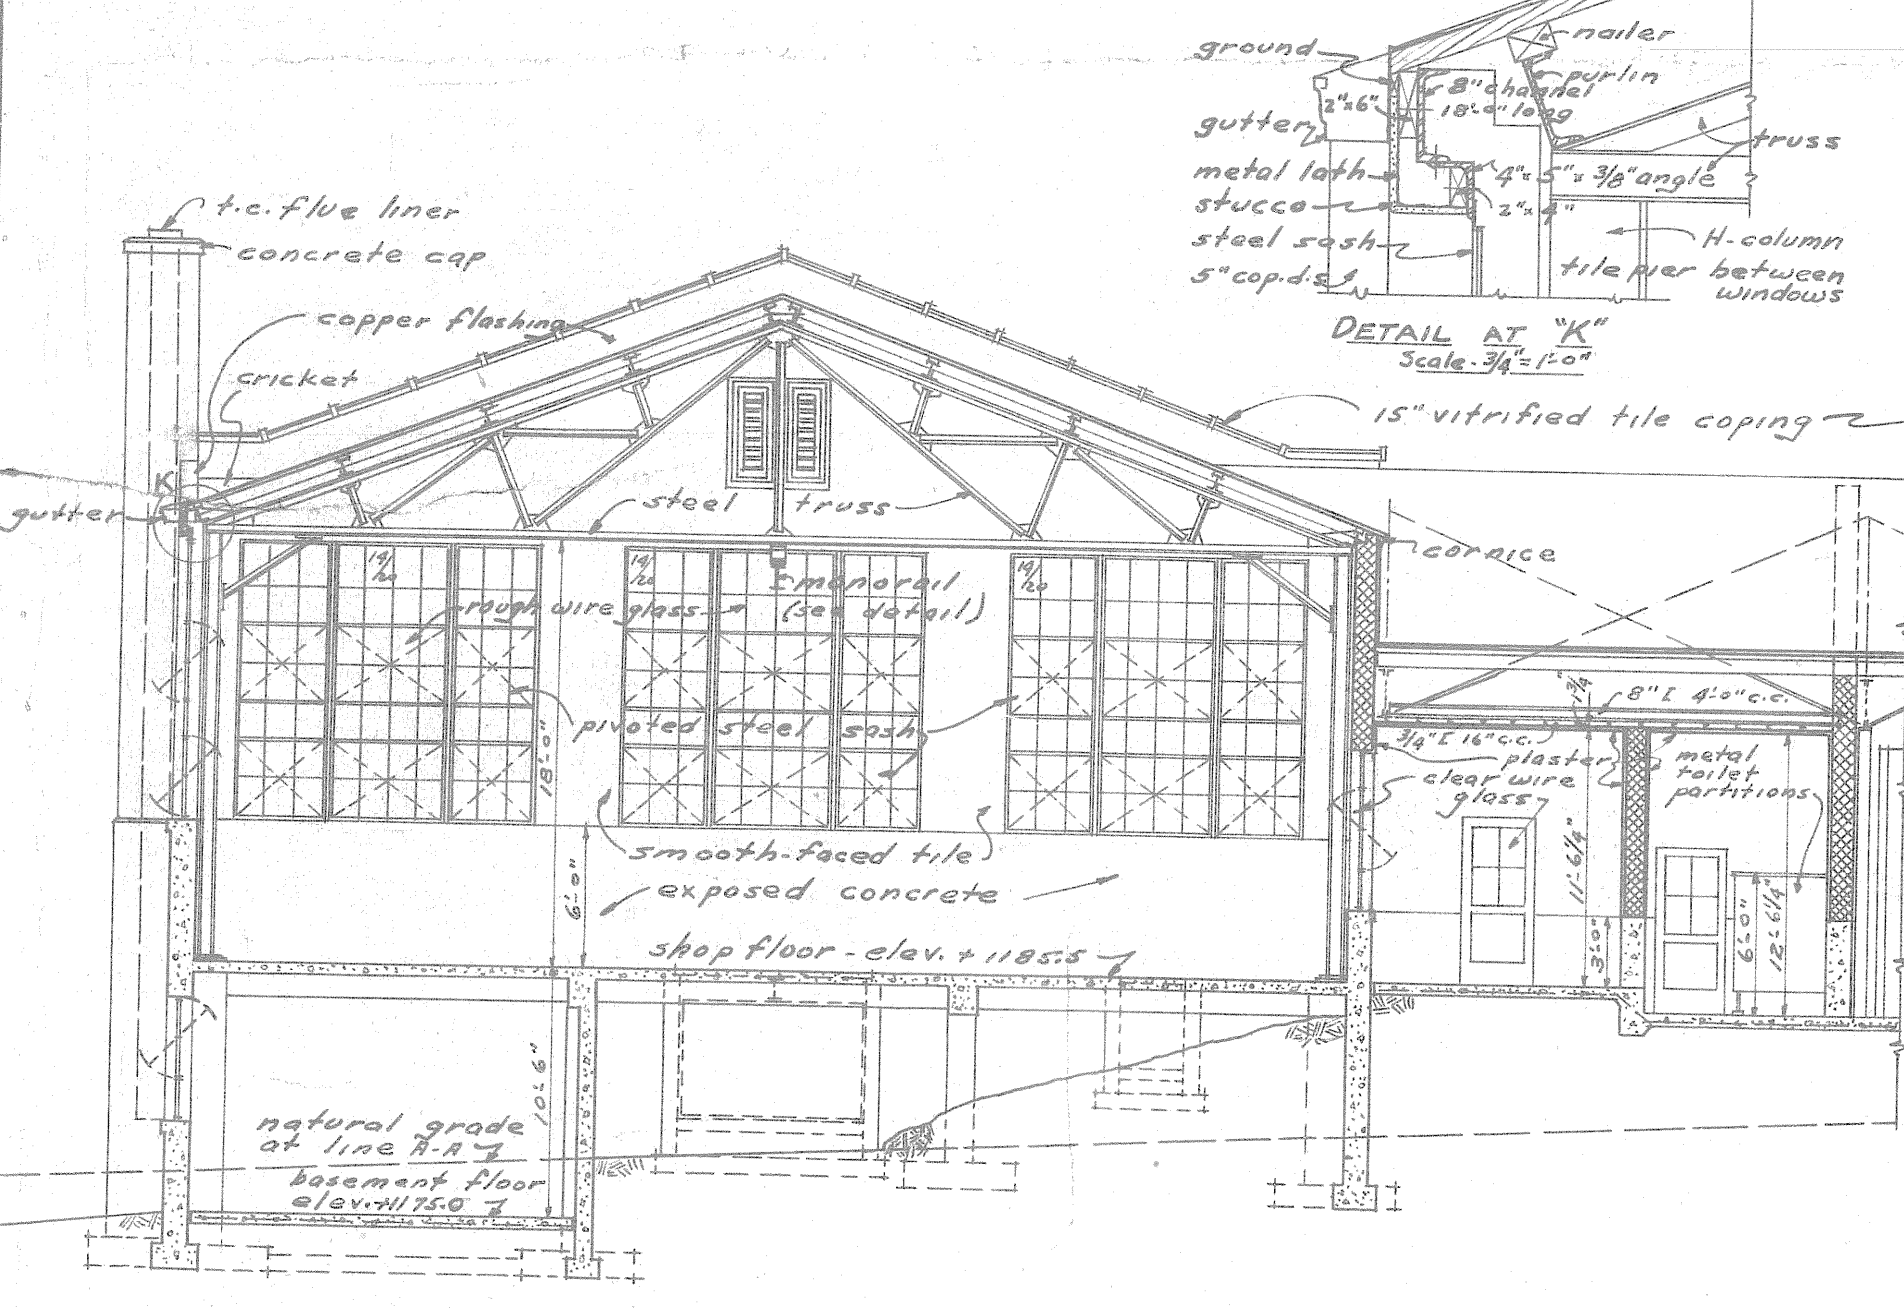


SECTION ON LINE A-A

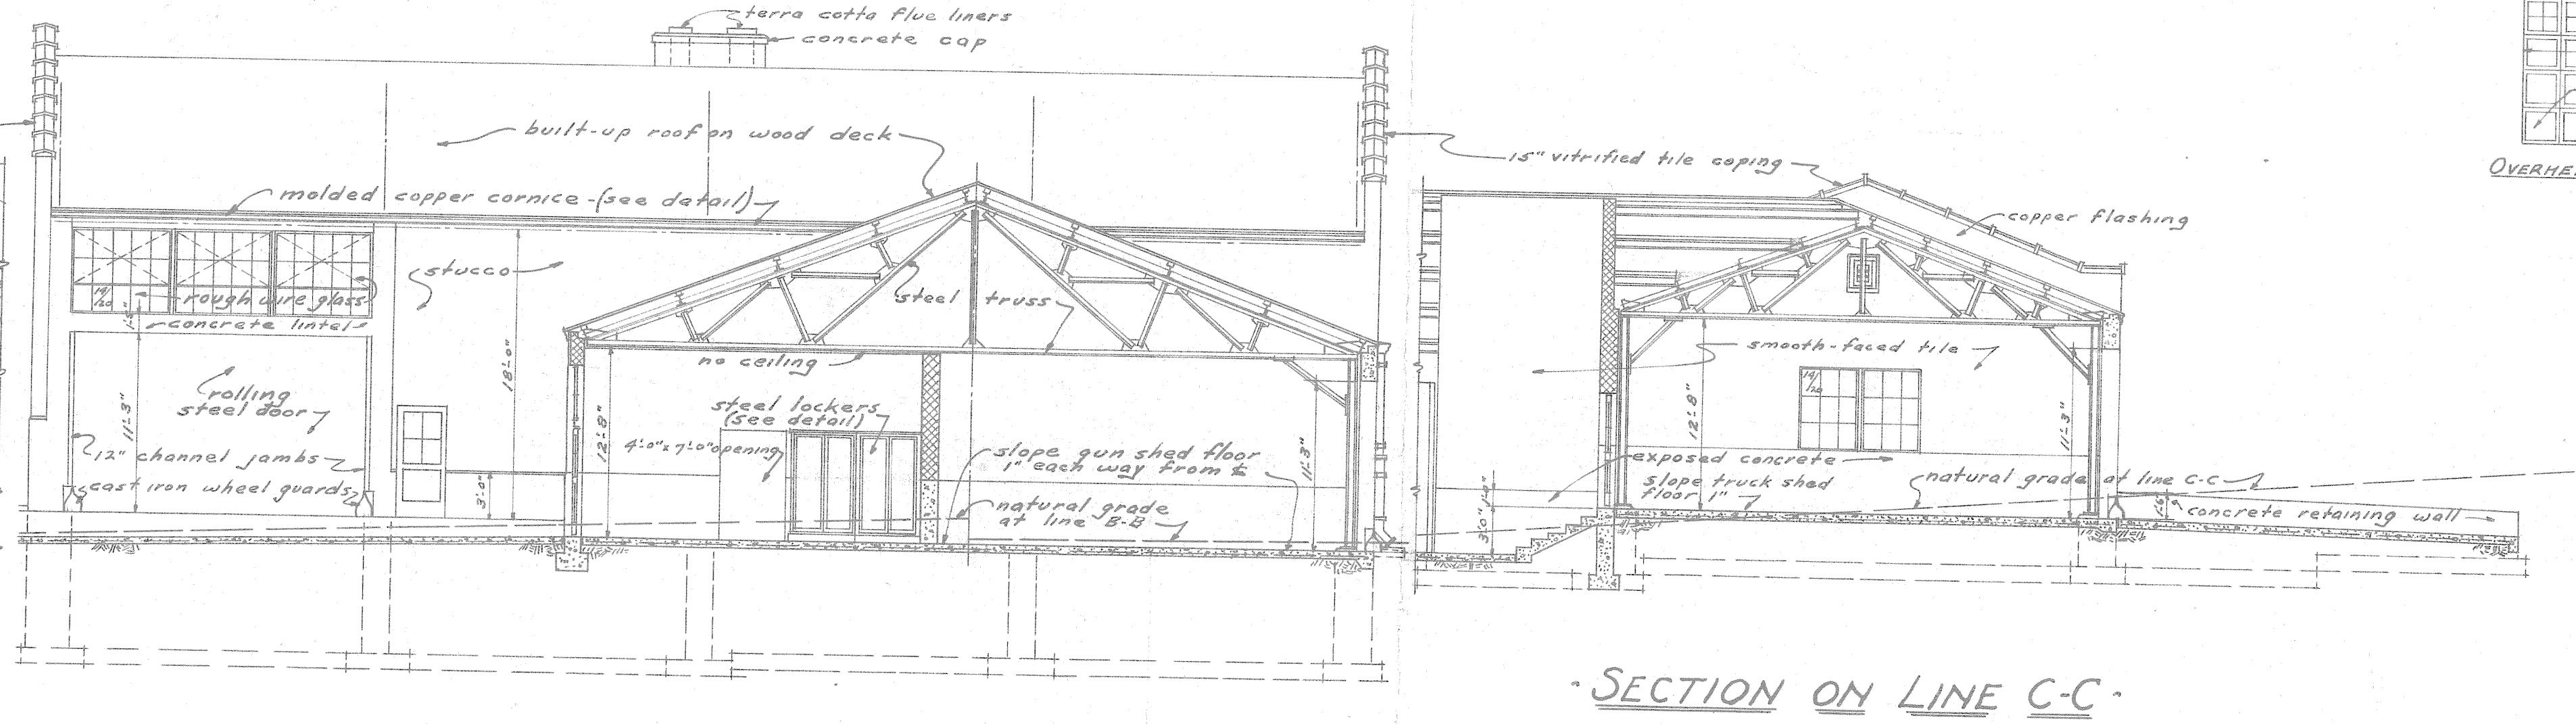


SECTION ON LINE B-B


SECTION ON LINE C-C

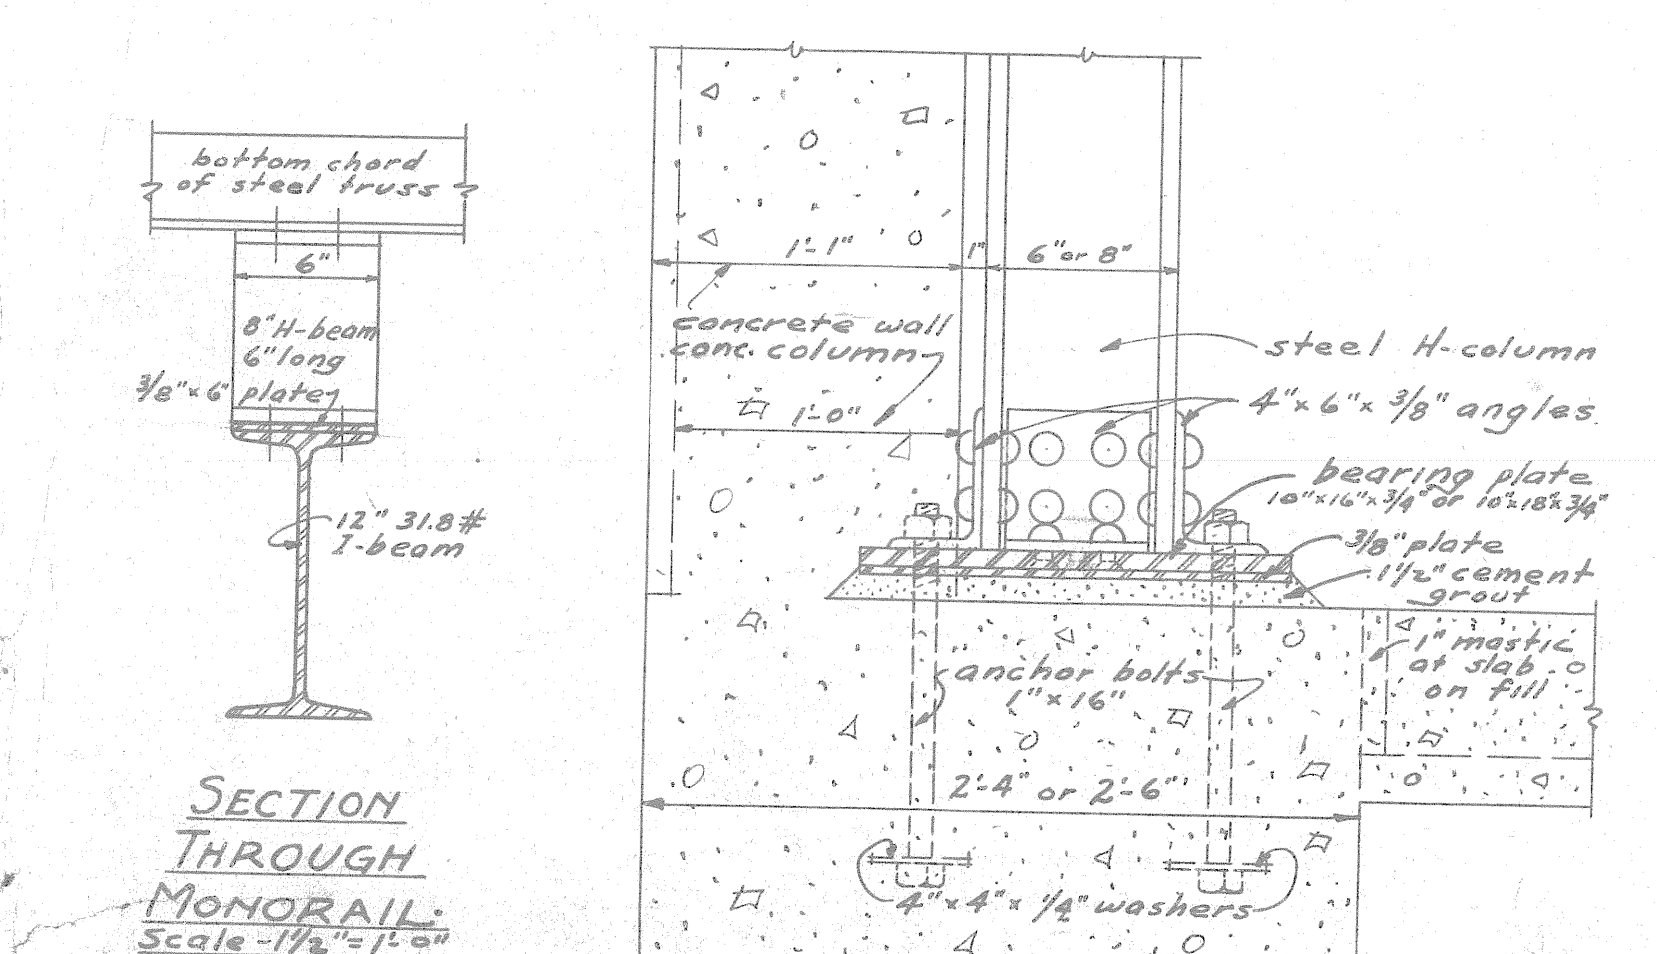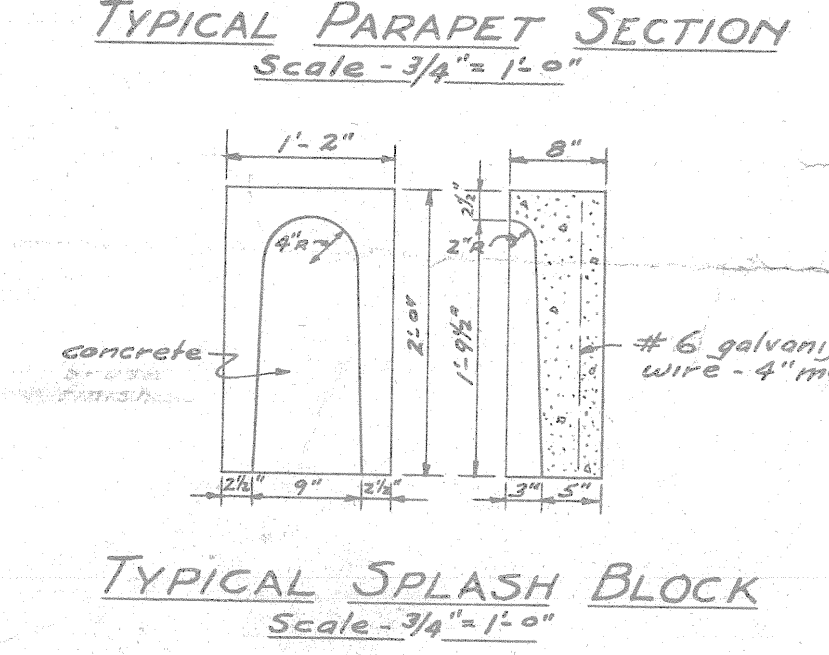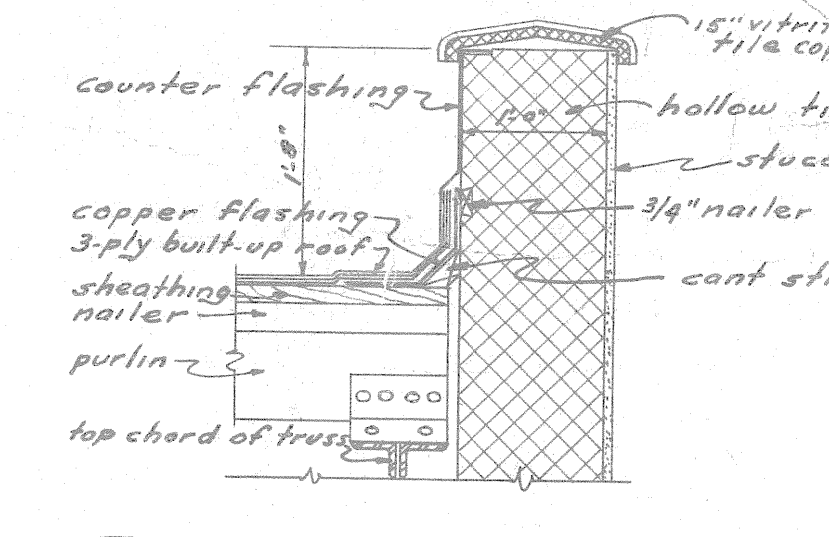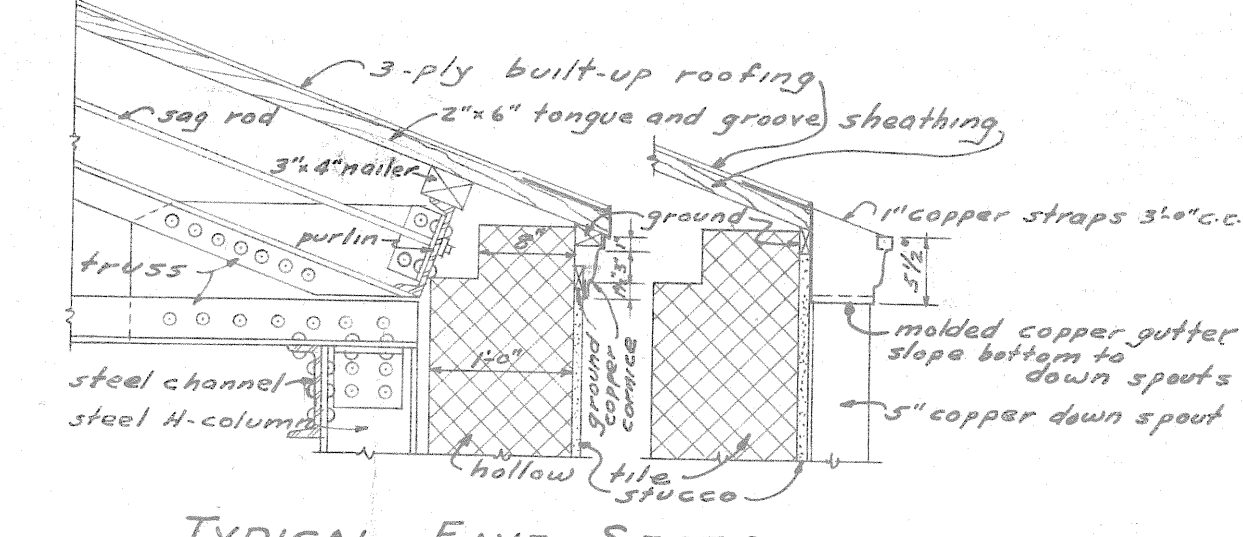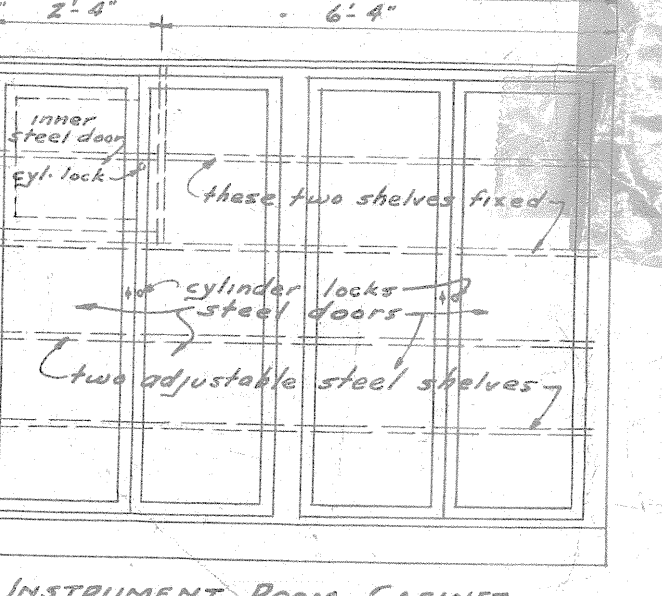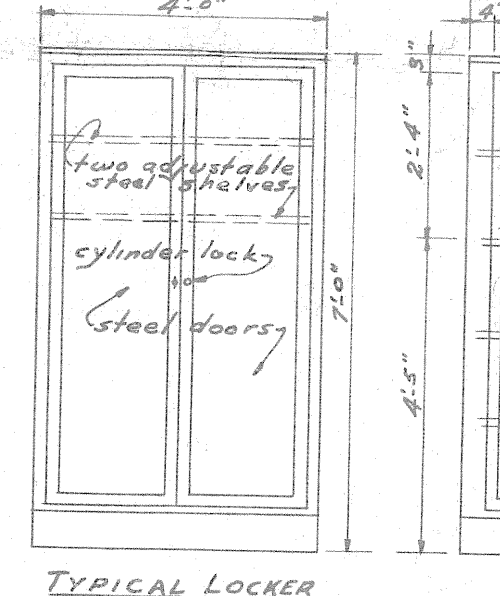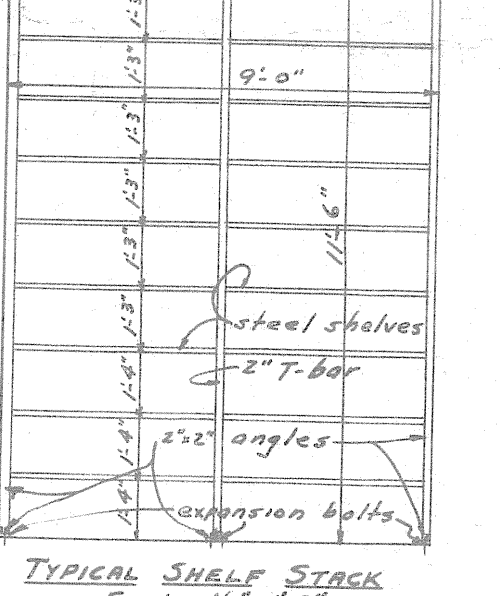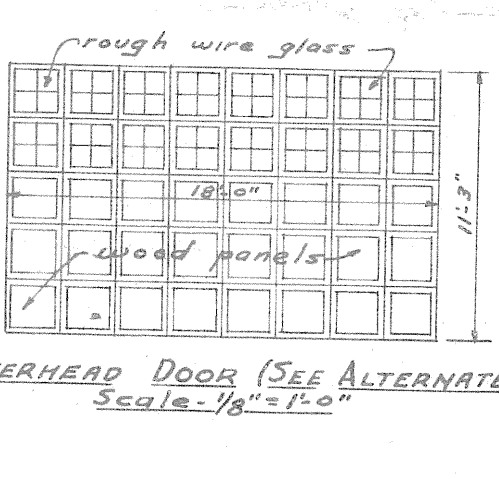


TYPICAL COLUMN BASE
Scale 1/4\"/>

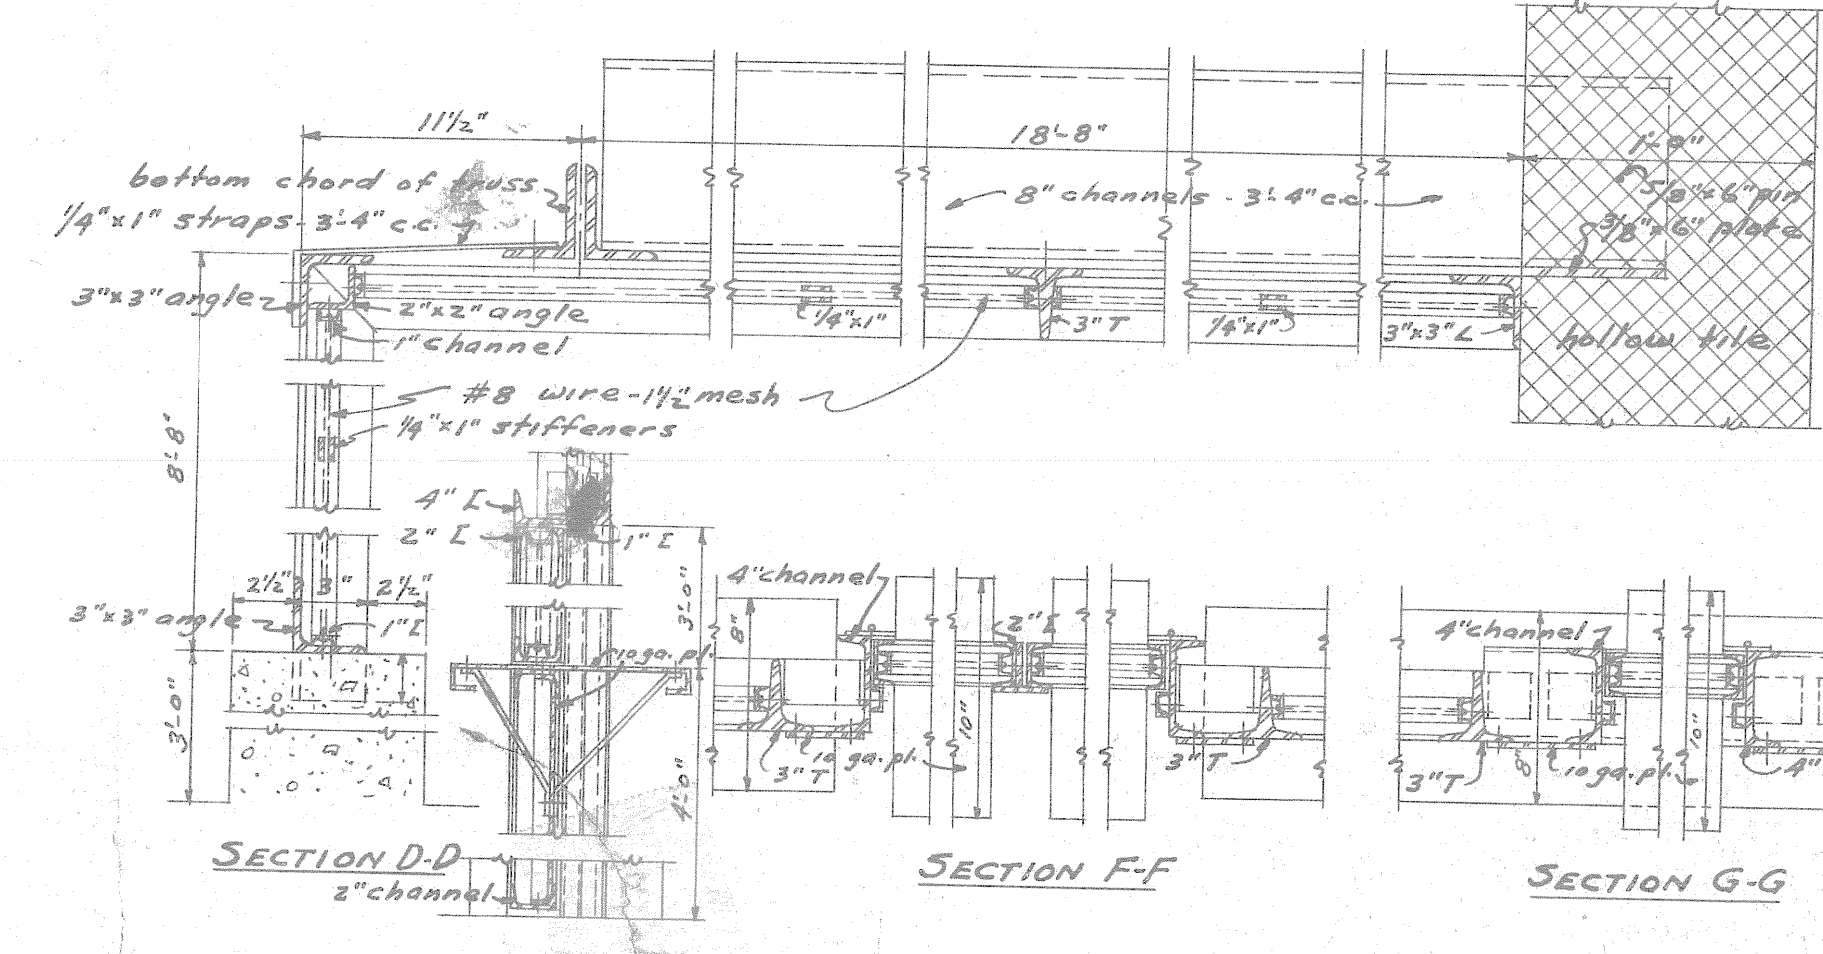


SECTION D-D

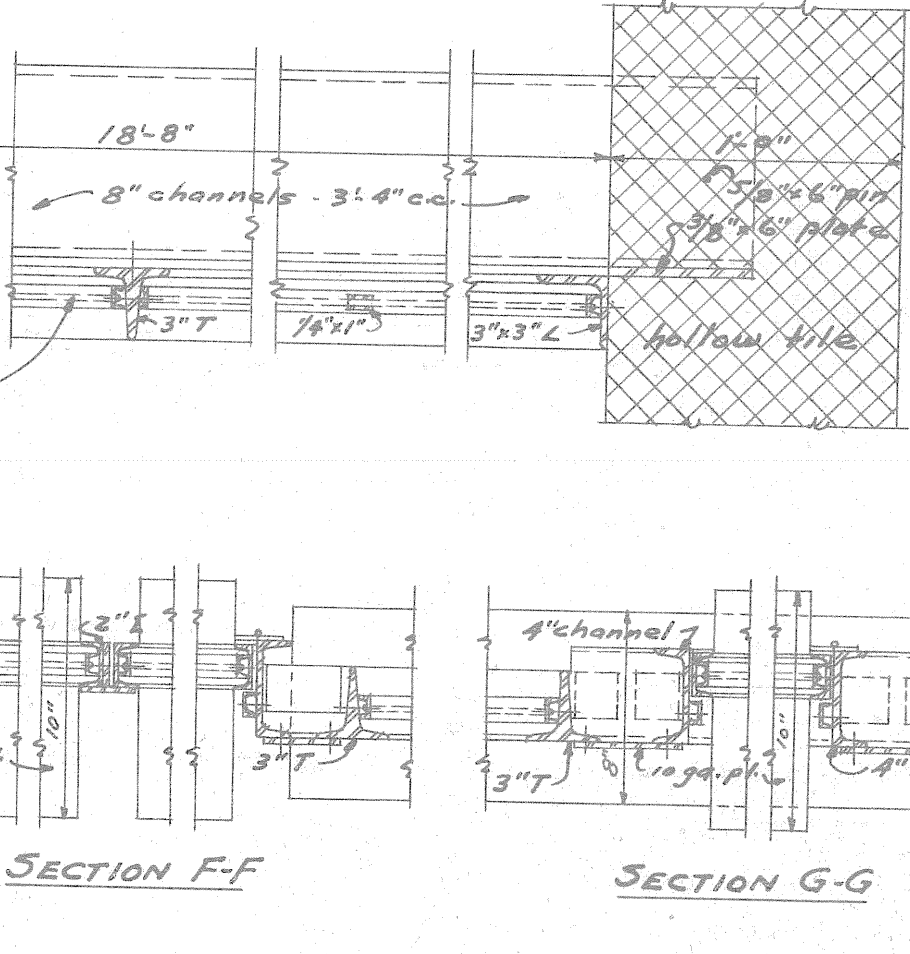


SECTION F-F

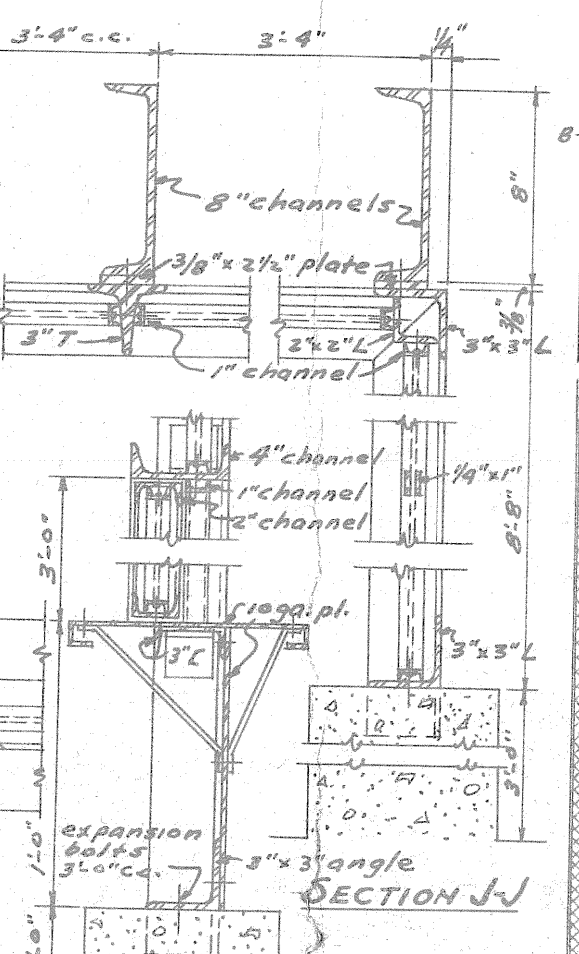


SECTION G-G

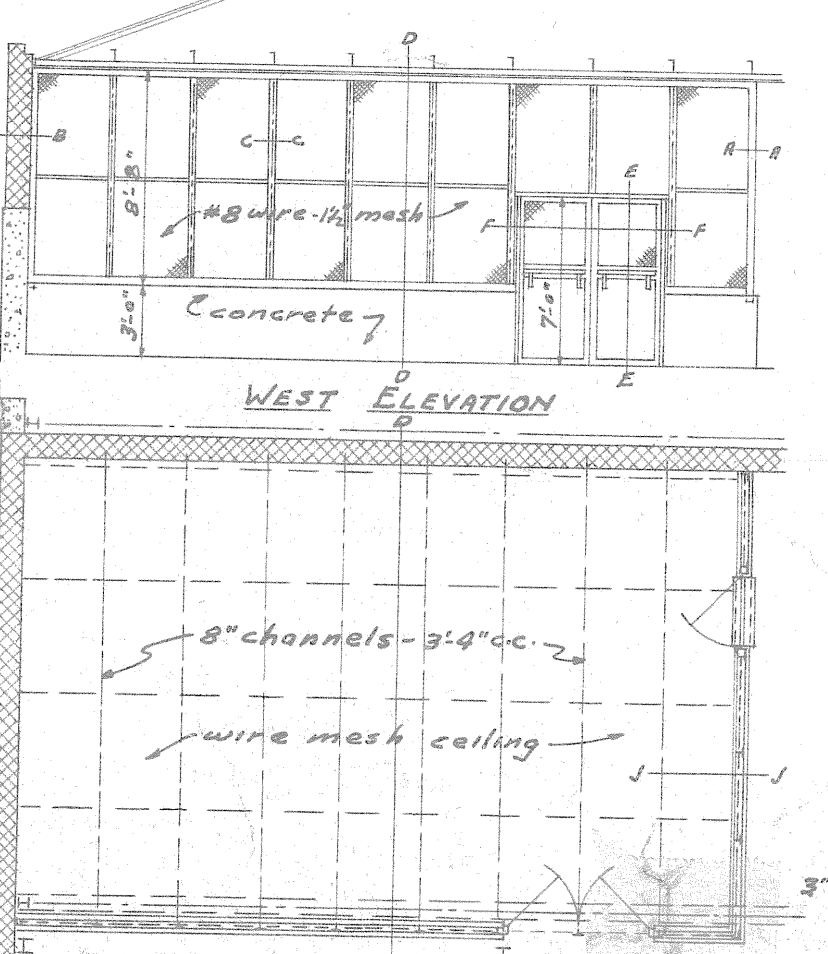


SECTION H-H

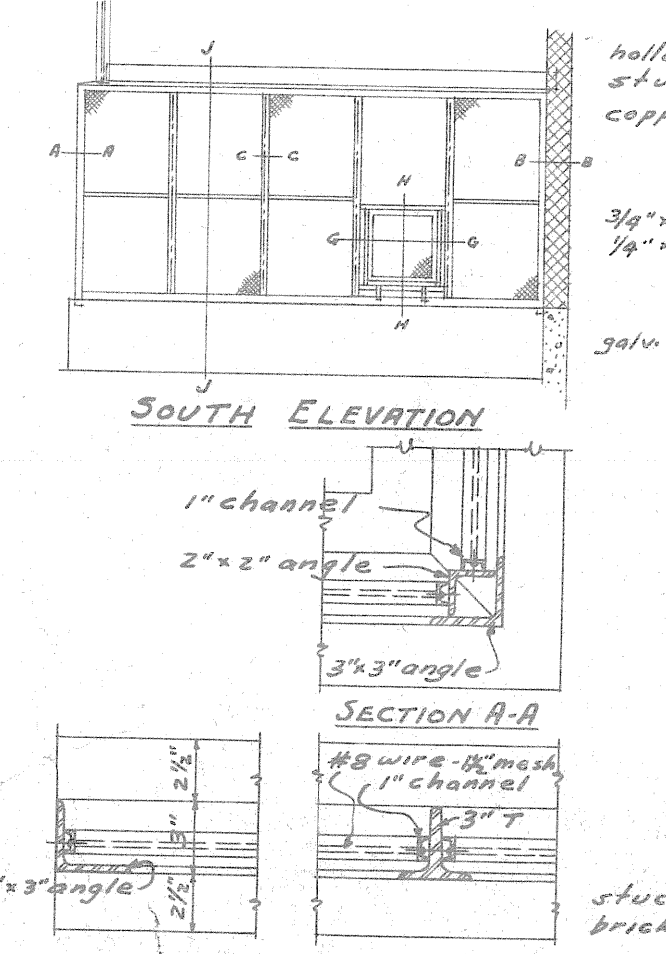

SECTION I-I

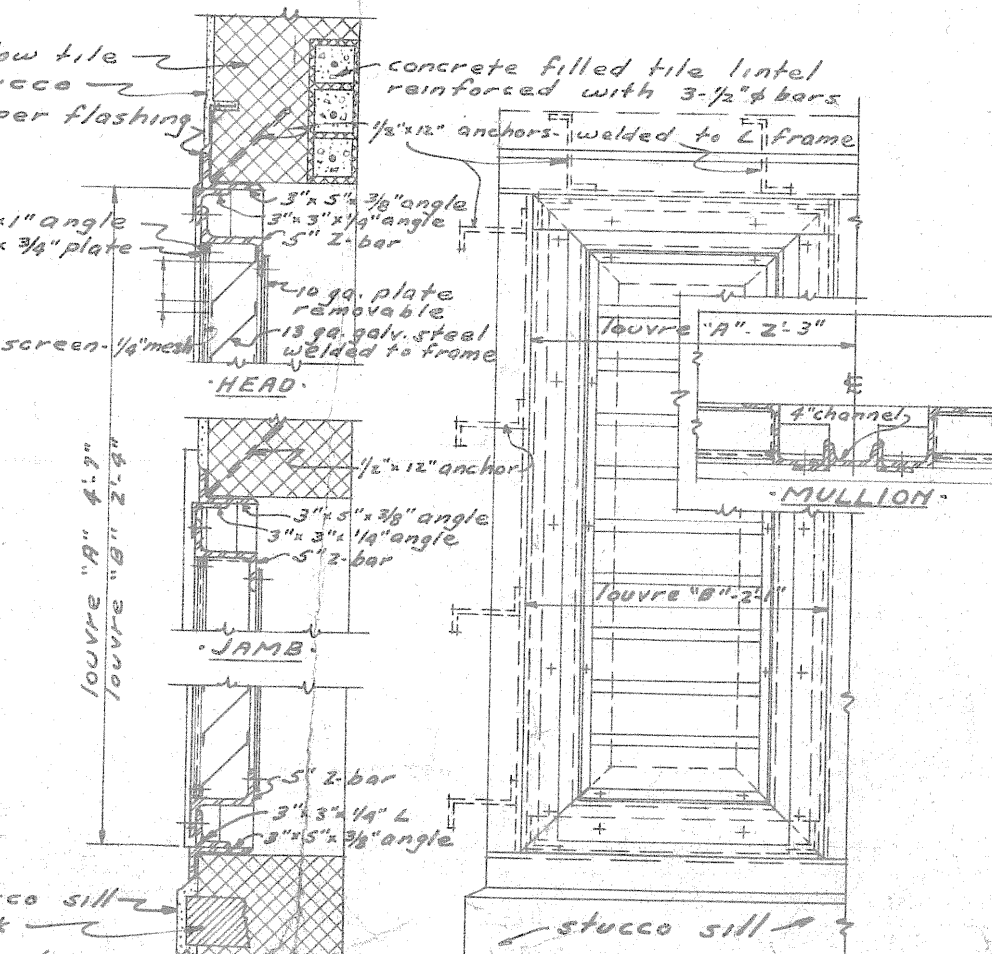

SECTION J-J

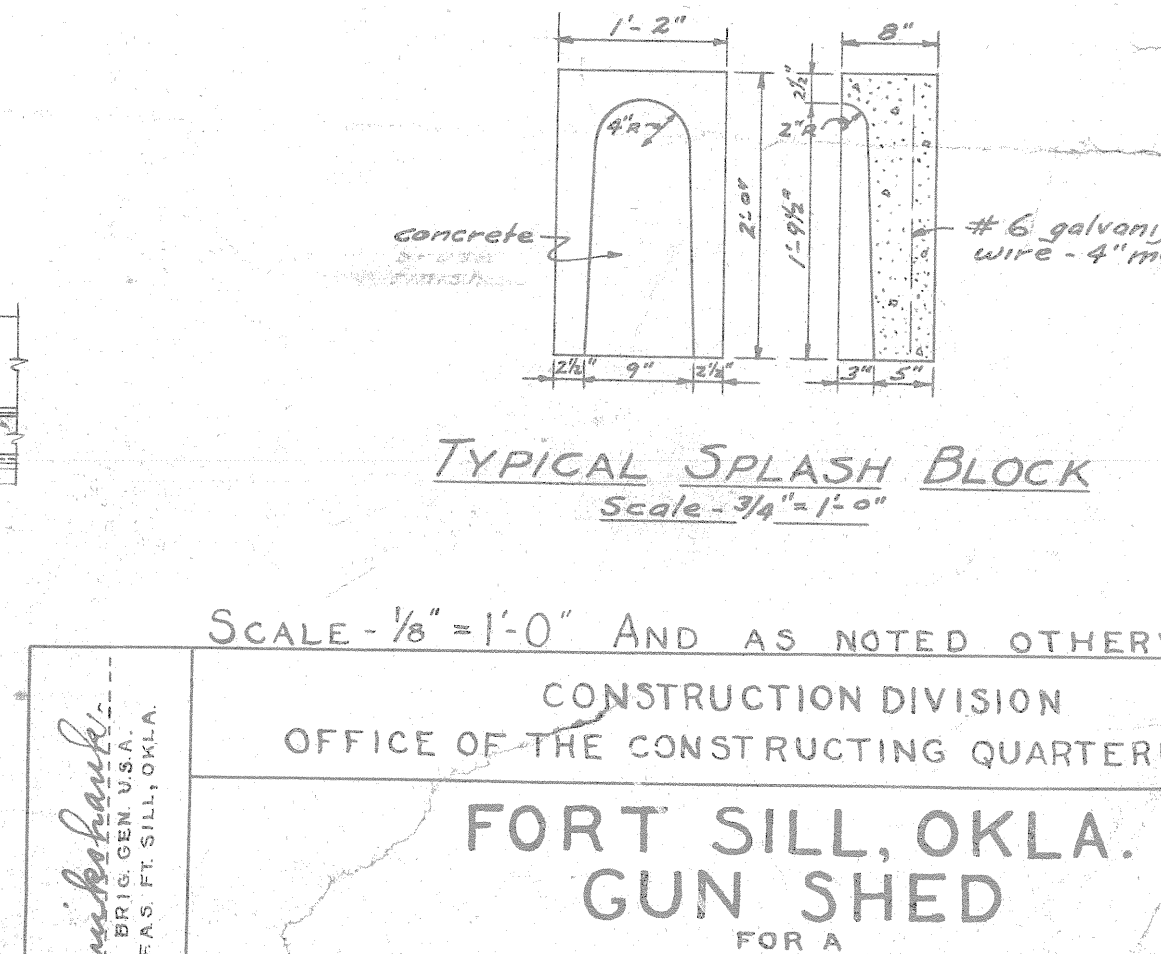

TYPICAL LOUVRE DETAILS
Scale 3/4\"/>

DETAILS OF WIRE MESH PARTITION AROUND TOOL ROOM
Plan and Elevations Scale 1/4\"/>



SCALE - 1/8\"/>

CONSTRUCTION DIVISION
OFFICE OF THE CONSTRUCTING QUARTERMASTER


FORT SILL, OKLA.
GUN SHED
FOR A
FIRING BATTERY - FIELD ARTILLERY

ELEVATIONS - SECTIONS & DETAILS

DRAWN BY: [Signature]
CHECKED BY: [Signature]
APPROVED: [Signature]
DATE: NOV. 1, 1937

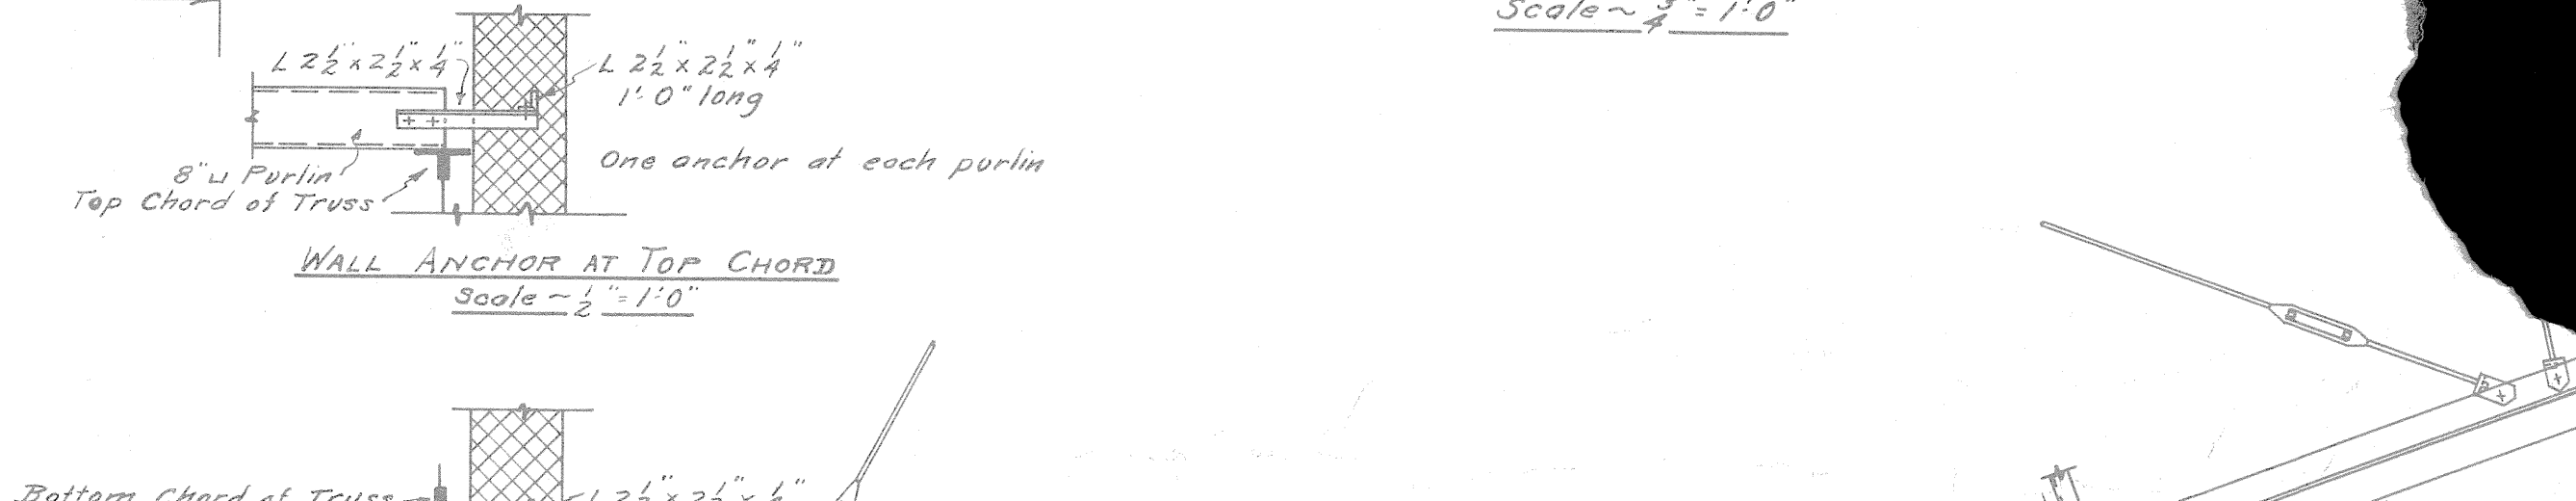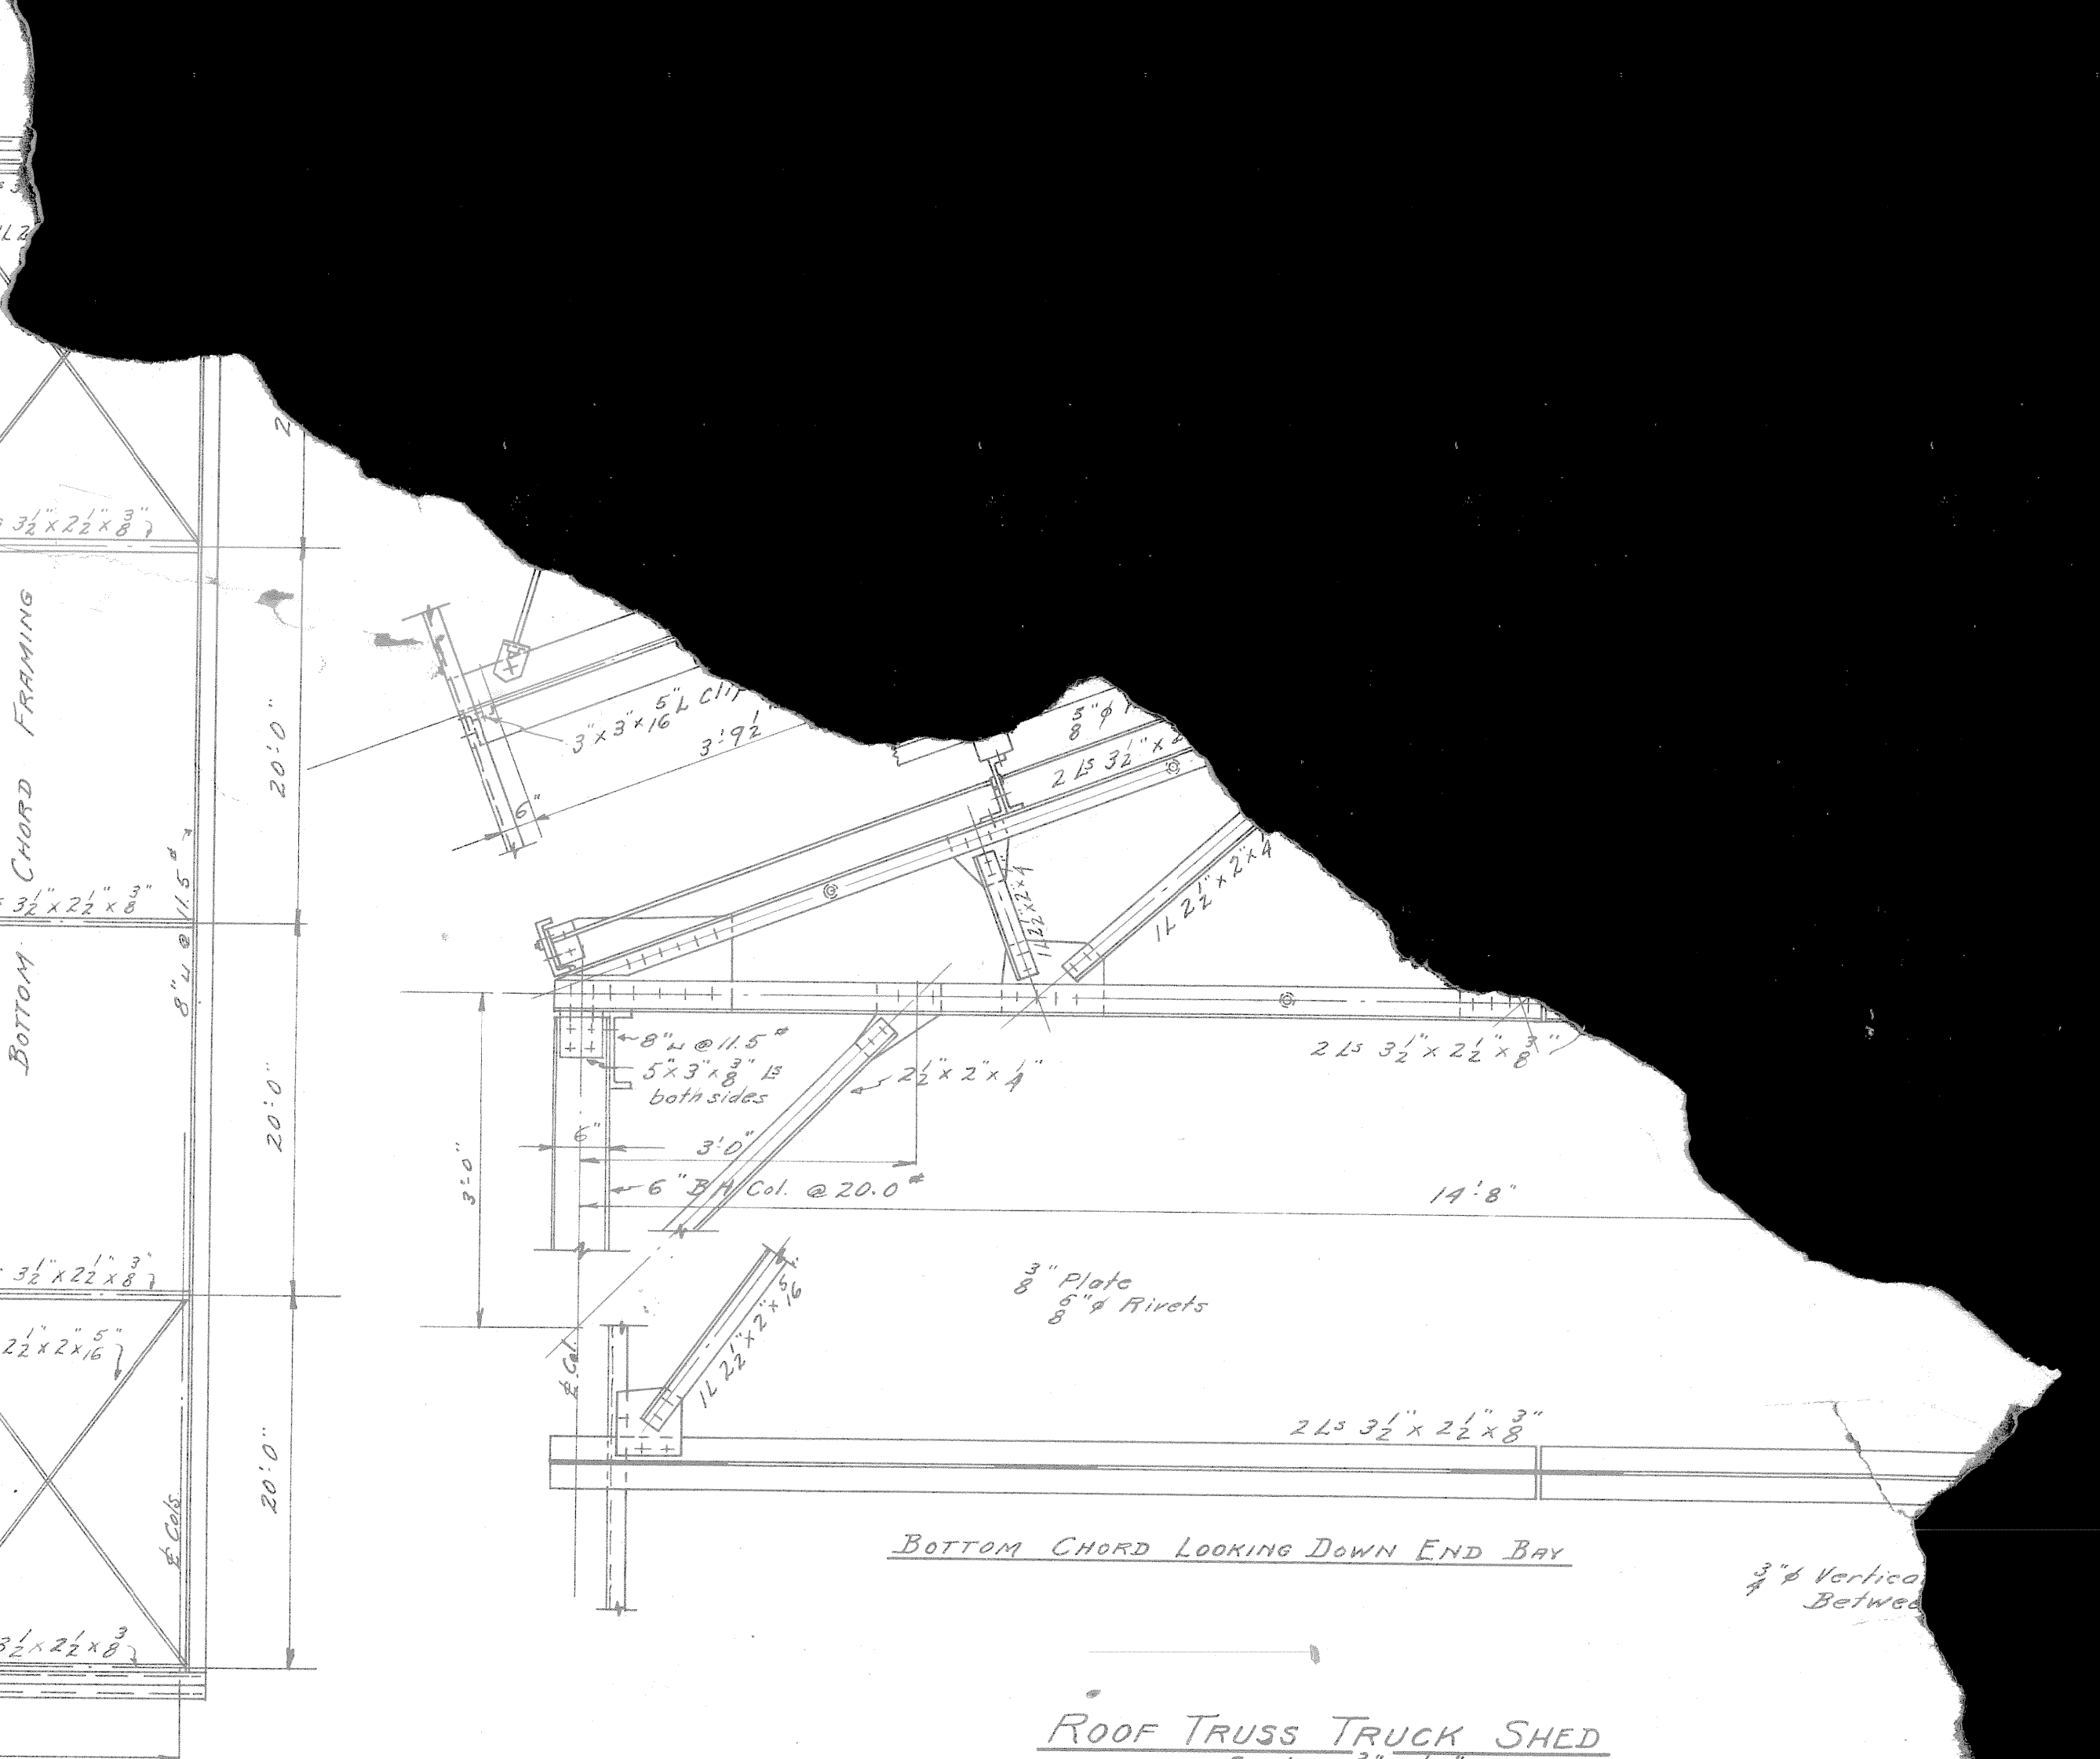

RADIATOR CONNECTIONS			
PIPE SIZE	SUPPLY		RETURN
	HORIZONTALS	VERTICALS & VALVES	
$\frac{3}{8}$ "		0 - 30 #	$\frac{1}{2}$ "
1"	0 - 26 #	31 - 56 #	$\frac{1}{2}$ "
$\frac{1}{4}$ "	27 - 58 #	57 - 122 #	$\frac{1}{2}$ "
$\frac{1}{2}$ "	59 - 95 #		

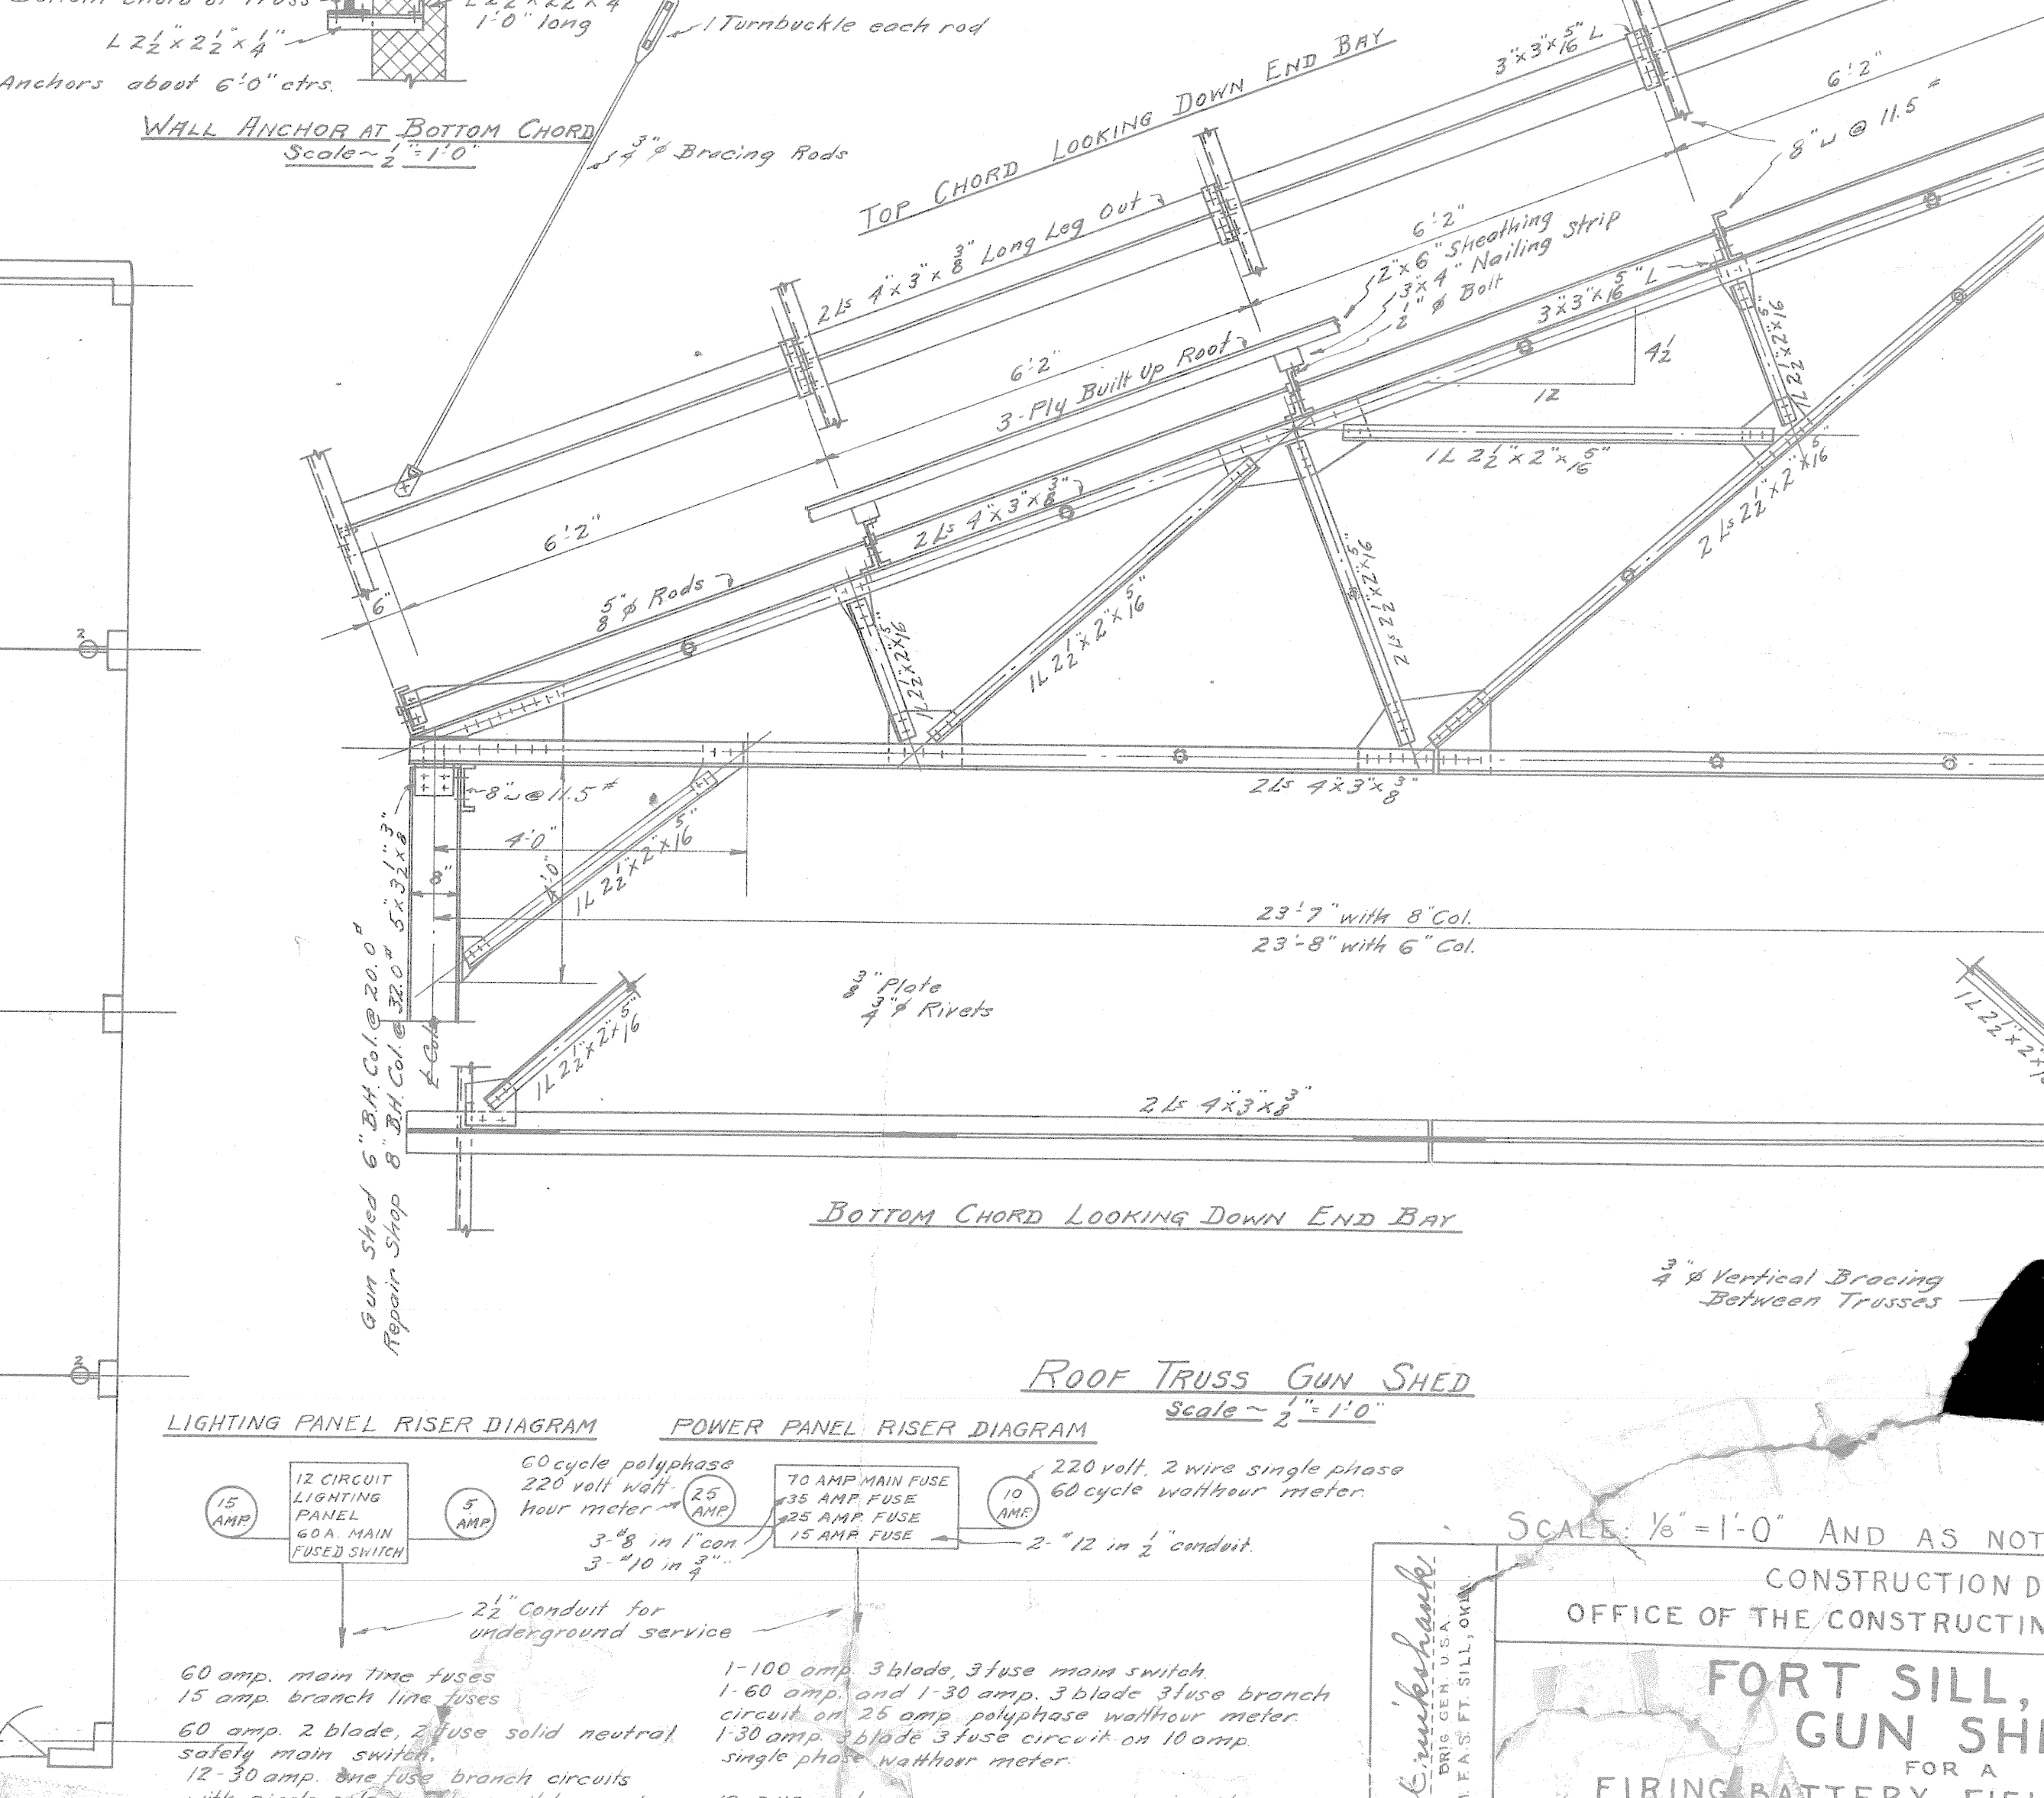

LIGHTING PANEL RISER DIAGRAM **POWER PANEL RISER DIAGRAM** Scale - 3" = 1'-0"

LIGHTING PANEL RISER DIAGRAM

- 12 AMP
- 12 CIRCUIT LIGHTING PANEL
- 40A MAIN FUSE
- 60A MAIN FUSE
- FEED SWITCH
- 2 AMP
- 60 amp main time fuse
- 15 amp branch line fuse
- 60 amp 2 blade 2 fuse solid neutral safety switch
- 12-30 amp two blade branch circuit with single pole branch switches and cartridge fuse protection

POWER PANEL RISER DIAGRAM

- 60 cycle polyphase 228 volt w/h three meter
- 12 AMP
- 40A MAIN FUSE
- 60A MAIN FUSE
- FEED SWITCH
- 2 AMP
- 1-100 amp 3 blade main switch
- 1-60 amp and 1-36 amp, 3 blade 3 phase branch circuit on 35 amp polyphase meter
- 1-30 amp 3 blade 3 fuse circuit on 10 amp single phase watt/h meter
- 12-38 amp meters gas pump on one circuit 12-18 A.C. wires in 1" conduit
- 12-18 A.C. wires to 1-12 HP and 1-14 HP meters on condensing pump (on one end) and 1-12 HP and 1-14 HP meters on water pump
- Unit ventilators and boiler control equipment to be metered on 10 amp meter
- 12-18 A.C. wires in 1" conduit

7-15-1944

SCALE: 1/8" = 1'-0" AND AS NOTED

CONSTRUCTION DIVISION
OFFICE OF THE CONSTRUCTION ENGINEER

**FORT SILL,
GUN SHIP**


FOR A
FIRING BATTERY - FIELD

**ROOF PLAN-MECHANICAL PLAN &
DRAWING**

APPROVED 10/10/40

E. S. HARRIS

DRAWN BY
TRACED BY

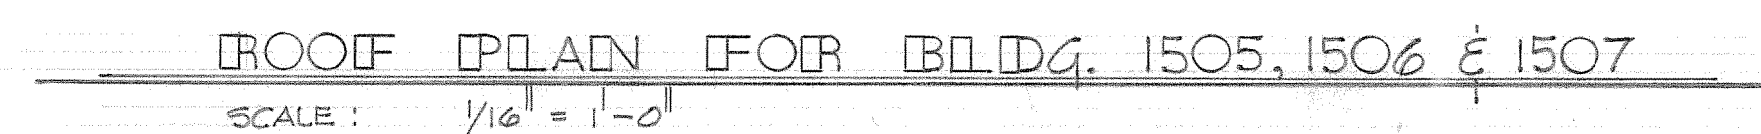

SCALE: 1/16" = 1'-0"



N.T.S.



1. REMOVE GUTTERS AND HANGERS ONLY IF REQD TO INSTALL NEW ROOFING OR WOOD SHEATHING.
2. CLEAN ALL GUTTERS OF DEBRIS AND LOOSE ROOFING AGGREGATE.



SCALE: $1/16" = 1'-0"$


$$1\frac{1}{2}'' = 1'' - 0$$


N.T.S

1506
1507

LEGEND


-  DENOTES AREAS NOT TO REROOF THIS PROJECT.

1. TAR STOP SHALL BE SET IN MASTIC AND NAILED IN PLACE.
2. PITCH ROCKET SHALL BE FORMED BY APPLYING 2 LAYERS OF ROOFING FELT BENEATH THE ROLL ROOFING WITH NOT LESS THAN 5" MOPPING ON DECK AND TURNED BACK 9" AND MOPPED OVER THE TOP ROOF PLY. THE BOTTOM LAYER OF FELT SHALL BE APPLIED IN A 9" WIDE STRIP OF BITUMINOUS CEMENT.
3. PRIME THE FLANGE OF THE GRAVEL GUARD EXTENDING ON THE ROOF WITH PRIMER AND ALLOW TO DRY THOROUGHLY.
4. THE GRAVEL GUARD SHALL BE EMBEDDED IN BITUMINOUS CEMENT AND NAILED ON TOP OF THE ENVELOPE FORMED BY THE FELT TURN BACK.
5. COVER FLANGE WITH A 6" AND A 9" WIDE STRIP OF 15 # SATURATED FELT EMBEDDED IN ASPHALT.
6. GRAVEL GUARDS AND TAR STOPS SHALL BE FABRICATED OF ZINC COATED (GALVANIZED) STEEL, 26 GA. TYPE I CLASS 10, CONFORMING TO FED. SPEC. QW-S-775. FOR BUILDING 1505, 1506, 1507 AND 2182 ONLY.
7. ALUMINUM GRAVEL GUARD/FASCIA SHALL BE REMOVED AND REINSTALLED AS DIRECTED BY THE CONTRACTING OFFICER, BLDG. 5684.
8. INSTALL ALL NEW ALUMINUM TAR STOPS TO MATCH EXISTING, BLDG. 5684.
9. THE CONTRACTOR SHALL VERIFY ALL CONDITIONS IN THE FIELD THAT WILL EFFECT HIS WORK.


DATE						
	02 AUG 76		ADDED BLDG. 3482		J.D.I.	
Revision	Date		Description		By	
Designed By: J.D.I.			DIRECTOR OF FACILITIES ENGINEERING FORT SILL, OKLAHOMA			
Drawn By: L. H. JR			REROOF BLDGS. I505, I506, I507, 2182, 3482, 8 5684			
Checked By: J.L.W. 						
Submitted By: 			ROOF PLANS AND DETAILS			
Approved:  CHIEF ENGINEER OFFICE						
Approved:  DEPUTY DIRECTOR			Approved:  DIRECTOR			COL. G.S.
SCALE: A/S		PR-P-528-75 PR-P-528-75		DATE 11 JUNE 1976		PLAN NUMBER A-76169-I

013827


10 MICROFILMED

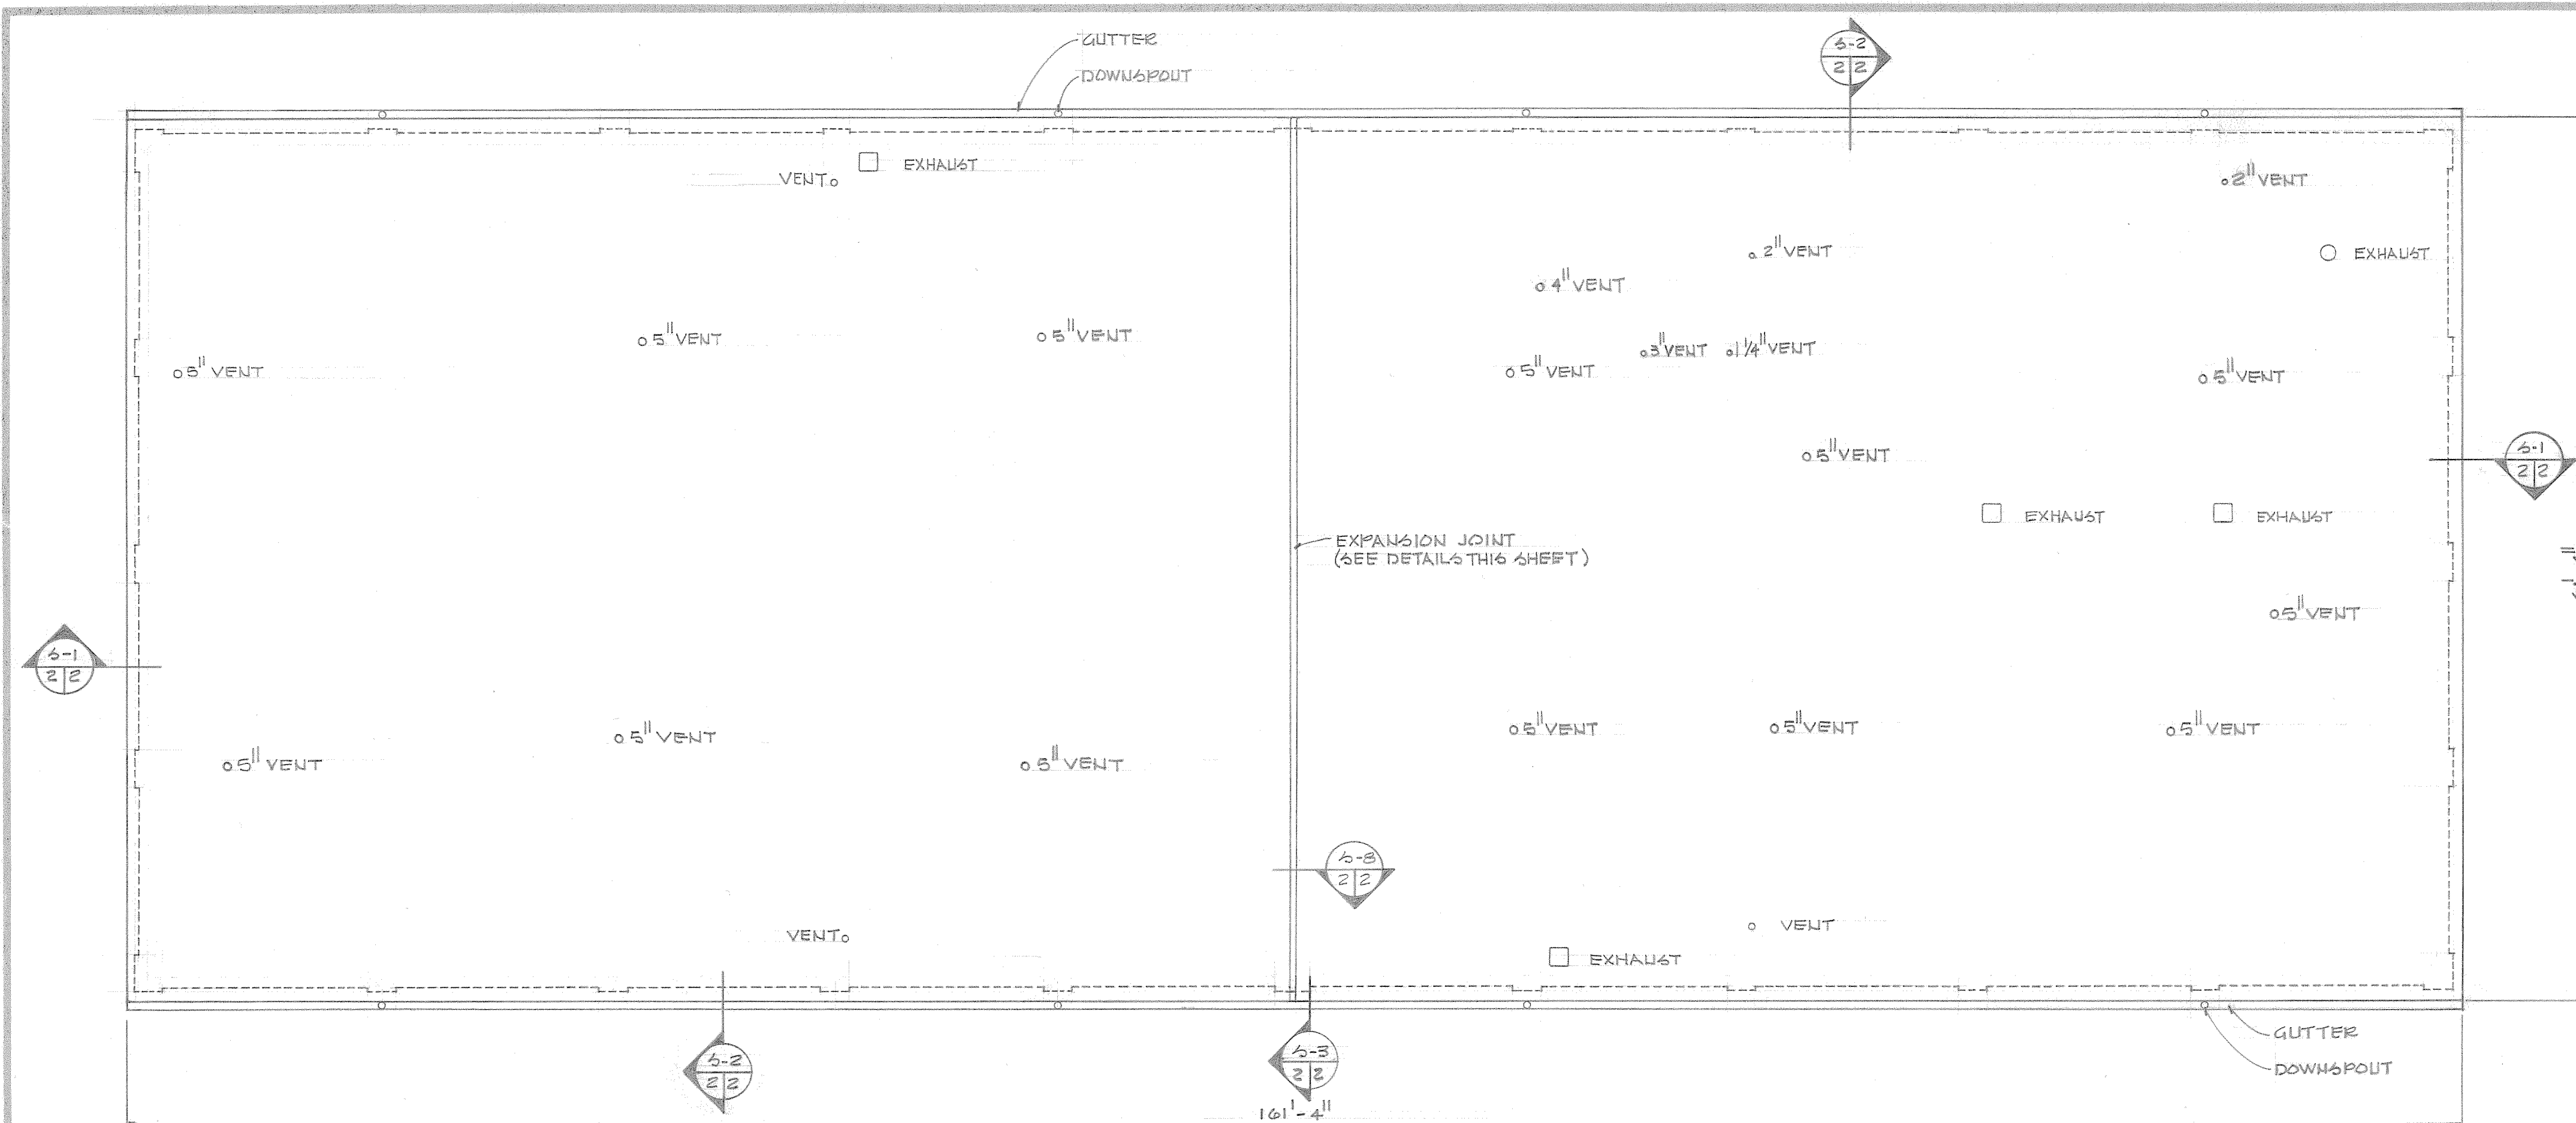


ROOF PLAN-BLDG. 3482
SCALE: 1/8"=1'-0"

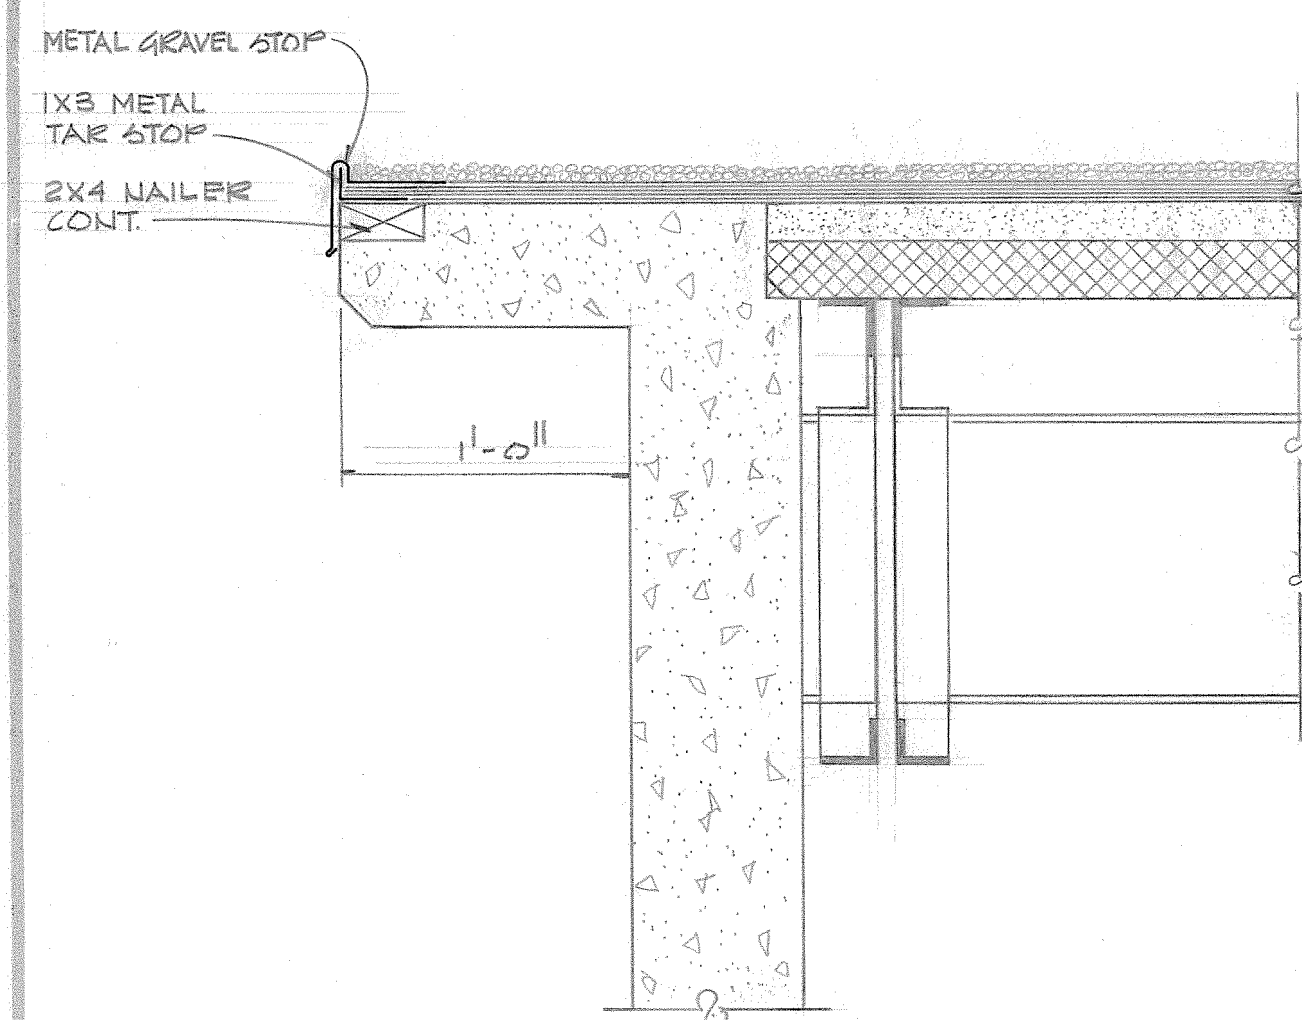


S-1 SECTION
SCALE: 1/2"=1'-0"

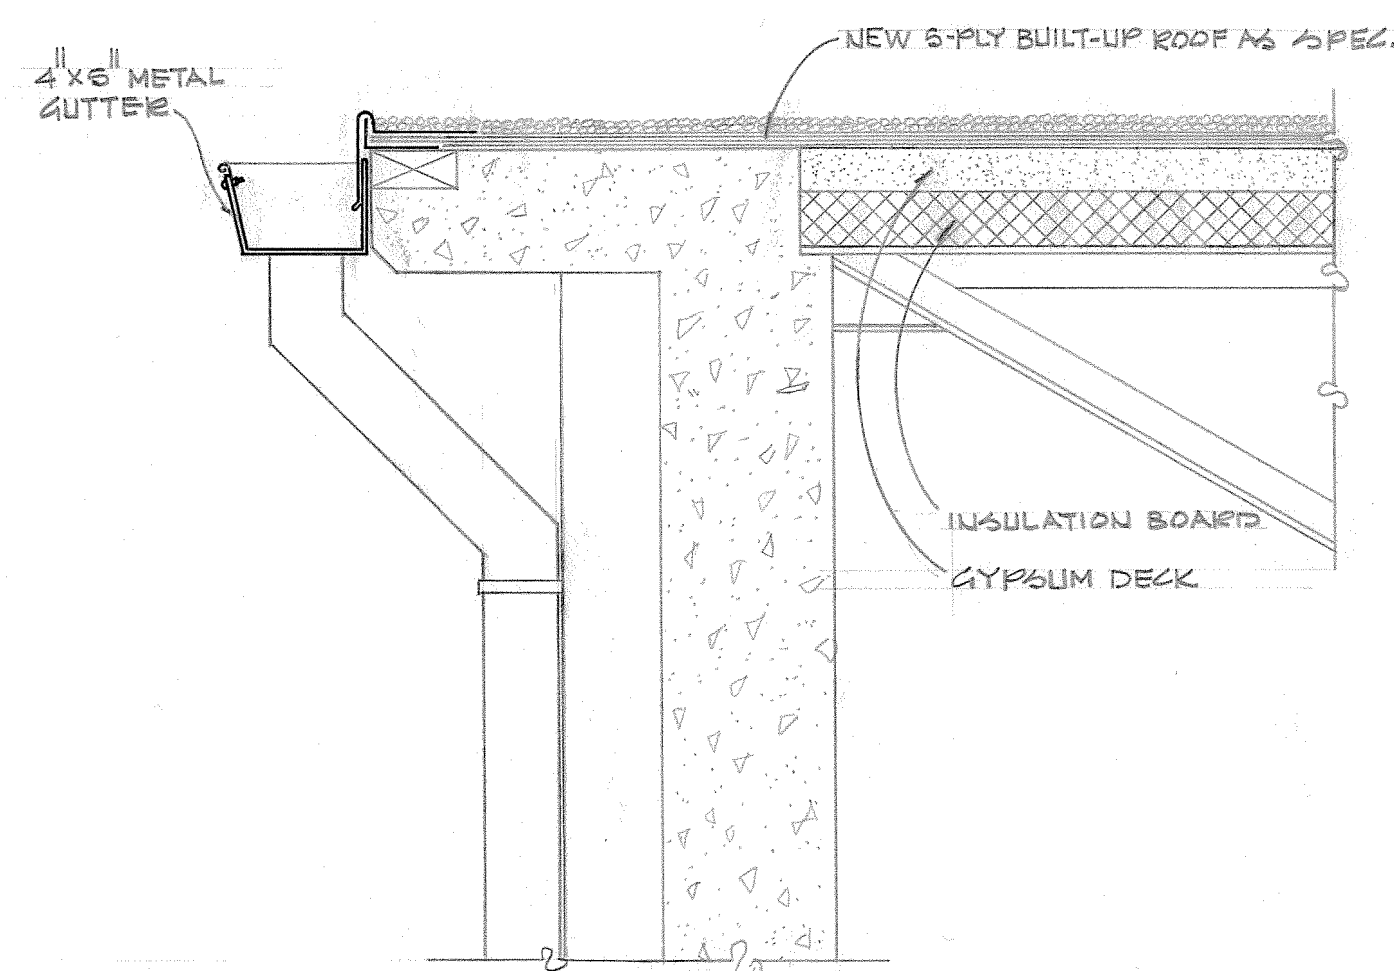

S-2 SECTION
SCALE: 1/2"=1'-0"

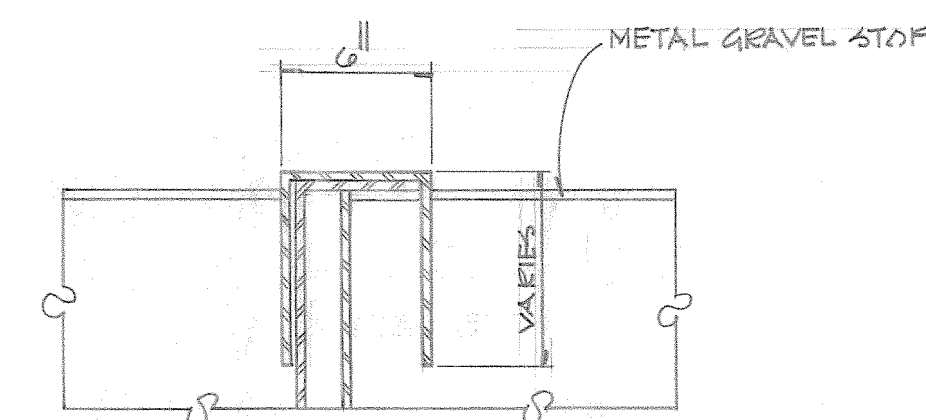


S-3 SECTION
SCALE: 1/2"=1'-0"

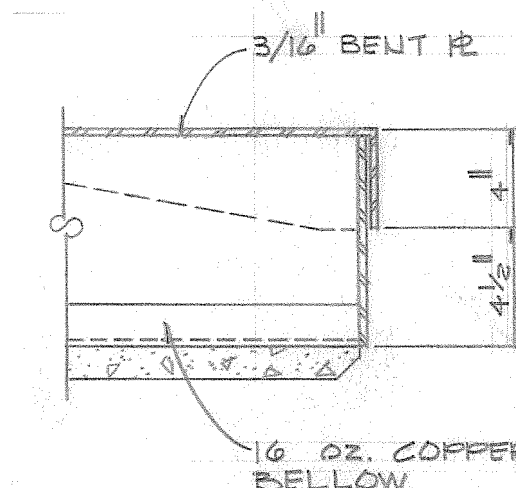


S-4 SECTION
SCALE: 1/2"=1'-0"

GENERAL NOTES:


1. REMOVE 3-PLY BUILT-UP ROOF COMPLETELY TO GYPSUM DECK.
2. INSTALL NEW GRAVEL STOPS AND TAR STOPS.
3. PROPERLY FLASH ALL ROOF VENTS AND EXHAUST FANS.
4. INSTALL NEW 5-PLY BUILT-UP ROOF AS SPECIFIED TO ENTIRE BUILDING.
5. THE CONTRACTOR SHALL VERIFY ALL CONDITIONS IN THE FIELD.

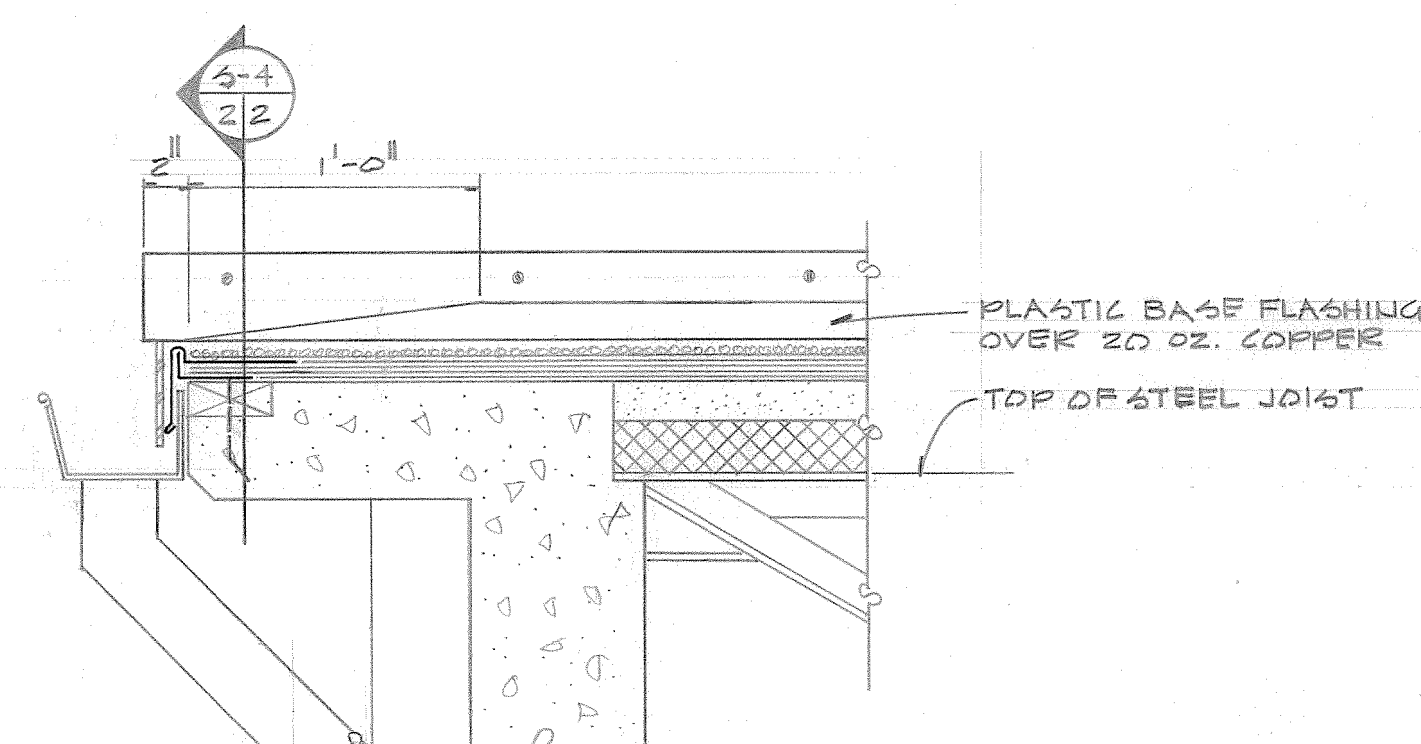


S-5 SECTION
SCALE: 1/2"=1'-0"

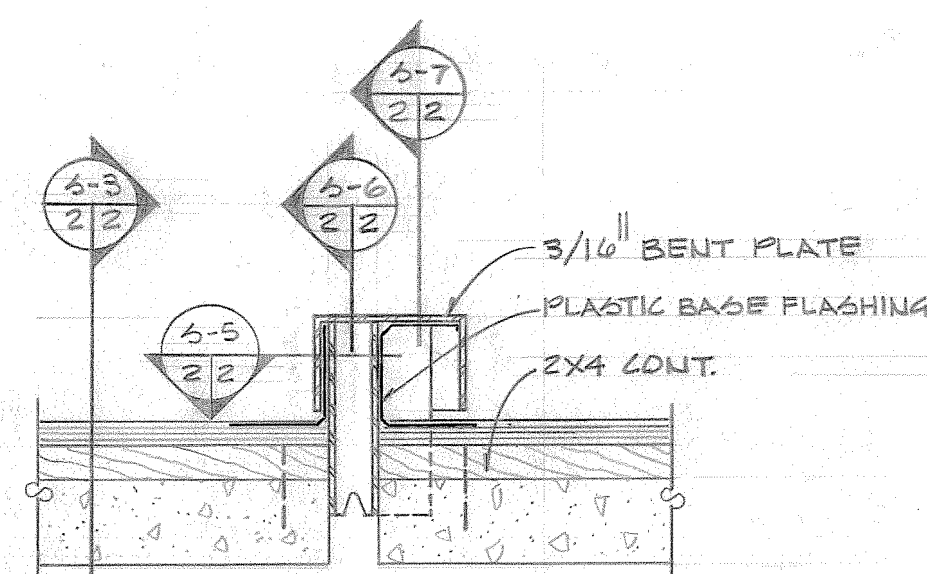

S-6 SECTION (AT OVERHANG)
SCALE: 1/2"=1'-0"

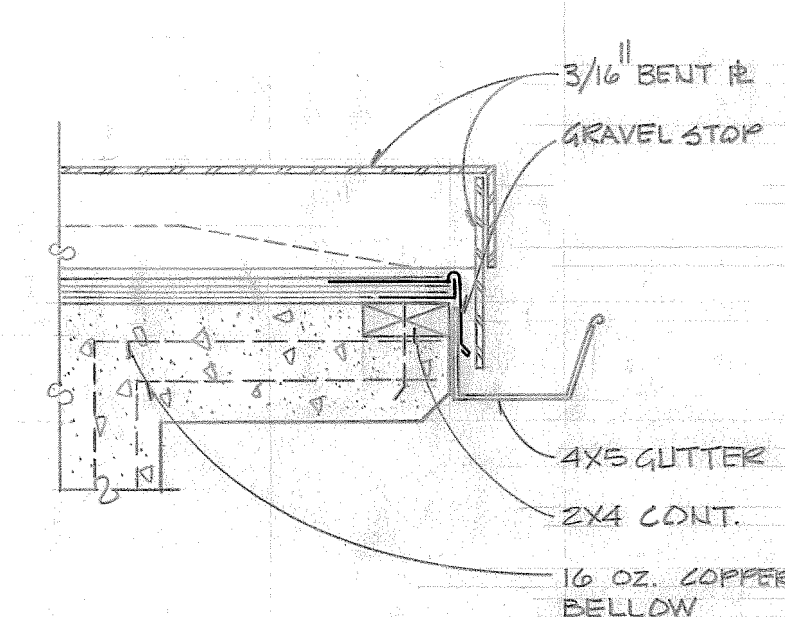

S-7 SECTION
SCALE: 1/2"=1'-0"



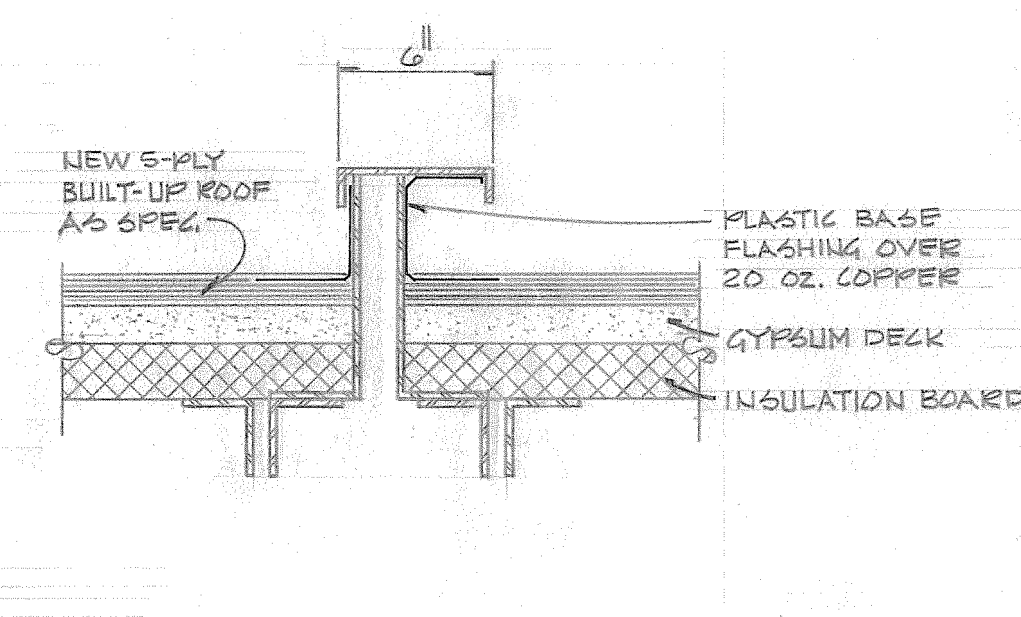


S-8 SECTION (AT STEEL JOIST)
SCALE: 1/2"=1'-0"

02 AUG 76		ADDED BLDG. 3482		J.D.I.
Revision	Date	Description	By	
Designed By:	J.D.I.	DIRECTOR OF FACILITIES ENGINEERING FORT SILL, OKLAHOMA		
Drawn By:	D.M.W.	REROOF BLDGS. 1505, 1506, 1507, 2182, 3482, 8 5684		
Submitted By:	ROOF PLAN AND DETAILS			
Approved:	Approved:		COL. R.E.	
SCALE: A/S	1567-76	11 JUNE 1976	A-76169-2	

013828



MICROFILMED
MAR 27 1987

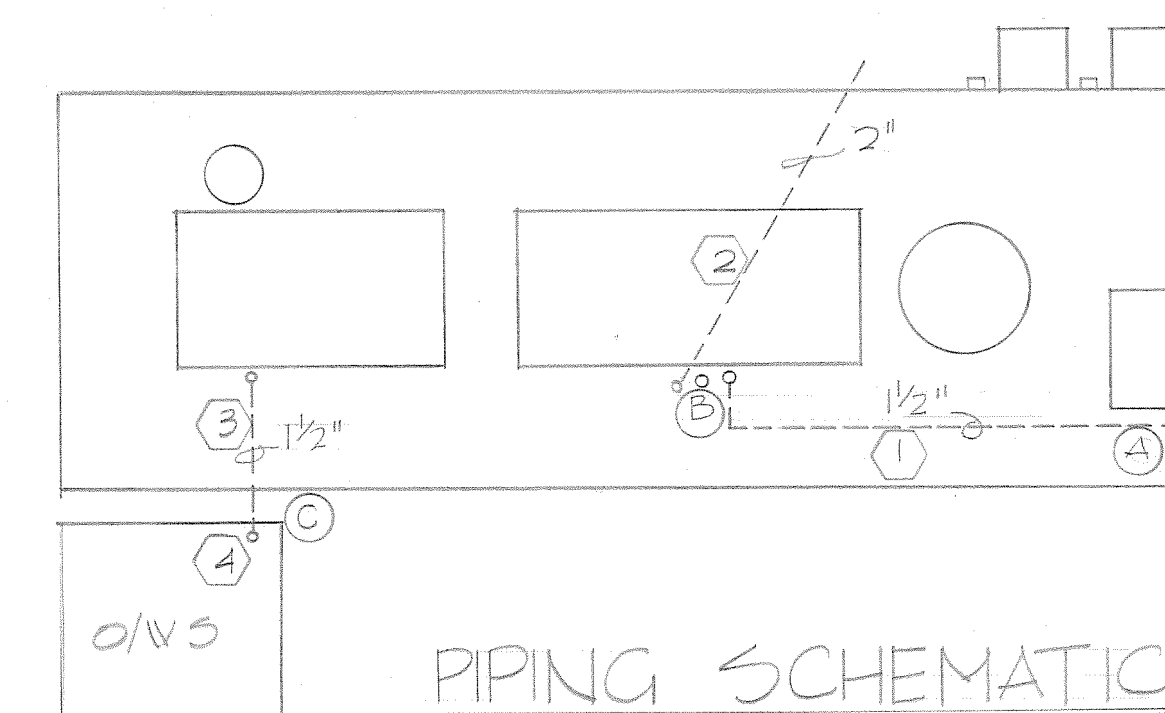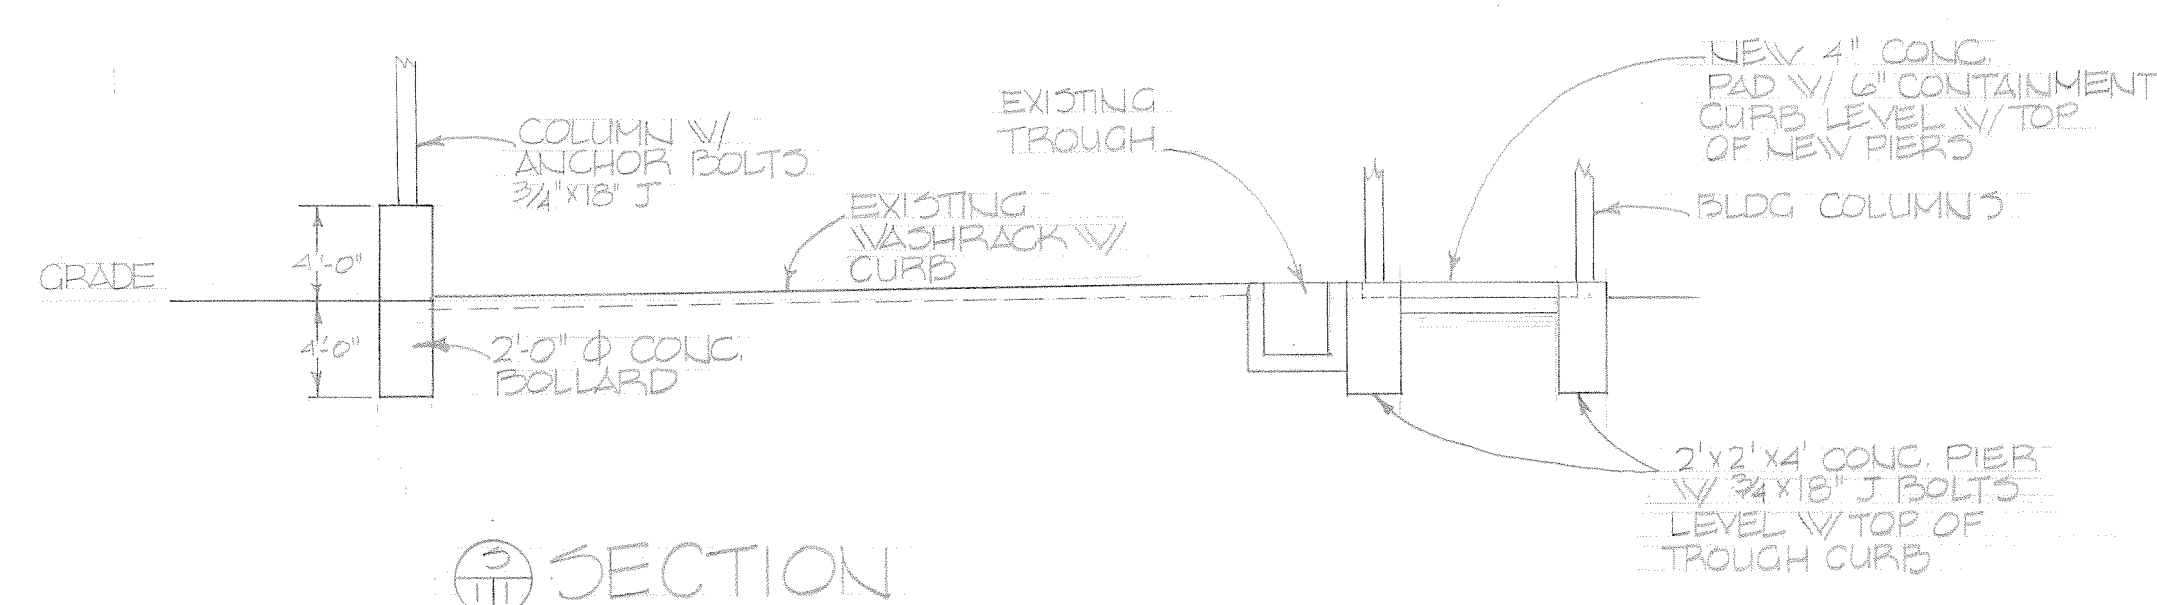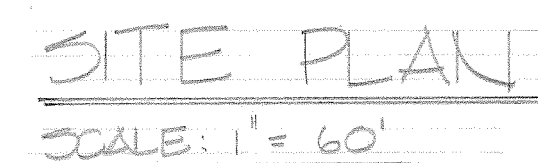

- ① RINSE WATER SUPPLY TO PRESSURE WASHER.
 - ② RINSE WATER SUPPLY TO RGF SERIES II.
 - ③ ALL EXPOSED PIPING 18" ABOVE FINISHED FLOOR.
-
- ① 1 1/2" SUPPLY LINE THROUGH CONCRETE FROM RGF SERIES II TO PRESSURE WASHER.
 - ② 2" BACKFLUSH LINE THROUGH CONCRETE FROM RGF SERIES II TO TRENCH.
 - ③ 1 1/2" COLLECTION LINE THROUGH CONCRETE FROM SUMP TO RGF SERIES I
-
- ④ ALL PIPING SHALL BE SCHEDULE 40 PVC & SHALL BE SLEEVED THROUGH CONCRETE SLAB.


AS BUILTS SUBMITTED BY
GWH / FT. SILL JOINT VENTURE, INC.

1	10-95	REVISED AS-BUILT CIVIL JOB # 427	35
REVISION	DATE	DESCRIPTION	BY
DESIGNED BY		DEPARTMENT OF THE ARMY	
DRAWN BY	JW	JOB ORDER CONTRACTING	
CHECKED BY		FORT SILL, OKLAHOMA	
SUBMITTED BY		3355 WASHBURN RENOVATION	
CHIEF, ENGR DIV		PLAN & MECHANICAL	
APPROVED		APPROVED	
DEPUTY DIRECTOR		DIRECTOR	
D.O. NUMBER	INVESTMENT NO	DATE	DRAWING NO
424	XXA000B-5P	1-9-95	JOC - 1 OF 4

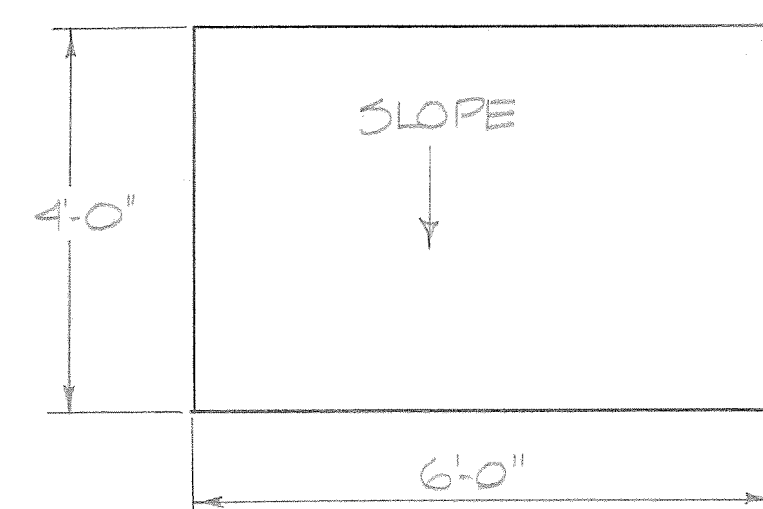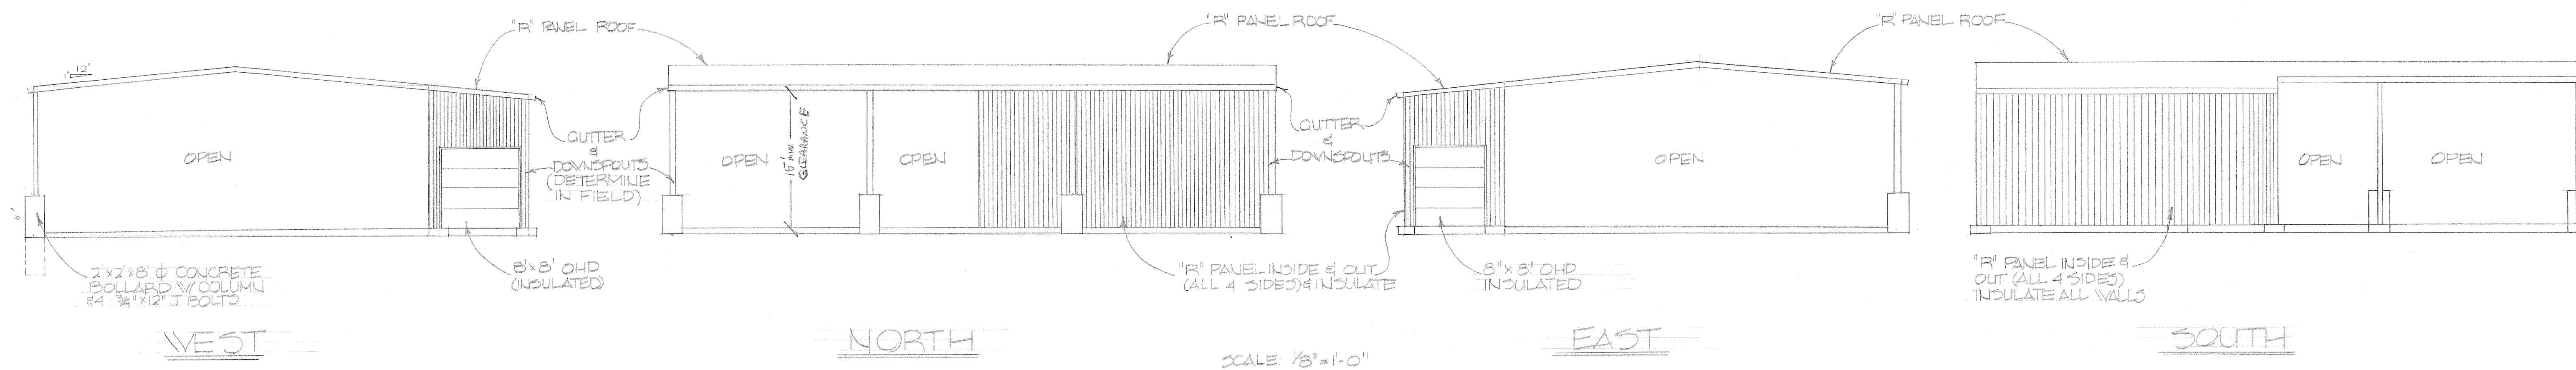

OIL/WATER SEPARATOR
PLAN

SCALE: 1/2"=1'-0"

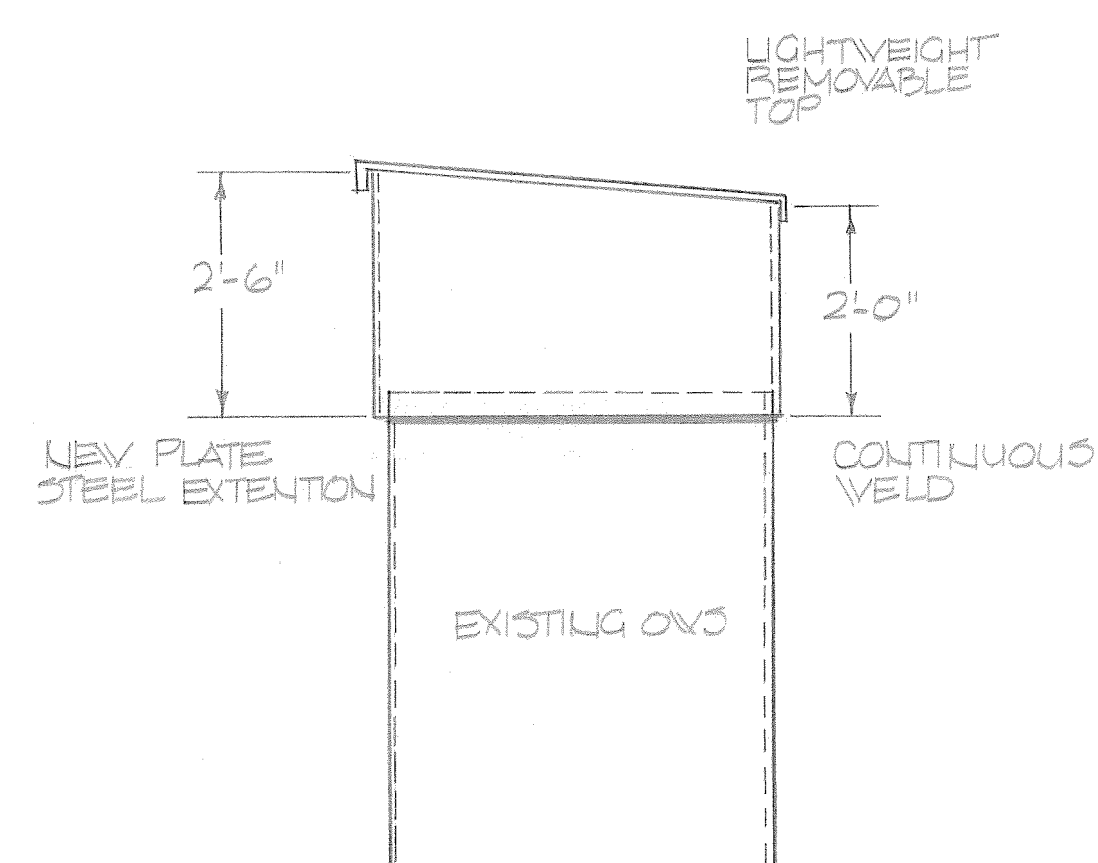

VEST ELEVATION

AS BUILTS SUBMITTED BY
GWH / FT. SILL JOINT VENTURE, INC.

REVISION	DATE	DESCRIPTION	BY
1	1-19-95	ADDED CONC. BOLLARDS	
DESIGNED BY		DEPARTMENT OF THE ARMY JOB ORDER CONTRACTING FORT SILL, OKLAHOMA	
DRAWN BY	SIV		
CHECKED BY		WASHRACK 3355	
SUBMITTED BY		ELEVATION 3	
CHIEF, ENGR DIV			
APPROVED		APPROVED	
DEPUTY DIRECTOR		DIRECTOR	COL CE
D.O. NUMBER	INVIATION NO	DATE	DRAWING NO
		1-19-95	JOC - 2 OF 4

ZC24 300171JOCES.DGN
GONNERMB
17-JAN-1995 09:02

P-28

499-2 5-18

