

NEW 60'X120'X16' BUILDING FOR:

EASTBROOK SCHOOLS

MONROE TOWNSHIP, GRANT COUNTY INDIANA

THIS DOCUMENT IS TO SERVE FOR "NEW" STRUCTURE DOCUMENTED
HERE-IN ONLY AT ADDRESS LISTED. ALL OTHER STRUCTURAL AND CIVIL
DESIGN OUTSIDE OF THE SCOPE OF THESE DRAWINGS BY OTHERS.



BUILDING DATA

BUILDING USE: STORAGE GARAGE
OCCUPANCY GROUP: MULTI-USE (S-1, M, B)
CONSTRUCTION TYPE: VB - 0 HOUR RATING
HEIGHT ALLOWED: 40'-0"
ACTUAL HEIGHT: 27' 6"
AREA ALLOWED: 15,750 SQ. FT.
BUILDING AREA: 13,783 SQ. FT.
13,783 < 15,750

SHEET LIST	
SHEET NUMBER	SHEET NAME
T01	COVER PAGE
C01	SITE PLAN
C02	EXISTING CONDITIONS/DEMO PLAN
C03	DRAINAGE PLAN
C04	EROSION CONTROL - PRE CONSTRUCTION
C05	EROSION CONTROL - POST CONSTRUCTION
C06	SECTION VIEWS & DETAILS
F01	FOUNDATION PLAN
F02	CONCRETE NOTES
A01	FLOOR PLAN
A02	FIRE & LIFE SAFETY PLAN
A03	FLOOR PLAN - MAIN FLOOR CALLOUTS
A04	BUILDING SECTION VIEWS AND DETAILS
A05	RESTROOM AND STAIR SECTION VIEWS
A06	STAIR DETAILS
A07	LOFT - FLOOR FRAMING PLAN
A08	ROOF FRAMING PLAN
A09	ELEVATIONS
M01	MECHANICAL PLAN
E01	ELECTRICAL PLAN
P01	PLUMBING PLAN
P02	PLUMBING ISOMETRICS
P03	PLUMBING ISOMETRIC DETAILS
P04	PLUMBING FIXTURE SCHEDULE
G01	MEP NOTES



DESIGN LOADS

BUILDING CODE:
2012 INTERNATIONAL BUILDING CODE
2014 INDIANA BUILDING CODE

- A) GROUND SNOW (p/g).....20 PSF
- B) ROOF LOADS:

I) ROOF LIVE.....20 PSF

II) DEAD LOAD.....12 PSF

i) TOP CHORD.....5 PSF

ii) BOTTOM CHORD.....5 PSF

III) COLLATERAL LOAD.....2 PSF
- C) FLOOR LOADS:

I) LIVE LOAD:

i) STORAGE AREAS.....125 PSF

ii) GARAGE.....125 PSF

iii) LOFT.....60 PSF

II) DEAD LOAD:


i) GARAGE.....10 PSF

ii) LOFT.....10 PSF
- D) WIND LOAD:

115 MPH

CAT. II

EXPOSURE C

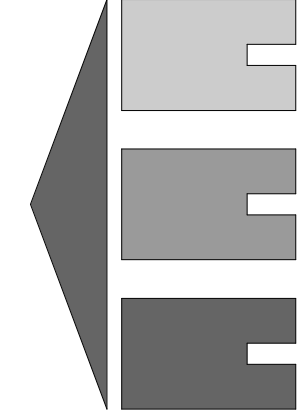

MSS Engineering, LLC


ENGINEERING, CONSULTING & DESIGN

414 W 5th St., Auburn, IN 46706

Phone: (260) 267-7414

Email: tamcdaniel@mssengineer.com

Travis A. McDaniel, PE

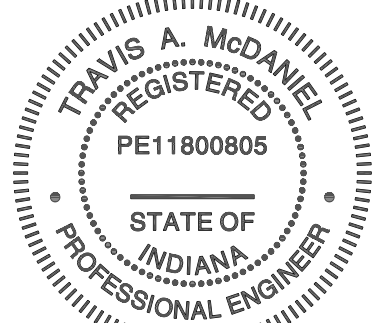

Travis A. McDaniel

05/26/23

PROJECT LOCATION:

560 S 900 E

MARION, IN 46953

PROJECT NAME:

BID SPEC & DESIGN

DRAWING TITLE:

COVER PAGE

REVISIONS:

NO.	DATE	DESCRIPTION	BY
-----	------	-------------	----

JOB NUMBER:

22.081.171

DRAWN BY:

CAS

ENGINEERED BY:

CAS

START DATE:

05/12/21

PROGRESS DATE:

7/13/21

CERTIFIED DATE:

05/26/23


SCALE:

PAGE NUMBER:

T01 OF T01 SHEETS


REV.

NOTE: DIMENSIONS ARE APPROXIMATE. REFER TO PROFESSIONAL SURVEY FOR PRECISE LOT LINE LAYOUT. INFORMATION PROVIDED GATHERED FROM PUBLIC RECORDS.

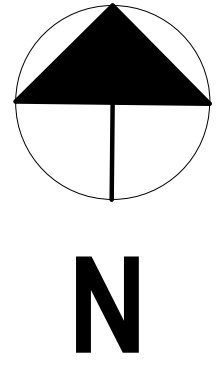

1
APPROXIMATE SHIPPING/MATERIAL LAYDOWN AREA(S). MUST COORDINATE WITH WATER TREATMENT PROJECT LAYDOWN AREAS BY OTHERS

EXISTING BUILDING TO BE REMOVED & REPLACED WITH NEW 60'X120'X16' BUILDING

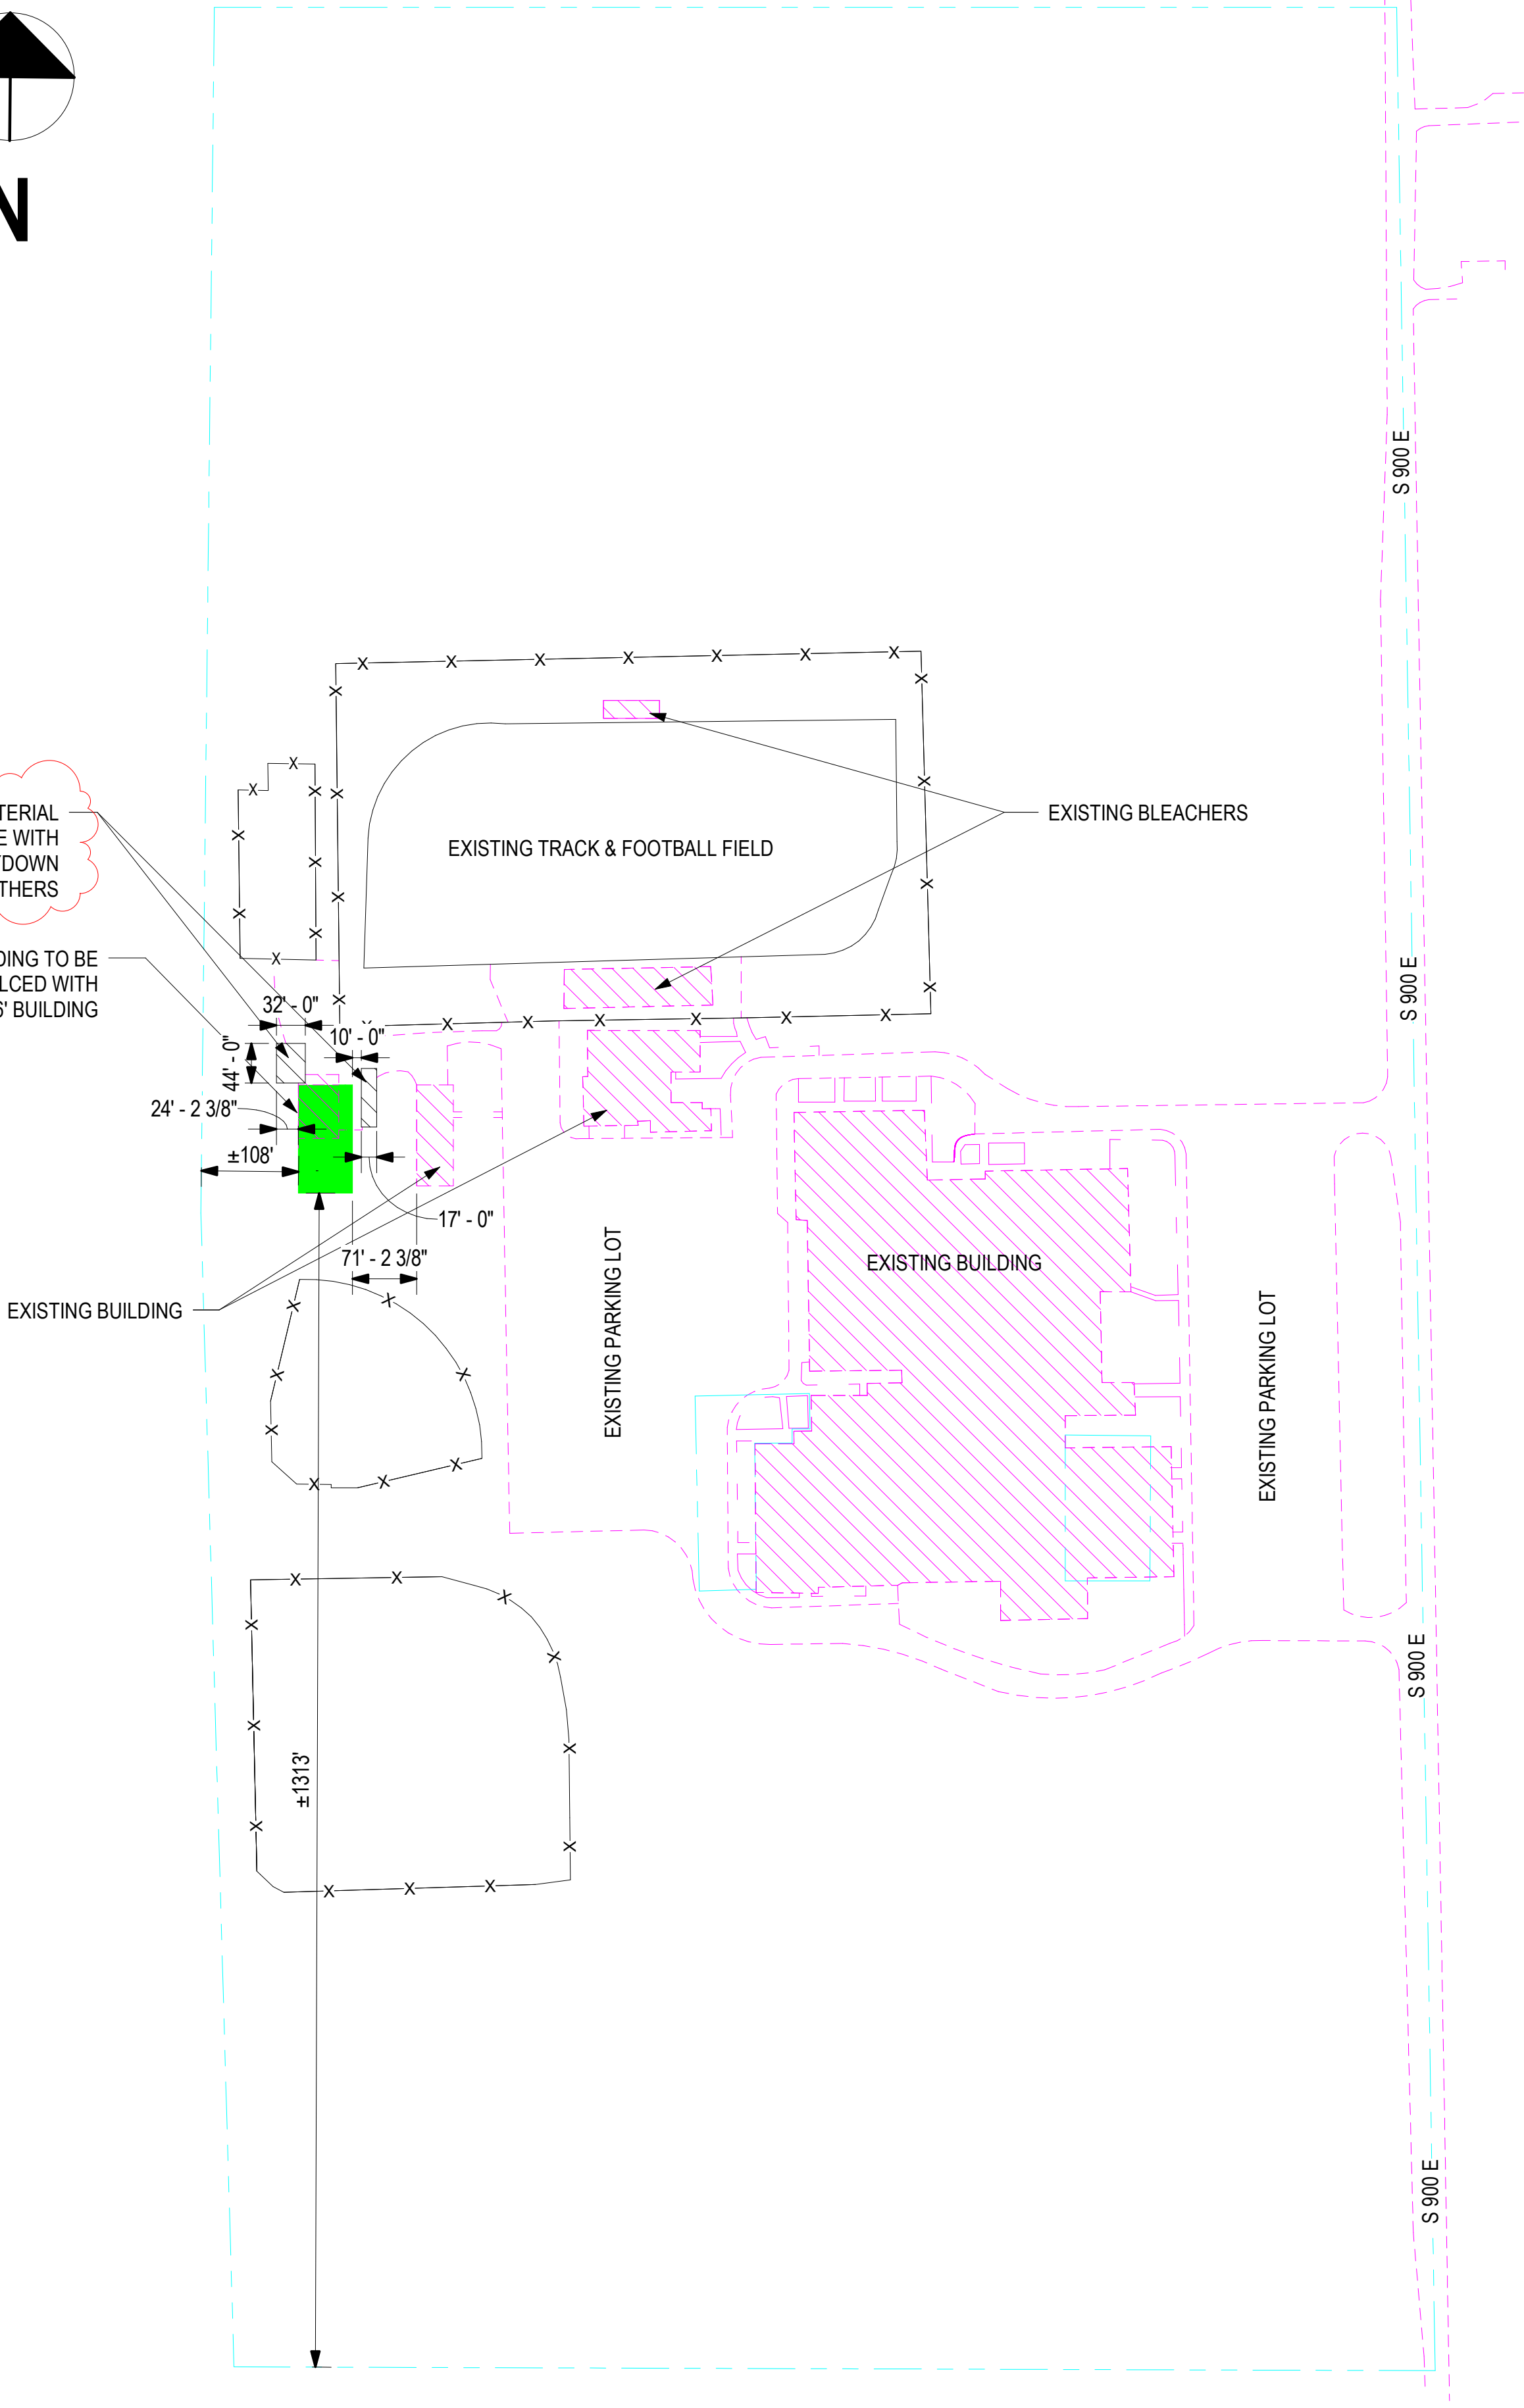

LINETYPE LEGEND

	NEW BUILDING
	EXISTING BUILDING
	PROPERTY LINE
	SETBACK
	SURFACE EDGE
	PARKING LOT LINE
	FENCE
	SOIL REGION
	DEMO
	OVERHEAD
	TELECOM/DATA
	SWALE
	ELECTRIC
	GAS PIPE
	WATER PIPE
	SANITARY PIPE
	STORM PIPE
	EROSION CONTROL
	LINE OF DISTURBANCE
	NATIONAL POLLUTION DISCHARGE ELIMINATION SYSTEM BOUNDARY
	PROPOSED CONTOUR
	EXISTING CONTOUR
	EXISTING ELECTRIC
	EXISTING GAS PIPE
	EXISTING WATER PIPE
	EXISTING STORM PIPE
	EXISTING SANITARY PIPE
	EXISTING FENCE

LINETYPE LEGEND
1" = 20'-0"

REGION LEGEND

	NEW BUILDING
	EXISTING BUILDING
	DRIVEWAY/SIDEWALKS/ROADS
	WATER
	RIP RAP
	TEMPORARY SEEDING
	PERMANENT SEEDING

REGION LEGEND
1/4" = 1'-0"


SYMBOL LEGEND

	MANHOLE
	DRYWELL
	SANITARY SEWER CLEANOUT
	WATER VALVE
	GAS VALVE
	FIRE HYDRANT
	SPOT ELEVATION
	DECIDUOUS TREE
	CONIFEROUS TREE

SYMBOL LEGEND
1/4" = 1'-0"

1 SITE PLAN
1" = 140'-0"

MSS Engineering, LLC
ENGINEERING, CONSULTING & DESIGN
414 W 5th St., Auburn, IN 46706
Phone: (260) 267-7414
Email: tamcdaniel@mssengineer.com
Travis A. McDaniel, PE

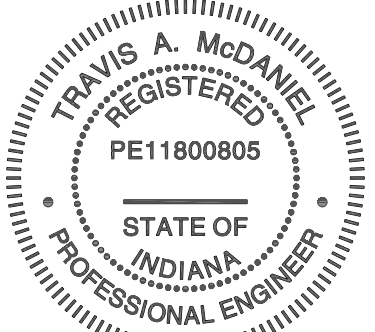

Travis A. McDaniel
05/26/23

PROJECT LOCATION:
560 S 900 E
MARION, IN 46953

PROJECT NAME:
BID SPEC &
DESIGN

DRAWING TITLE:
SITE PLAN

REVISIONS:

NO.	DATE	DESCRIPTION	BY
1	5/26/23	SITE PLAN UPDATES	TAM

JOB NUMBER:
22.081.171

DRAWN
BY: CAS

ENGINEERED
BY: CAS

START DATE: 05/12/21

PROGRESS DATE: 7/13/21



CERTIFIED DATE: 05/26/23

SCALE: As indicated

PAGE NUMBER:

C01 OF C06 SHEETS

REV. 1

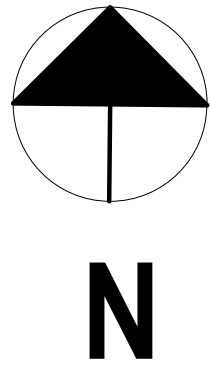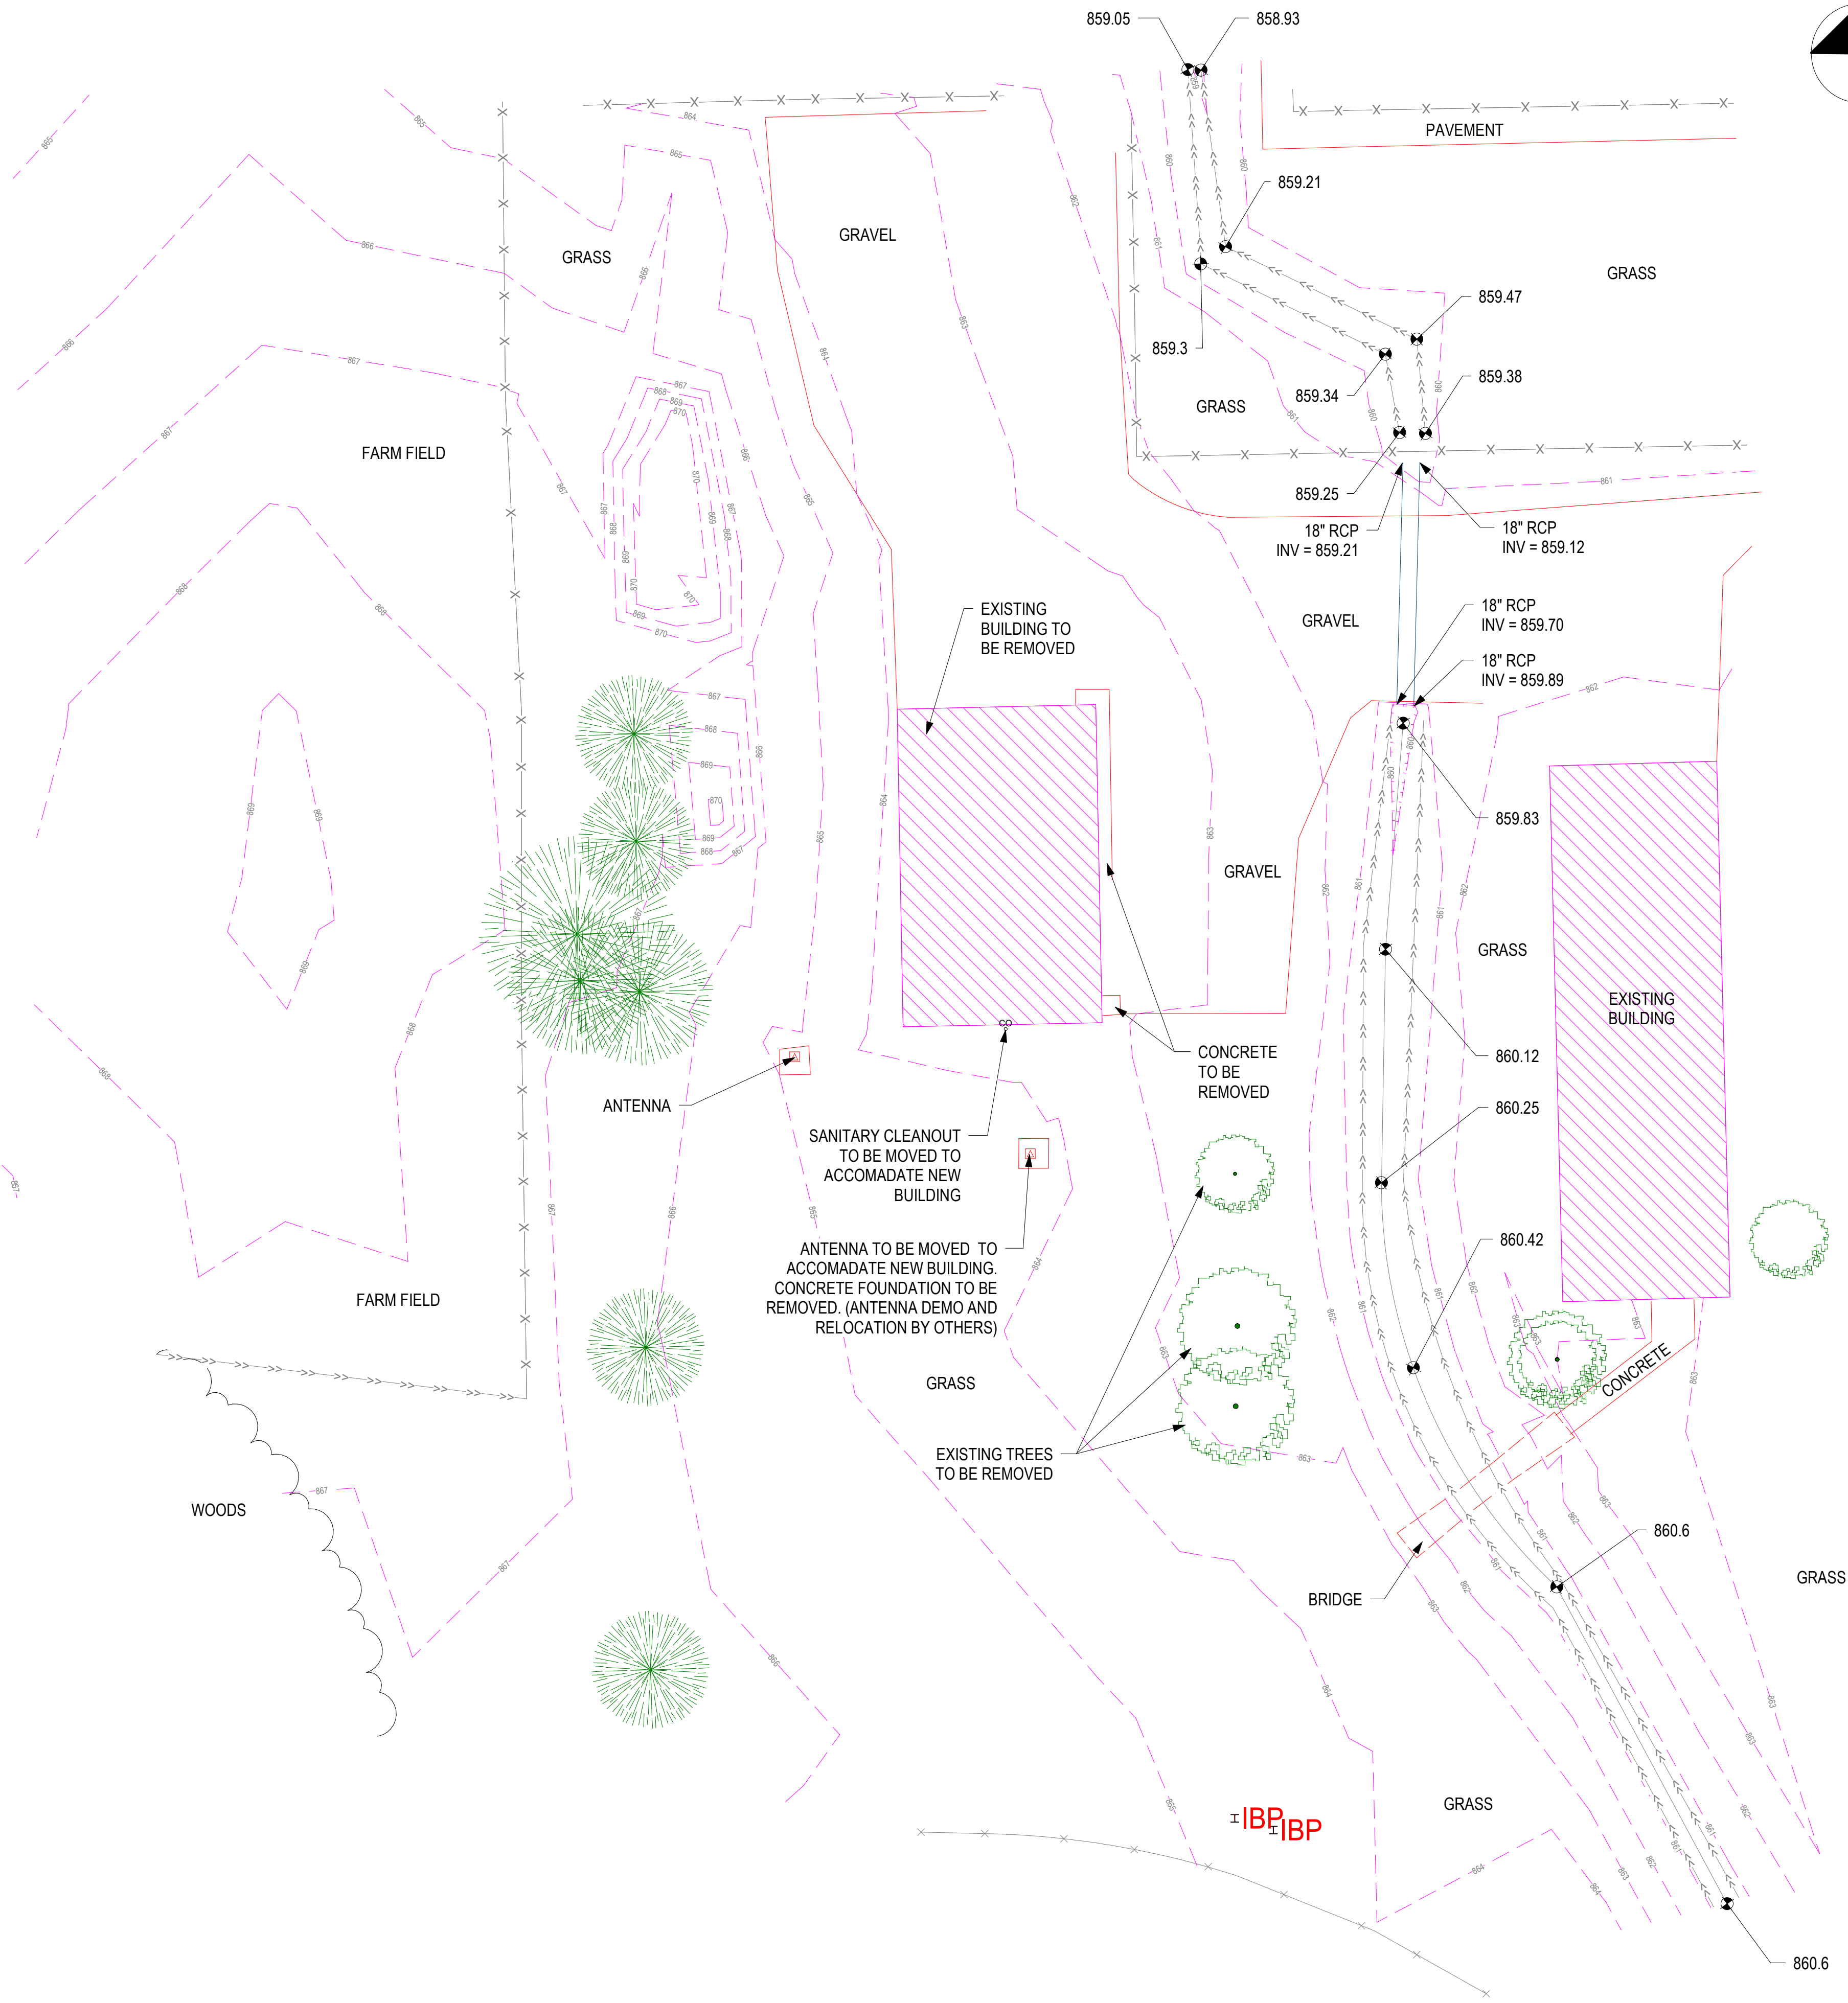

LINETYPE LEGEND	
	NEW BUILDING
	EXISTING BUILDING
	PROPERTY LINE
	SETBACK
	SURFACE EDGE
	PARKING LOT LINE
	FENCE
	SOIL REGION
	DEMO
	OVERHEAD
	TELECOM/DATA
	SWALE
	ELECTRIC
	GAS PIPE
	WATER PIPE
	SANITARY PIPE
	STORM PIPE
	EROSION CONTROL
	LINE OF DISTURBANCE
	NATIONAL POLLUTION DISCHARGE ELIMINATION SYSTEM BOUNDARY
	PROPOSED CONTOUR
	EXISTING CONTOUR
	EXISTING ELECTRIC
	EXISTING GAS PIPE
	EXISTING WATER PIPE
	EXISTING STORM PIPE
	EXISTING SANITARY PIPE
	EXISTING FENCE

1" = 20'-0"

REGION LEGEND	
	NEW BUILDING
	EXISTING BUILDING
	DRIVEWAY/SIDEWALKS/ROADS
	WATER
	RIP RAP
	TEMPORARY SEEDING
	PERMANENT SEEDING

1/4" = 1'-0"

SYMBOL LEGEND	
	MANHOLE
	DRYWELL
	SANITARY SEWER CLEANOUT
	WATER VALVE
	GAS VALVE
	FIRE HYDRANT
	SPOT ELEVATION
	DECIDUOUS TREE
	CONIFEROUS TREE

1/4" = 1'-0"



MSS Engineering, LLC
ENGINEERING, CONSULTING & DESIGN
414 W 5th St., Auburn, IN 46706
Phone: (260) 267-7414
Email: tamcdaniel@mssengineer.com
Travis A. McDaniel, PE

Travis A. McDaniel
05/26/23

PROJECT LOCATION: 560 S 900 E MARION, IN 46953	
PROJECT NAME: BID SPEC & DESIGN	DRAWING TITLE: EXISTING CONDITIONS/DEMO PLAN

REVISIONS:			
NO.	DATE	DESCRIPTION	BY

JOB NUMBER: 22.081.171	
DRAWN BY: CAS	ENGINEERED BY: CAS
START DATE: 05/12/21	
PROGRESS DATE: 7/13/21	
CERTIFIED DATE: 05/26/23	
SCALE: As indicated	
PAGE NUMBER:	
C02 OF C06 SHEETS	REV.

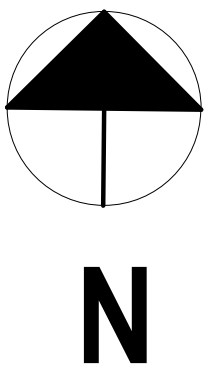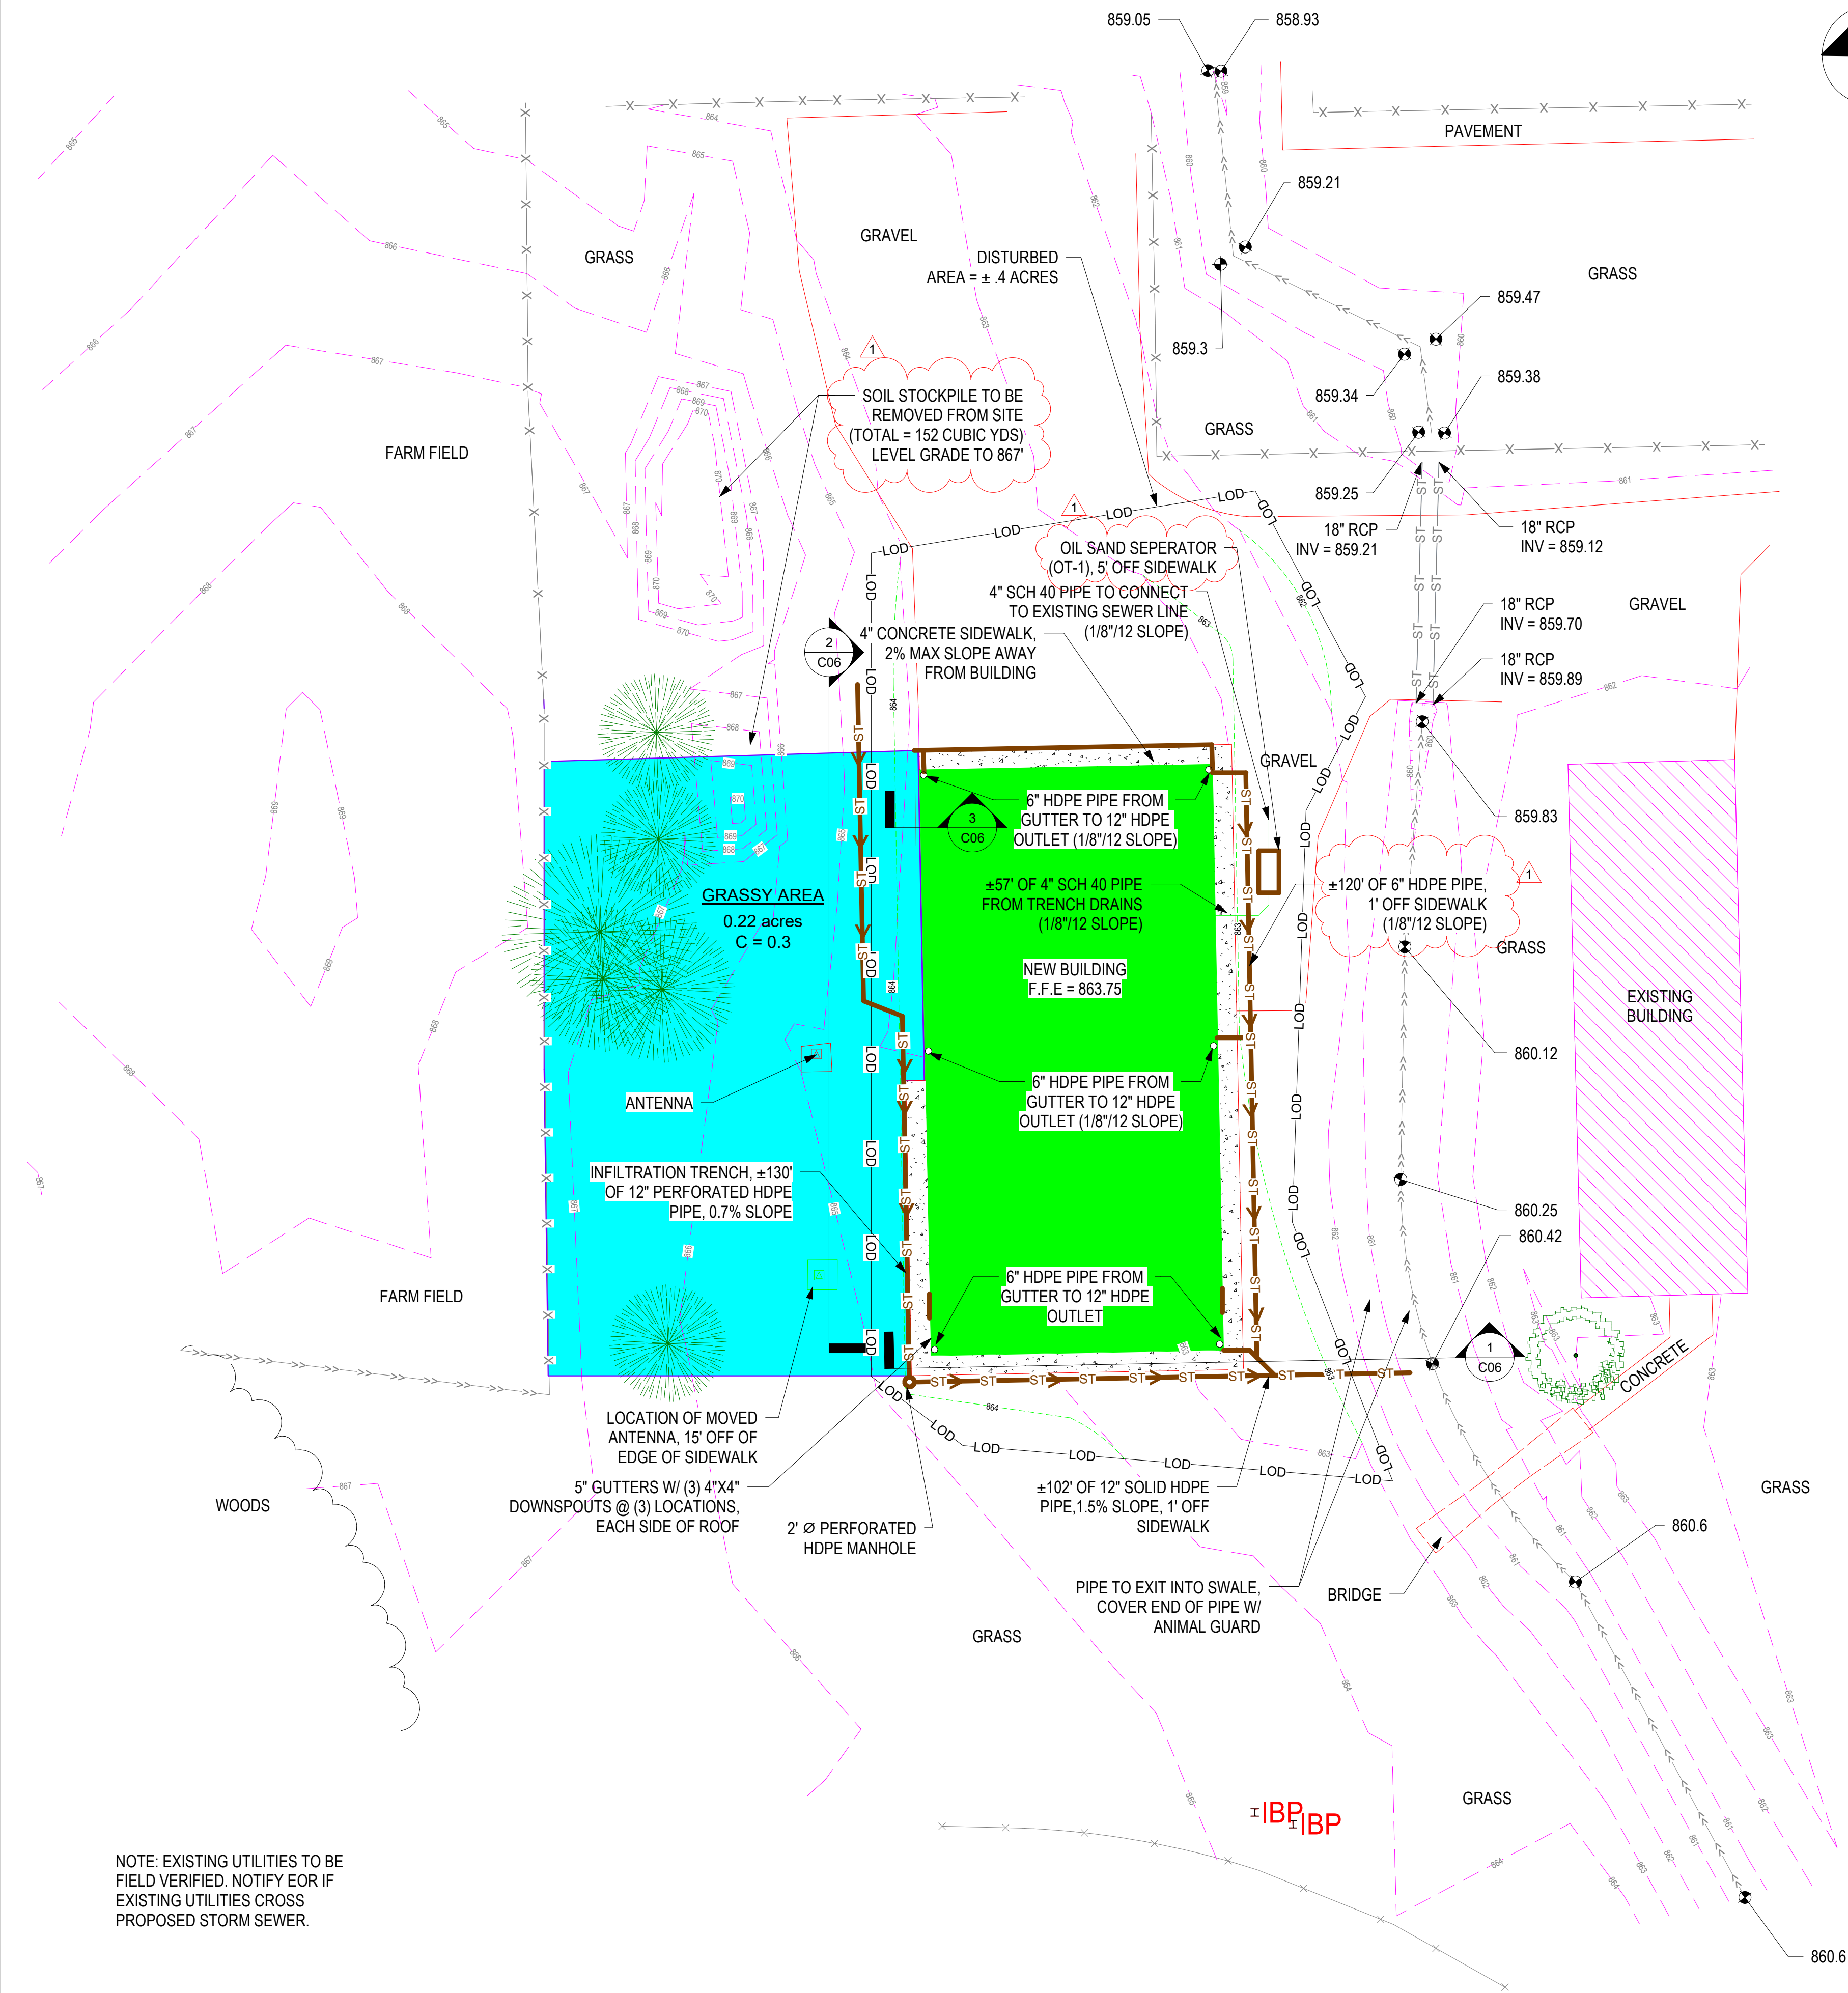

LINETYPE LEGEND

---	NEW BUILDING
---	EXISTING BUILDING
---	PROPERTY LINE
---	SETBACK
---	SURFACE EDGE
---	PARKING LOT LINE
---	FENCE
---	SOIL REGION
---	DEMO
---	OVERHEAD
---	TELECOM/DATA
---	SWALE
---	ELECTRIC
---	GAS PIPE
---	WATER PIPE
---	SANITARY PIPE
---	STORM PIPE
---	EROSION CONTROL
---	LINE OF DISTURBANCE
---	NATIONAL POLLUTION DISCHARGE ELIMINATION SYSTEM BOUNDARY
---	PROPOSED CONTOUR
---	EXISTING CONTOUR
---	EXISTING ELECTRIC
---	EXISTING GAS PIPE
---	EXISTING WATER PIPE
---	EXISTING STORM PIPE
---	EXISTING SANITARY PIPE
---	EXISTING FENCE

○ LINETYPE LEGEND
1" = 20'-0"

SYMBOL LEGEND

- MANHOLE
- DRYWELL
- SANITARY SEWER CLEANOUT
- WATER VALVE
- GAS VALVE
- FIRE HYDRANT
- SPOT ELEVATION
- DECIDUOUS TREE
- CONIFEROUS TREE

○ SYMBOL LEGEND
1/4" = 1'-0"

REGION LEGEND

- NEW BUILDING
- EXISTING BUILDING
- DRIVEWAY/SIDEWALKS/ROADS
- WATER
- RIP RAP
- TEMPORARY SEEDING
- PERMANENT SEEDING

○ REGION LEGEND
1/4" = 1'-0"

DRAINAGE CALCULATIONS

GOVERNING EQUATIONS
Q = CIA

WHERE:
Q = PEAK DISCHARGE (CFS)
C = RUNOFF COEFFICIENT
i = RAINFALL INTENSITY 100YR, 24HR (IN/HR)
A = WATERSHED AREA (ACRES)

$Q = (k/n)(A)(R_i^{2/3})(S^{1/2})$

WHERE:
Q = FLOW RATE (CFS)
k = 1.49 (US UNITS)
n = MANNING'S ROUGHNESS COEFFICIENT
A = CROSS SECTIONAL AREA OF FLOW (FT²)
R_H = HYDRAULIC RADIUS (FT)
S = SLOPE(FT/FT)

PEAK DISCHARGE
- RAINFALL INTENSITY REFLECTS A 25 YR STORM EVENT OVER A 24 HOUR PERIOD

GRASSY AREA:

$Q = (.41)(4.67)(.22) \Rightarrow Q = 0.42 \text{ cfs}$

IMPERVIOUS AREA:

$Q = (0.9)(4.67)(.17) \Rightarrow Q = 0.71 \text{ CFS}$

OUTFLOW PIPE CAPACITY:

- PIPE TO BE DESIGNED AS HALF FLOW

PIPE LENGTH = 128 FT
PIPE DIAMETER = 1 FT


$Q = (k/n)(A)(R_i^{2/3})(S^{1/2}) \Rightarrow (1.49/.022)(0.39)(0.25^{2/3})(.015^{1/2})$
 $\Rightarrow Q_{out} = 1.28 \text{ CFS}$

CONCLUSION

$Q_{in} = 0.42 + 0.71 \Rightarrow Q_{in} = 1.13 \text{ CFS}$
 $Q_{out} = 1.28 \text{ CFS}$

$\Rightarrow Q_{in} < Q_{out} \text{ OK}$

MSS Engineering, LLC
ENGINEERING, CONSULTING & DESIGN
414 W 5th St., Auburn, IN 46706
Phone: (260) 267-7414
Email: tamcdaniel@mssengineer.com
Travis A. McDaniel, PE

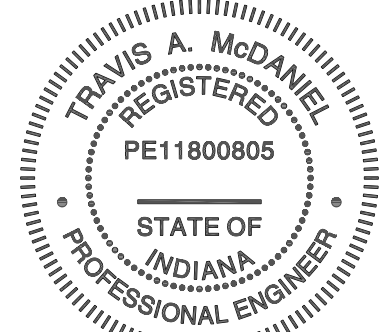

Travis A. McDaniel
05/26/23

PROJECT LOCATION:
560 S 900 E
MARION, IN 46953

PROJECT NAME:
BID SPEC &
DESIGN

DRAWING TITLE:
DRAINAGE PLAN

REVISIONS:

NO.	DATE	DESCRIPTION	BY
1	5/26/23	SITE PLAN UPDATES	TAM

JOB NUMBER:
22.081.171

DRAWN BY: CAS

ENGINEERED BY: CAS


START DATE: 05/12/21

PROGRESS DATE: 7/13/21

CERTIFIED DATE: 05/26/23


SCALE: As indicated

PAGE NUMBER:

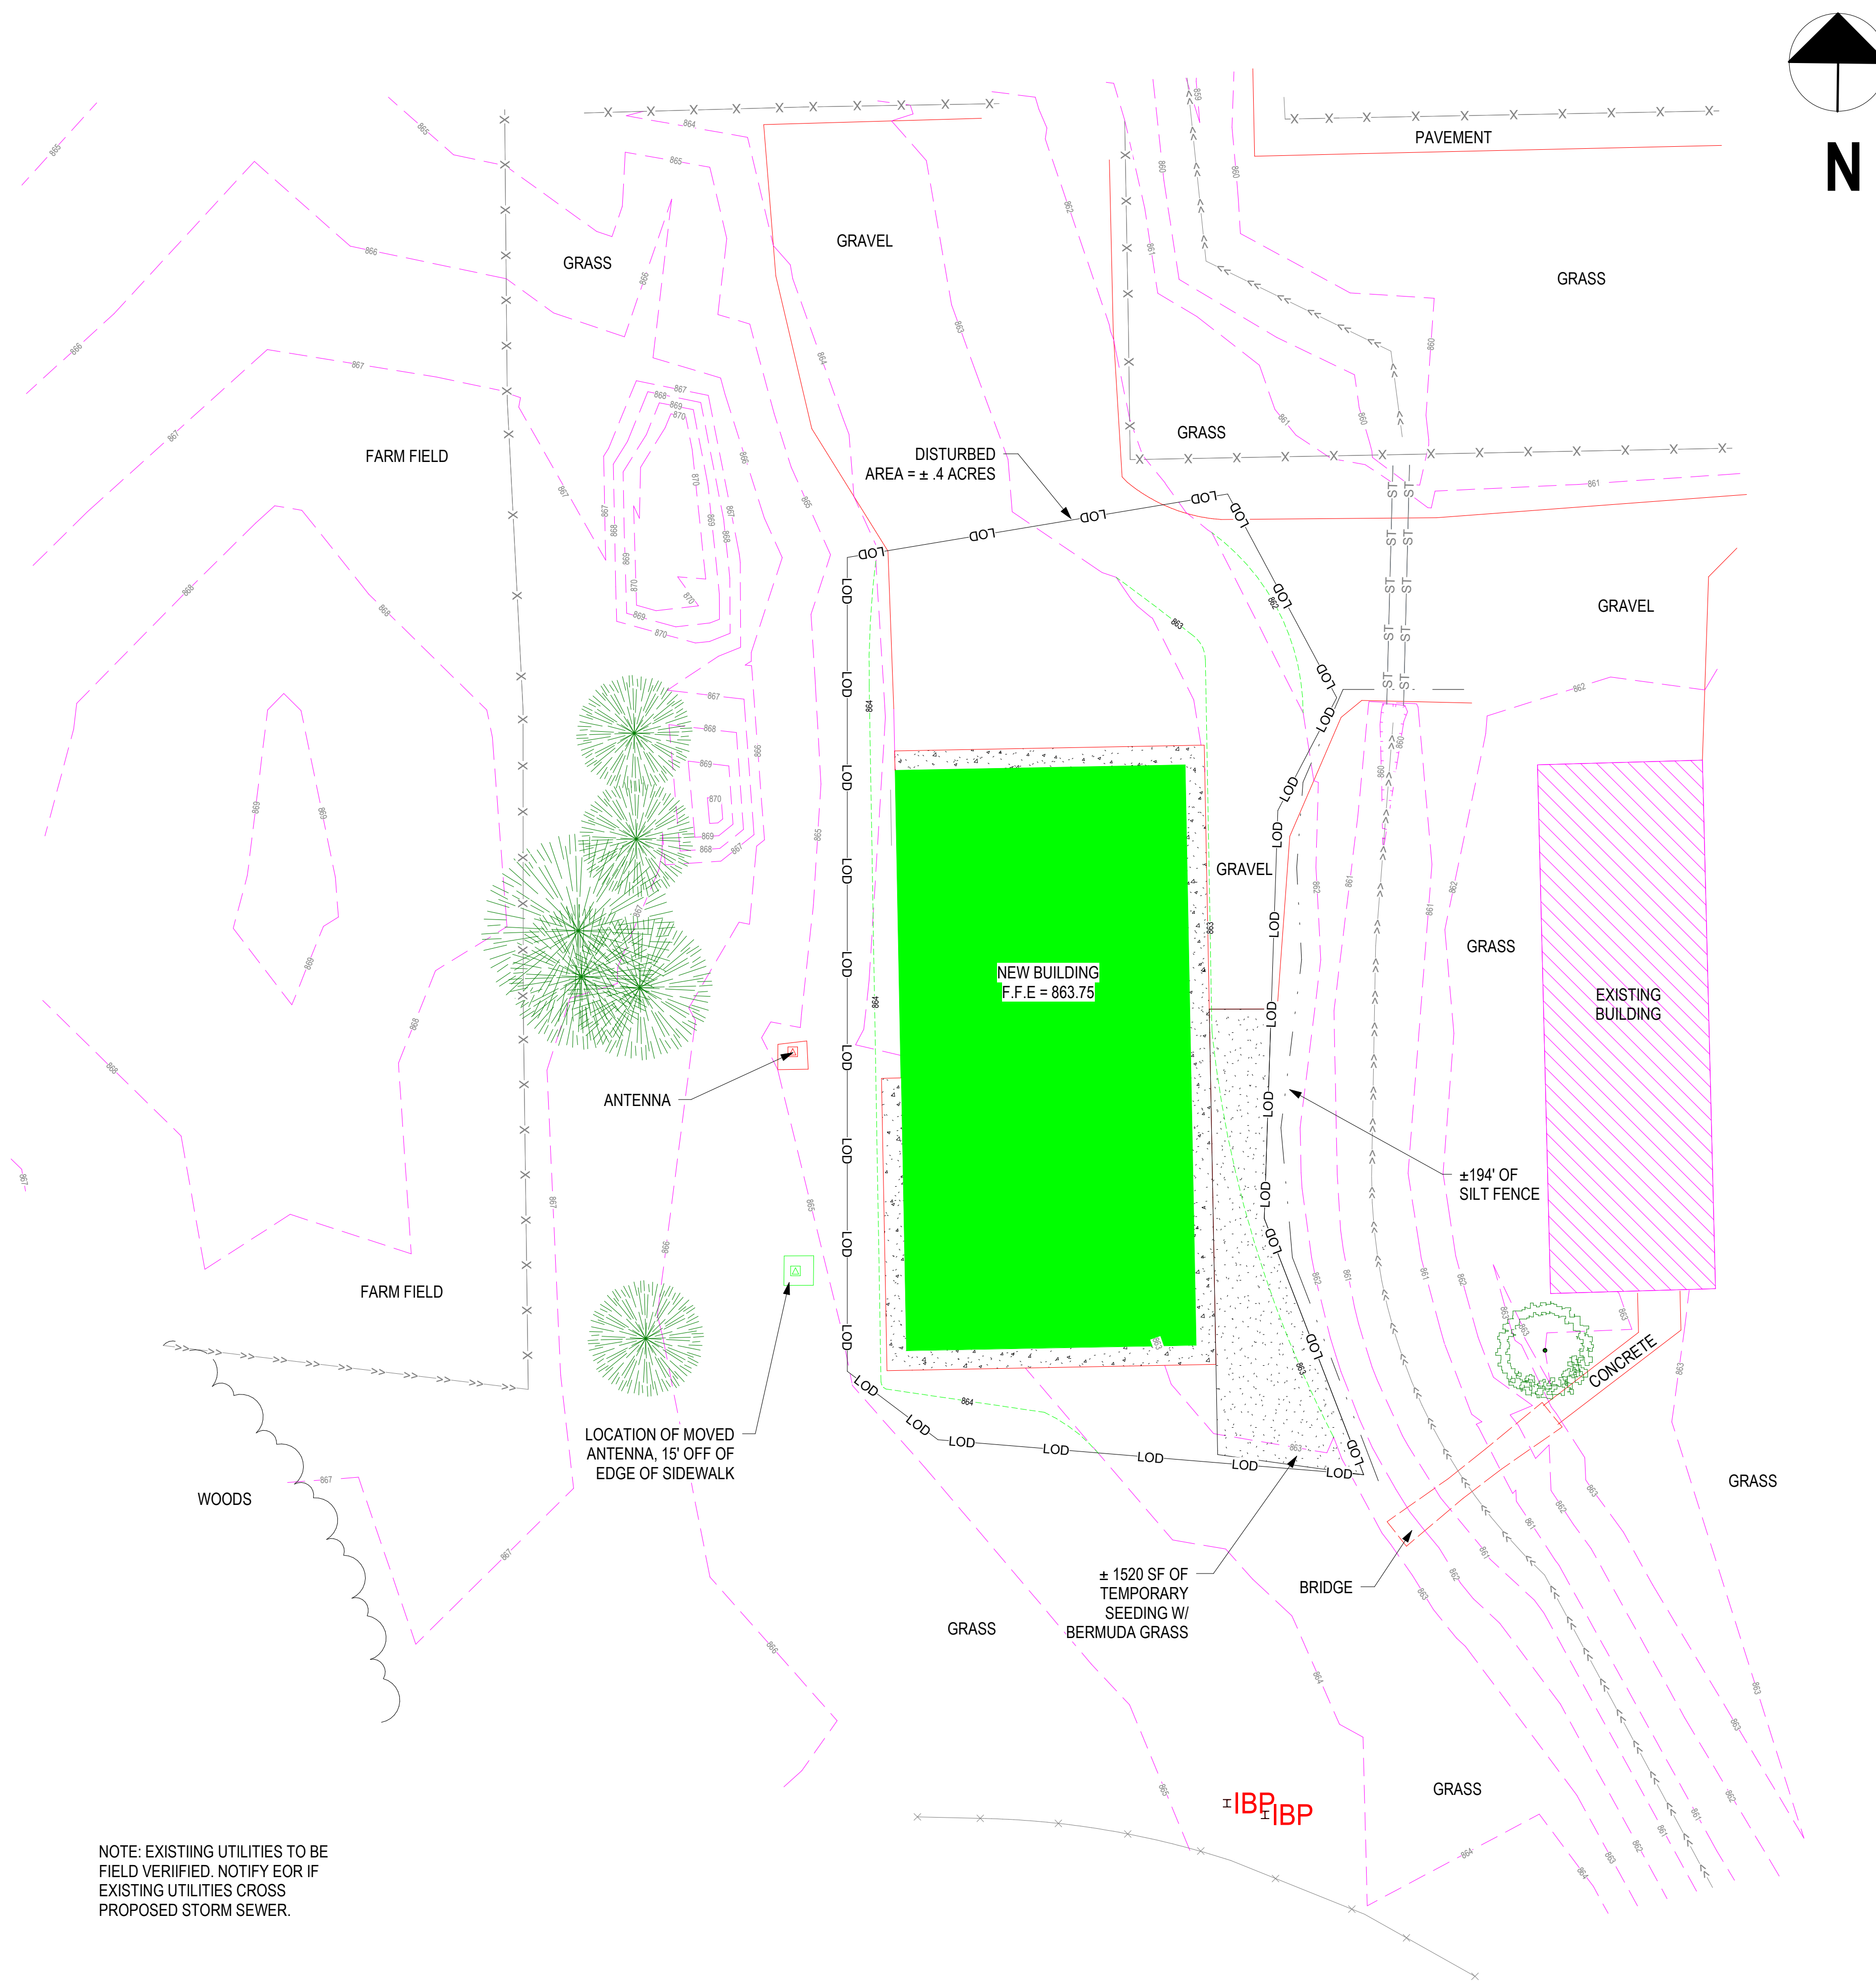

NOTE: EXISTING UTILITIES TO BE
FIELD VERIFIED. NOTIFY EOR IF
EXISTING UTILITIES CROSS
PROPOSED STORM SEWER.

EROSION CONTROL PLAN - PRE
CONSTRUCTION
1" = 20'-0"

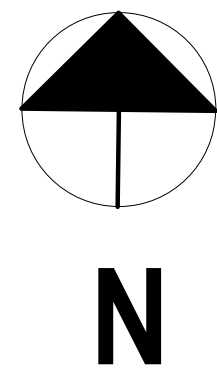

<u>LINETYPE LEGEND</u>	
	NEW BUILDING
	EXISTING BUILDING
	PROPERTY LINE
	SETBACK
	SURFACE EDGE
	PARKING LOT LINE
	FENCE
	SOIL REGION
	DEMO
	OVERHEAD
	TELECOM/DATA
	SWALE
	ELECTRIC
	GAS PIPE
	WATER PIPE
	SANITARY PIPE
	STORM PIPE
	EROSION CONTROL
	LINE OF DISTURBANCE
	NATIONAL POLLUTION DISCHARGE ELIMINATION SYSTEM BOUNDARY
	PROPOSED CONTOUR
	EXISTING CONTOUR
	EXISTING ELECTRIC
	EXISTING GAS PIPE
	EXISTING WATER PIPE
	EXISTING STORM PIPE
	EXISTING SANITARY PIPE
	EXISTING FENCE

LINETYPE LEGEND


1" = 20'-0"

<u>REGION LEGEND</u>	
	NEW BUILDING
	EXISTING BUILDING
	DRIVEWAY/SIDEWALKS/ROADS
	WATER
	RIP RAP
	TEMPORARY SEEDING
	PERMANENT SEEDING

<u>SYMBOL LEGEND</u>	
	MANHOLE
	DRYWELL
	SANITARY SEWER CLEANOUT
	WATER VALVE
	GAS VALVE
	FIRE HYDRANT
	SPOT ELEVATION
	DECIDUOUS TREE
	CONIFEROUS TREE
	SYMBOL LEGEND
$1/4" = 1'-0"$	



MSS Engineering, LLC
ENGINEERING, CONSULTING, & DESIGN
414 W 5th St., Auburn, IN 46706
Phone: (260) 267-7414
Email: tamcdaniel@mssengineer.com
Travis A. McDaniel, PE

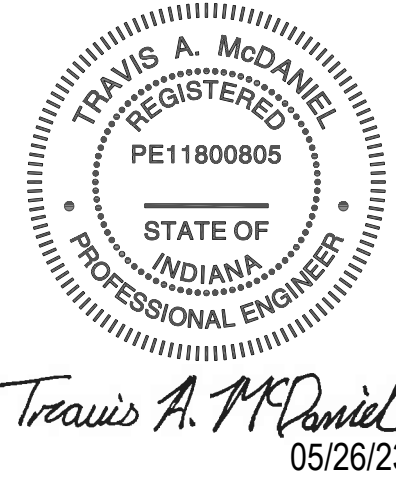

PROJECT LOCATION:
560 S 900 E
MARION, IN 46953

PROJECT NAME:
BID SPEC &
DESIGN

DRAWING TITLE:
EROSION
CONTROL - PRE
CONSTRUCTION

REVISIONS:

NO.	DATE	DESCRIPTION	BY
-----	------	-------------	----

JOB NUMBER:
22.081.171

DRAWN
BY: CAS

ENGINEERED
BY: CAS

START DATE:	05/12/21
--------------------	----------

PROGRESS DATE:	7/13/21
----------------	---------

CERTIFIED DATE: 05/26/23



SCALE: As indicated

PAGE NUMBER:

EROSION CONTROL PLAN - POST CONSTRUCTION
1" = 20'-0"

1

NOTE: EXISTING UTILITIES TO BE FIELD VERIFIED. NOTIFY EOR IF EXISTING UTILITIES CROSS PROPOSED STORM SEWER.

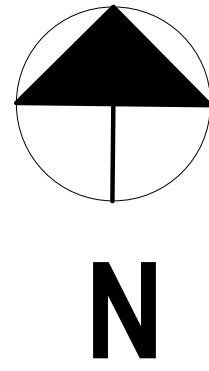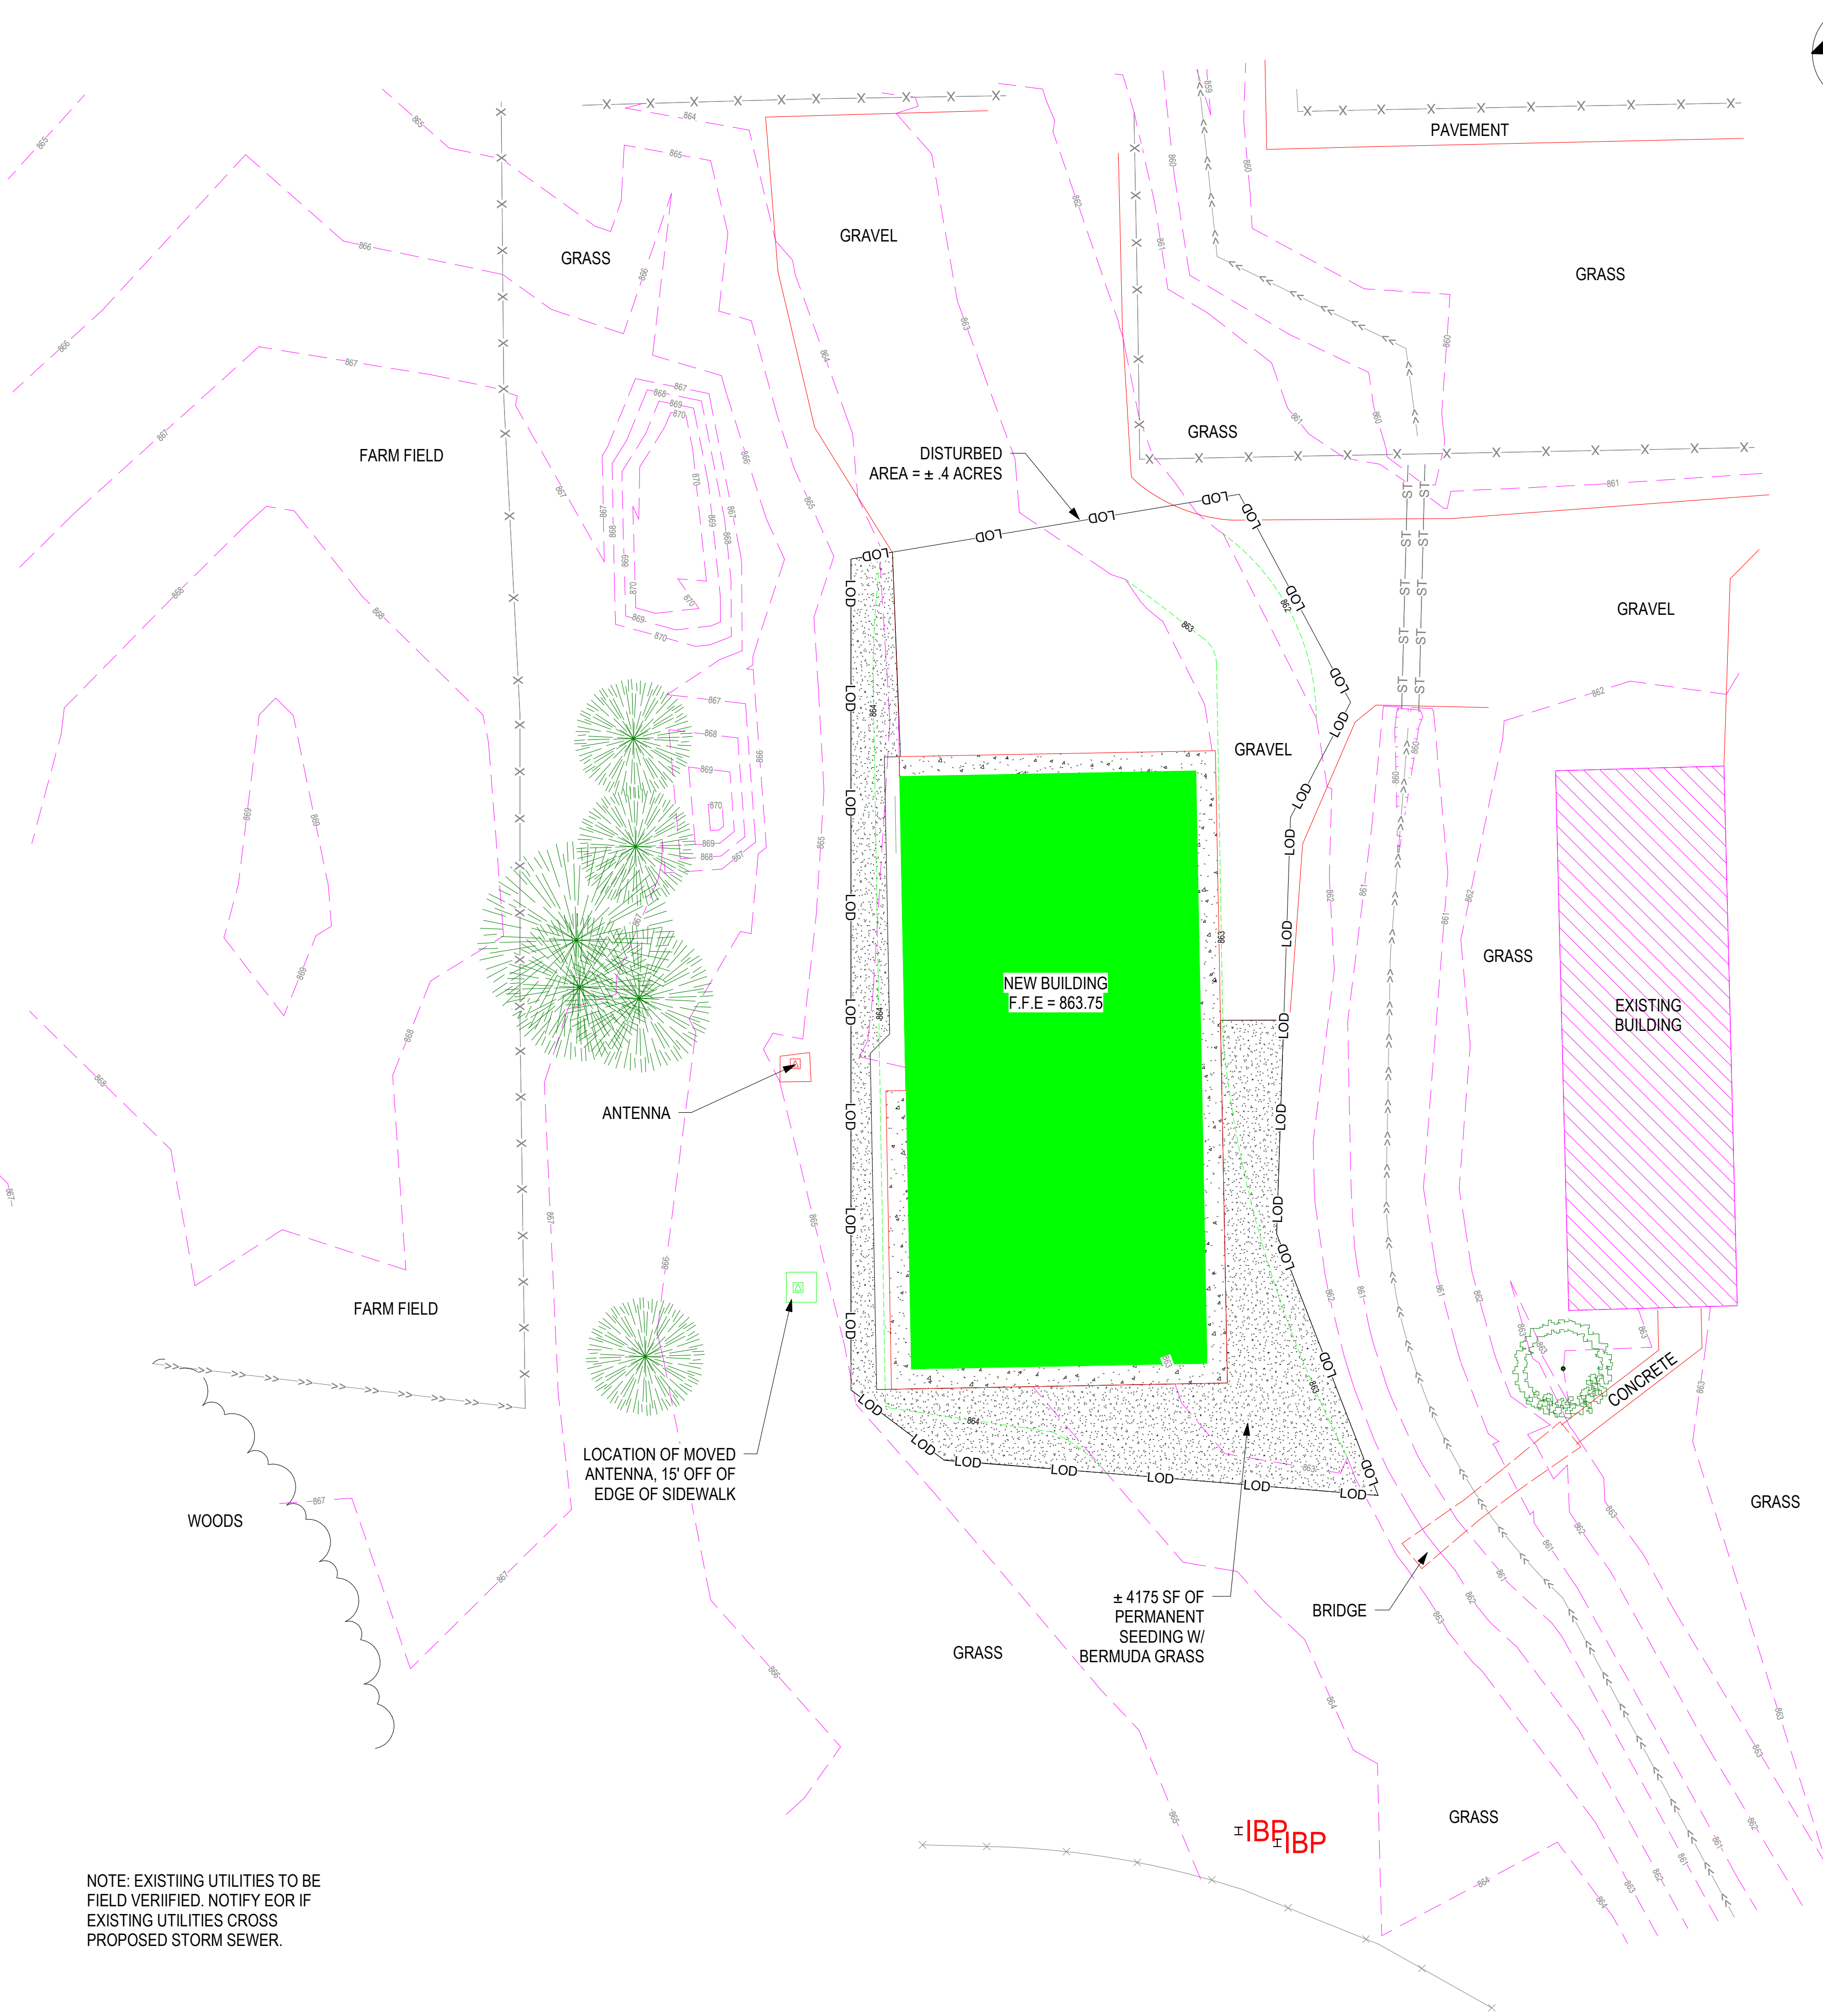

LINETYPE LEGEND	
	NEW BUILDING
	EXISTING BUILDING
	PROPERTY LINE
	SETBACK
	SURFACE EDGE
	PARKING LOT LINE
	FENCE
	SOIL REGION
	DEMO
	OVERHEAD
	TELECOM/DATA
	SWALE
	ELECTRIC
	GAS PIPE
	WATER PIPE
	SANITARY PIPE
	STORM PIPE
	EROSION CONTROL
	LINE OF DISTURBANCE
	NATIONAL POLLUTION DISCHARGE ELIMINATION SYSTEM BOUNDARY
	PROPOSED CONTOUR
	EXISTING CONTOUR
	EXISTING ELECTRIC
	EXISTING GAS PIPE
	EXISTING WATER PIPE
	EXISTING STORM PIPE
	EXISTING SANITARY PIPE
	EXISTING FENCE

○ LINETYPE LEGEND
1" = 20'-0"


REGION LEGEND	
	NEW BUILDING
	EXISTING BUILDING
	DRIVEWAY/SIDEWALKS/ROADS
	WATER
	RIP RAP
	TEMPORARY SEEDING
	PERMANENT SEEDING

○ REGION LEGEND
1/4" = 1'-0"

SYMBOL LEGEND	
	MANHOLE
	DRYWELL
	SANITARY SEWER CLEANOUT
	WATER VALVE
	GAS VALVE
	FIRE HYDRANT
	SPOT ELEVATION
	DECIDUOUS TREE
	CONIFEROUS TREE

○ SYMBOL LEGEND
1/4" = 1'-0"

MSS Engineering, LLC
ENGINEERING, CONSULTING & DESIGN
414 W 5th St., Auburn, IN 46706
Phone: (260) 267-7414
Email: tamcdaniel@mssengineer.com
Travis A. McDaniel, PE

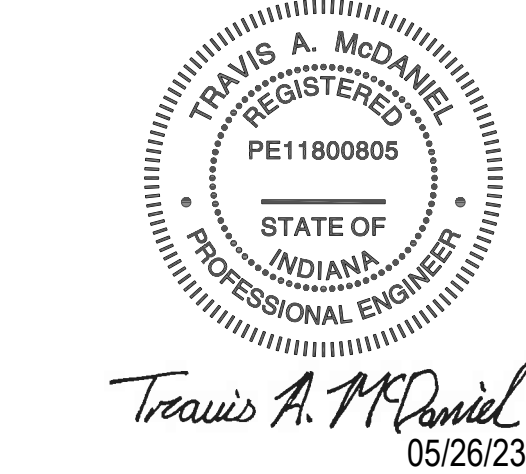

PROJECT LOCATION:
560 S 900 E
MARION, IN 46953

PROJECT NAME:
BID SPEC &
DESIGN

DRAWING TITLE:
EROSION
CONTROL - POST
CONSTRUCTION

REVISIONS:

NO.	DATE	DESCRIPTION	BY
-----	------	-------------	----

JOB NUMBER:
22.081.171

DRAWN BY: CAS

ENGINEERED BY: CAS


START DATE: 05/12/21

PROGRESS DATE: 7/13/21


CERTIFIED DATE: 05/26/23

SCALE: As indicated


PAGE NUMBER:

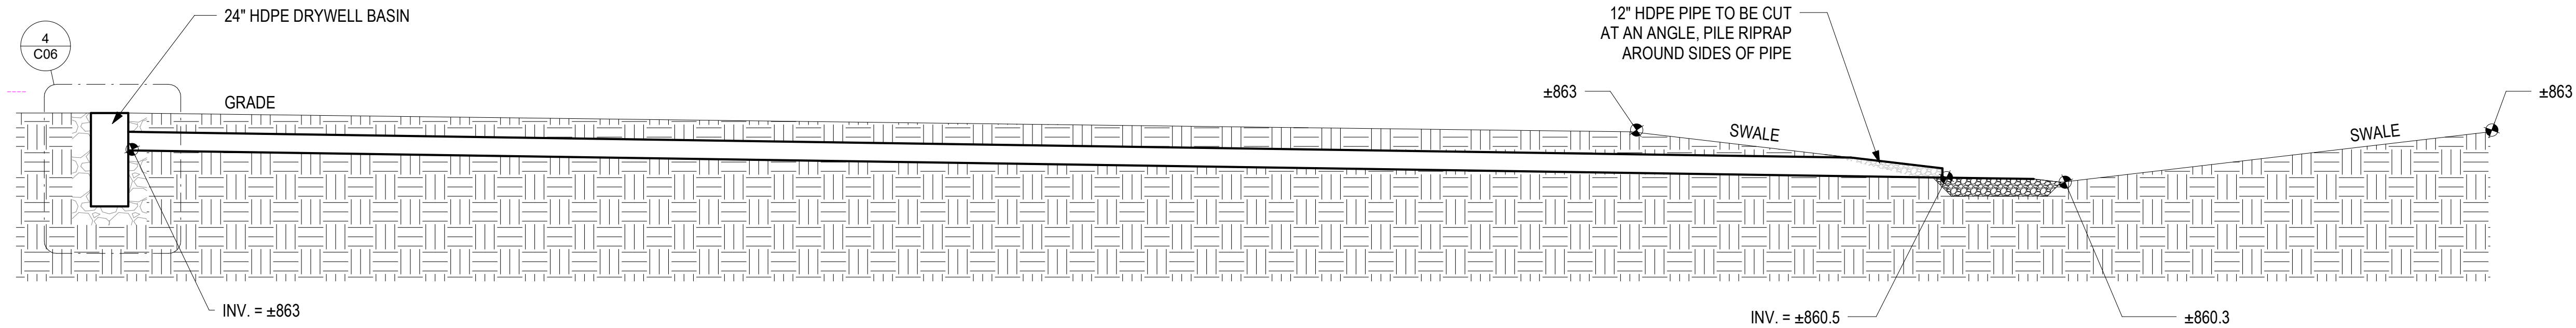



① OUTLET PIPE - PROFILE VIEW
3/16" = 1'-0"

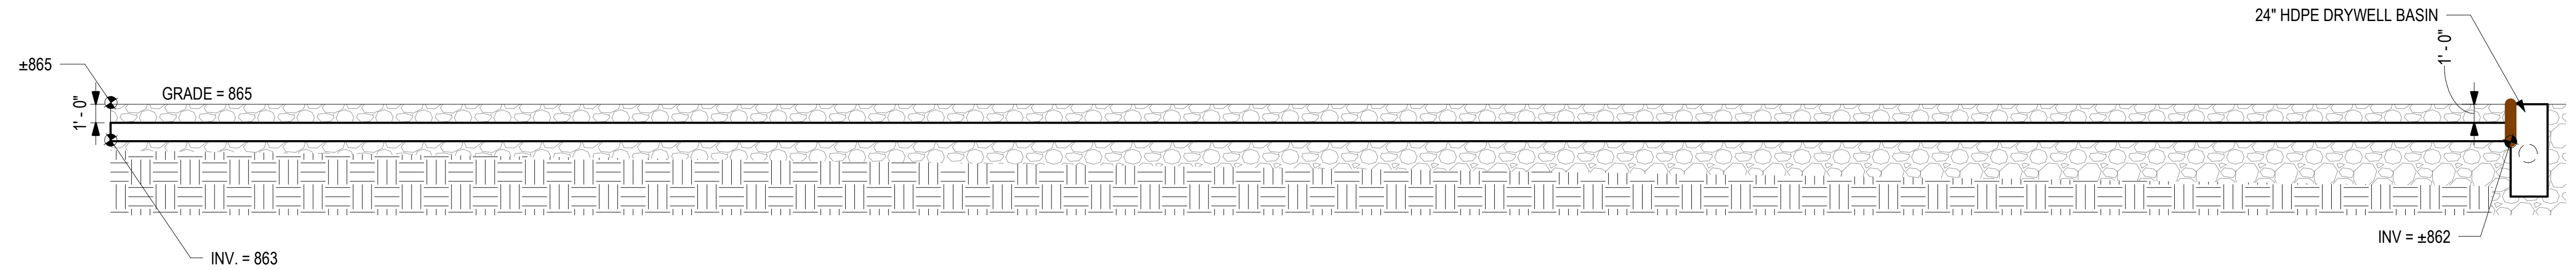


② INFILTRATION TRENCH - PROFILE VIEW
3/16" = 1'-0"

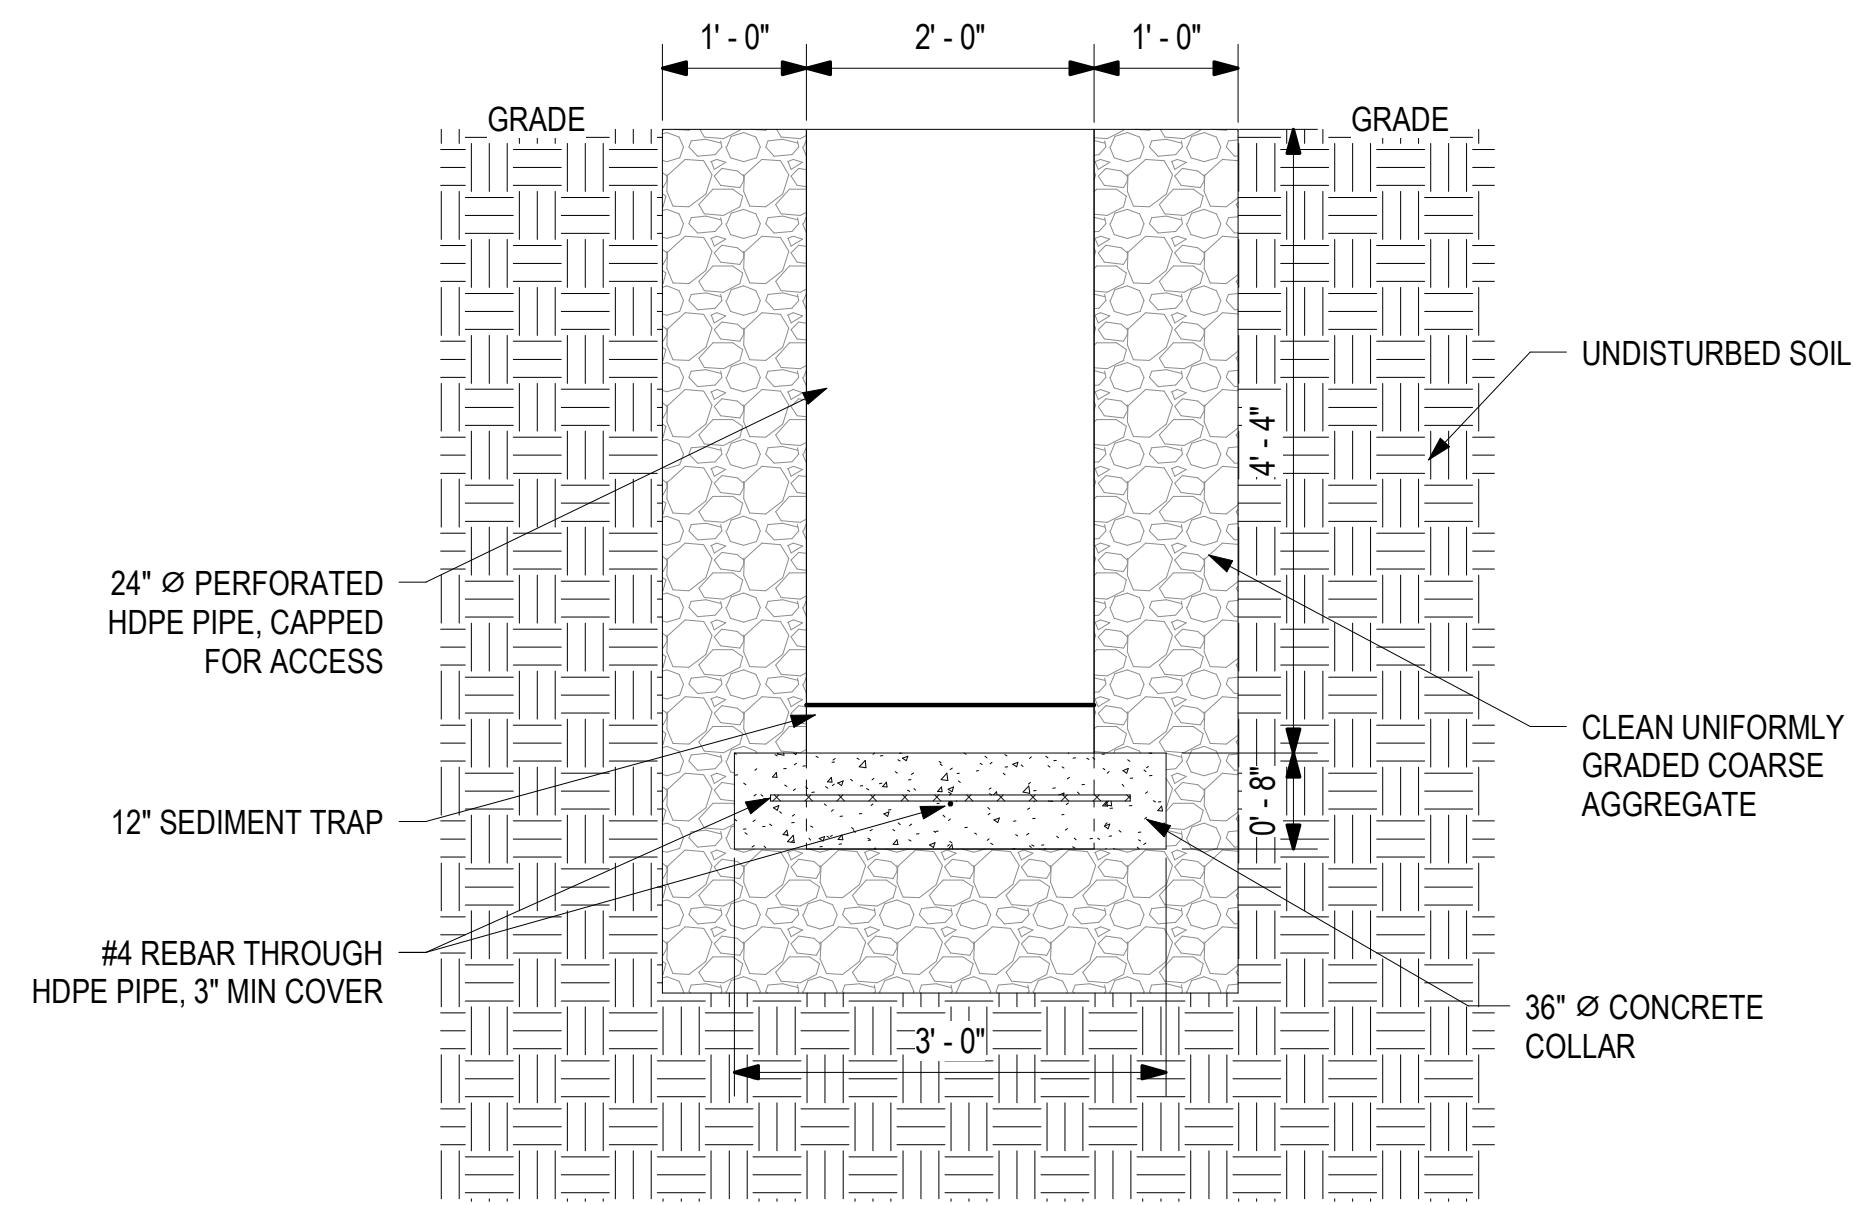




④ DRYWELL BASIN - CALLOUT
3/4" = 1'-0"

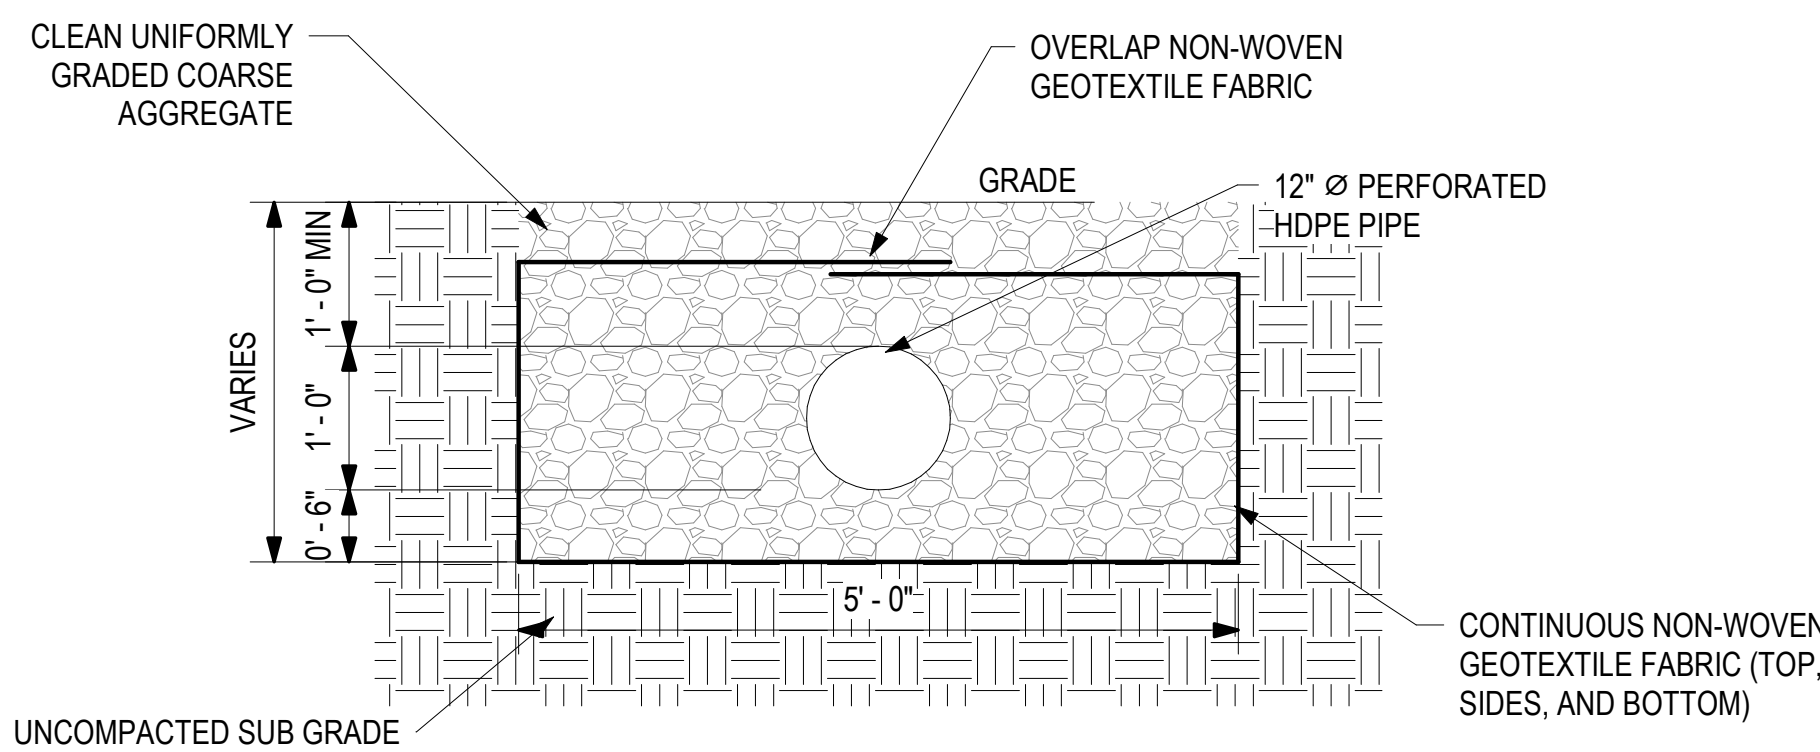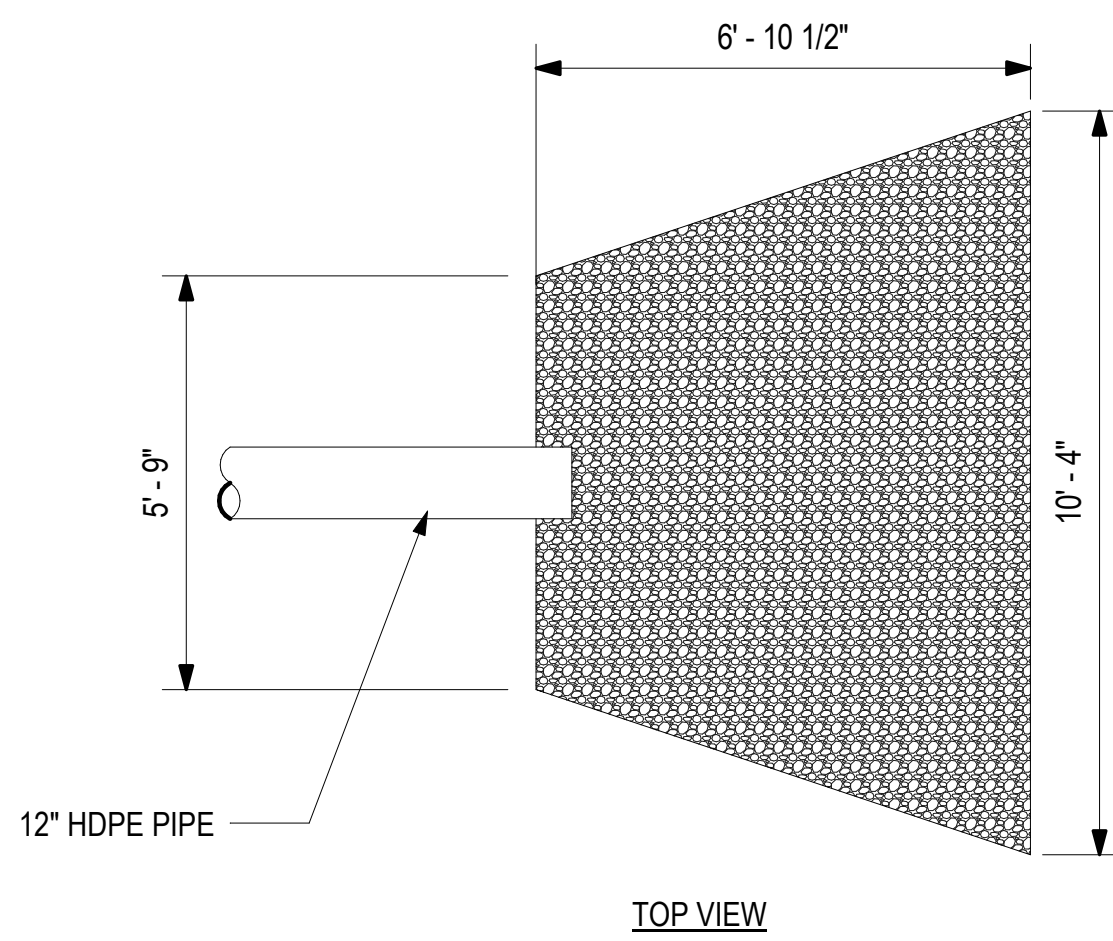

3 INFILTRATION TRENCH - SECTION VIEW
3/4" = 1'-0"

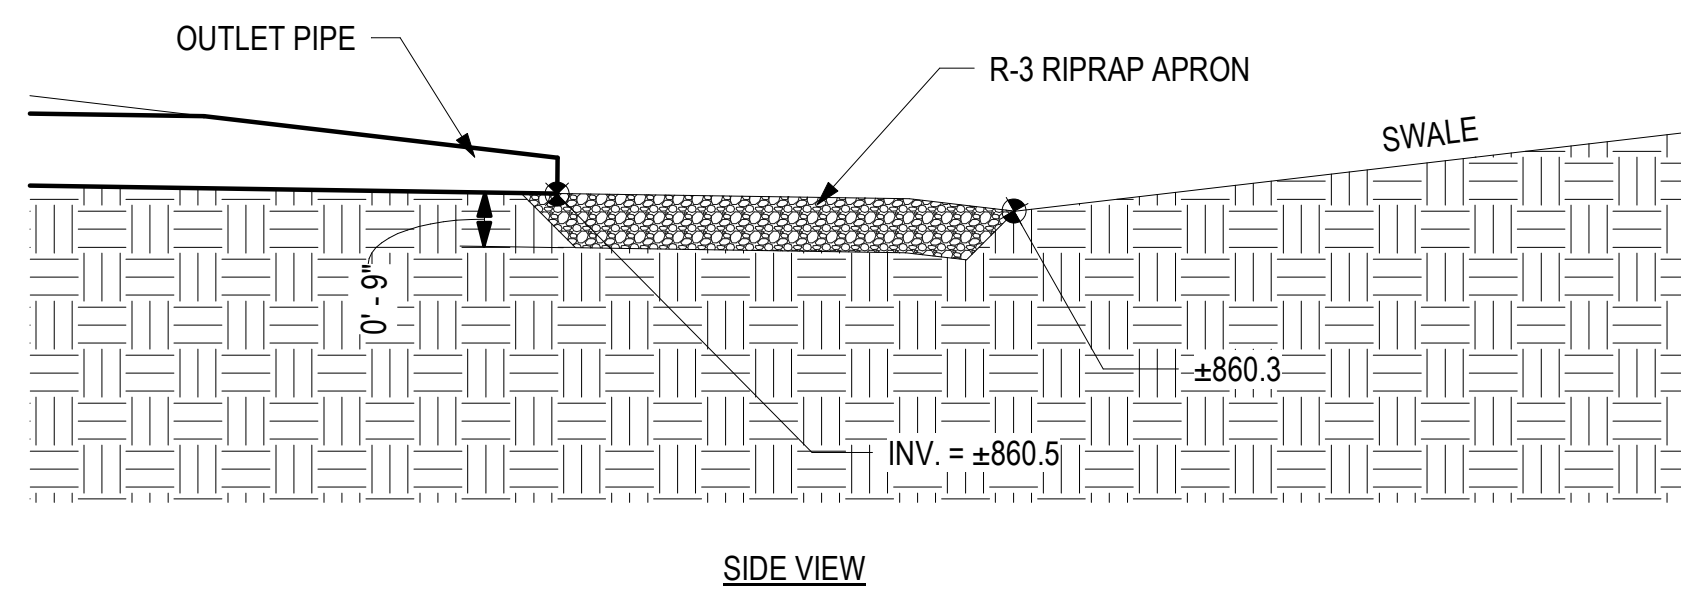

5 RIPRAP APRON DETAILS
3/8" = 1'-0"

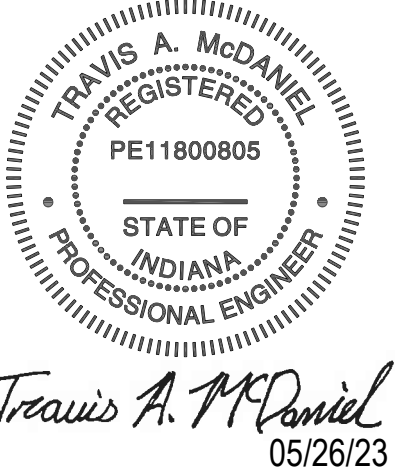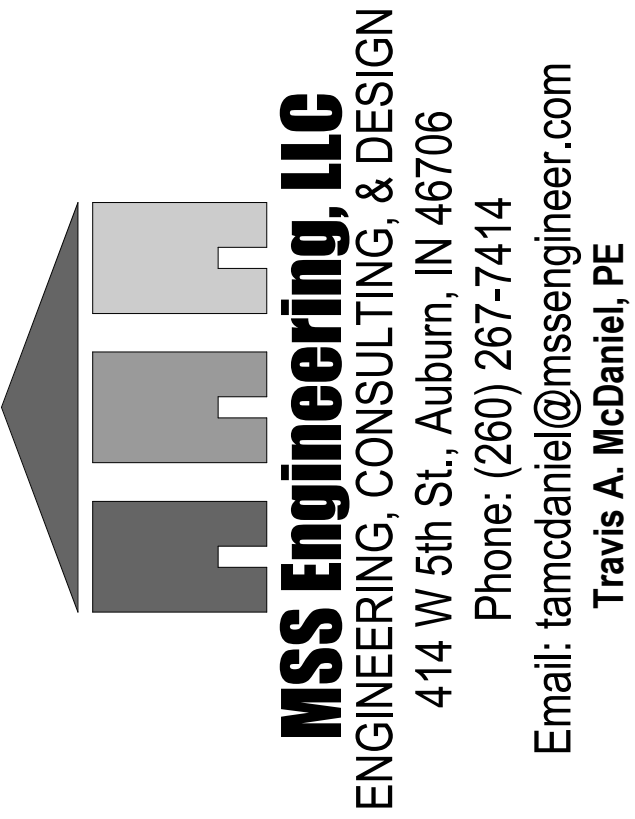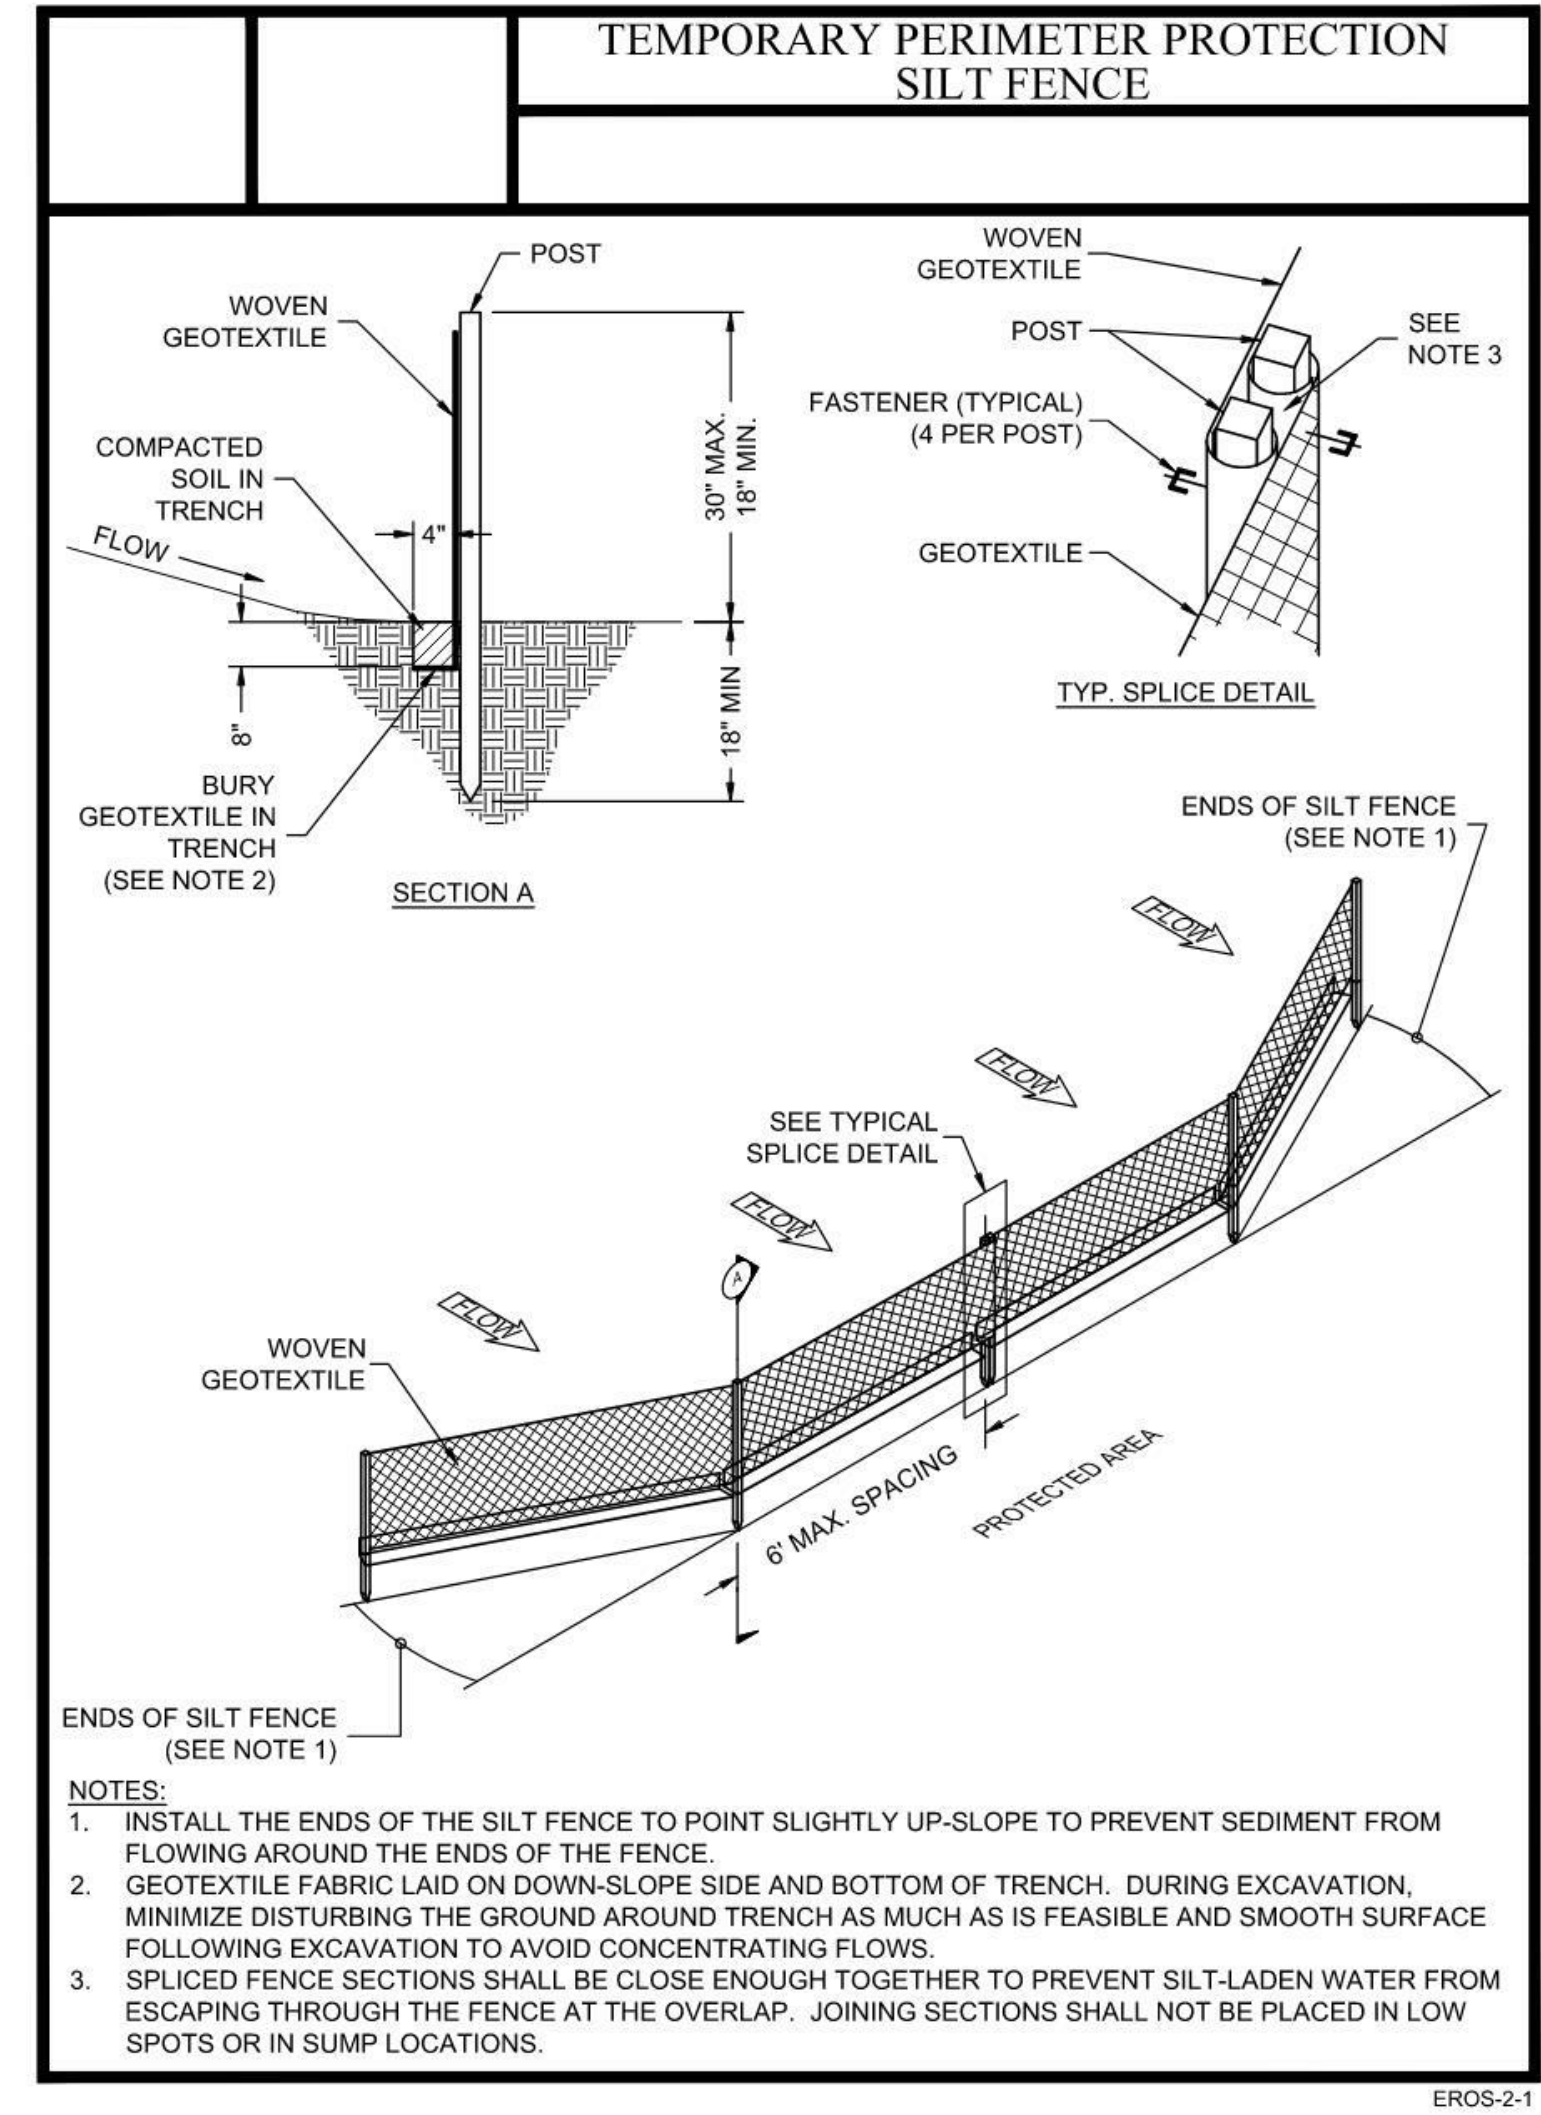

PROJECT LOCATION:
560 S 900 E
MARION, IN 46953

PROJECT NAME:
BID SPEC &
DESIGN

DRAWING TITLE:
SECTION VIEWS &
DETAILS

REVISIONS:

NO.	DATE	DESCRIPTION	BY
-----	------	-------------	----

JOB NUMBER:
22.081.171

DRAWN
BY: CAS

**ENGINEERED
BY: CAS**

START DATE: 05/12/21


PROGRESS DATE: 7/13/21

CERTIFIED DATE: 05/26/23


SCALE: As indicated

PAGE NUMBER:


NOTE: ALL SIDEWALKS TO BE 4FT WIDE. TROWEL EDGED, AND BROOMED FINISH. ALL SIDEWALKS SHALL BE 4" THICK, EXCEPT IN FRONT OF OVERHEAD DOORS SHALL BE 8" THICK MINIMUM. ALL SIDEWALKS SHALL BE PROVIDED W/ A 4" CRUSHED STONE BASE, AND CONTROL JOINTS SET EVERY 8FT O/C.

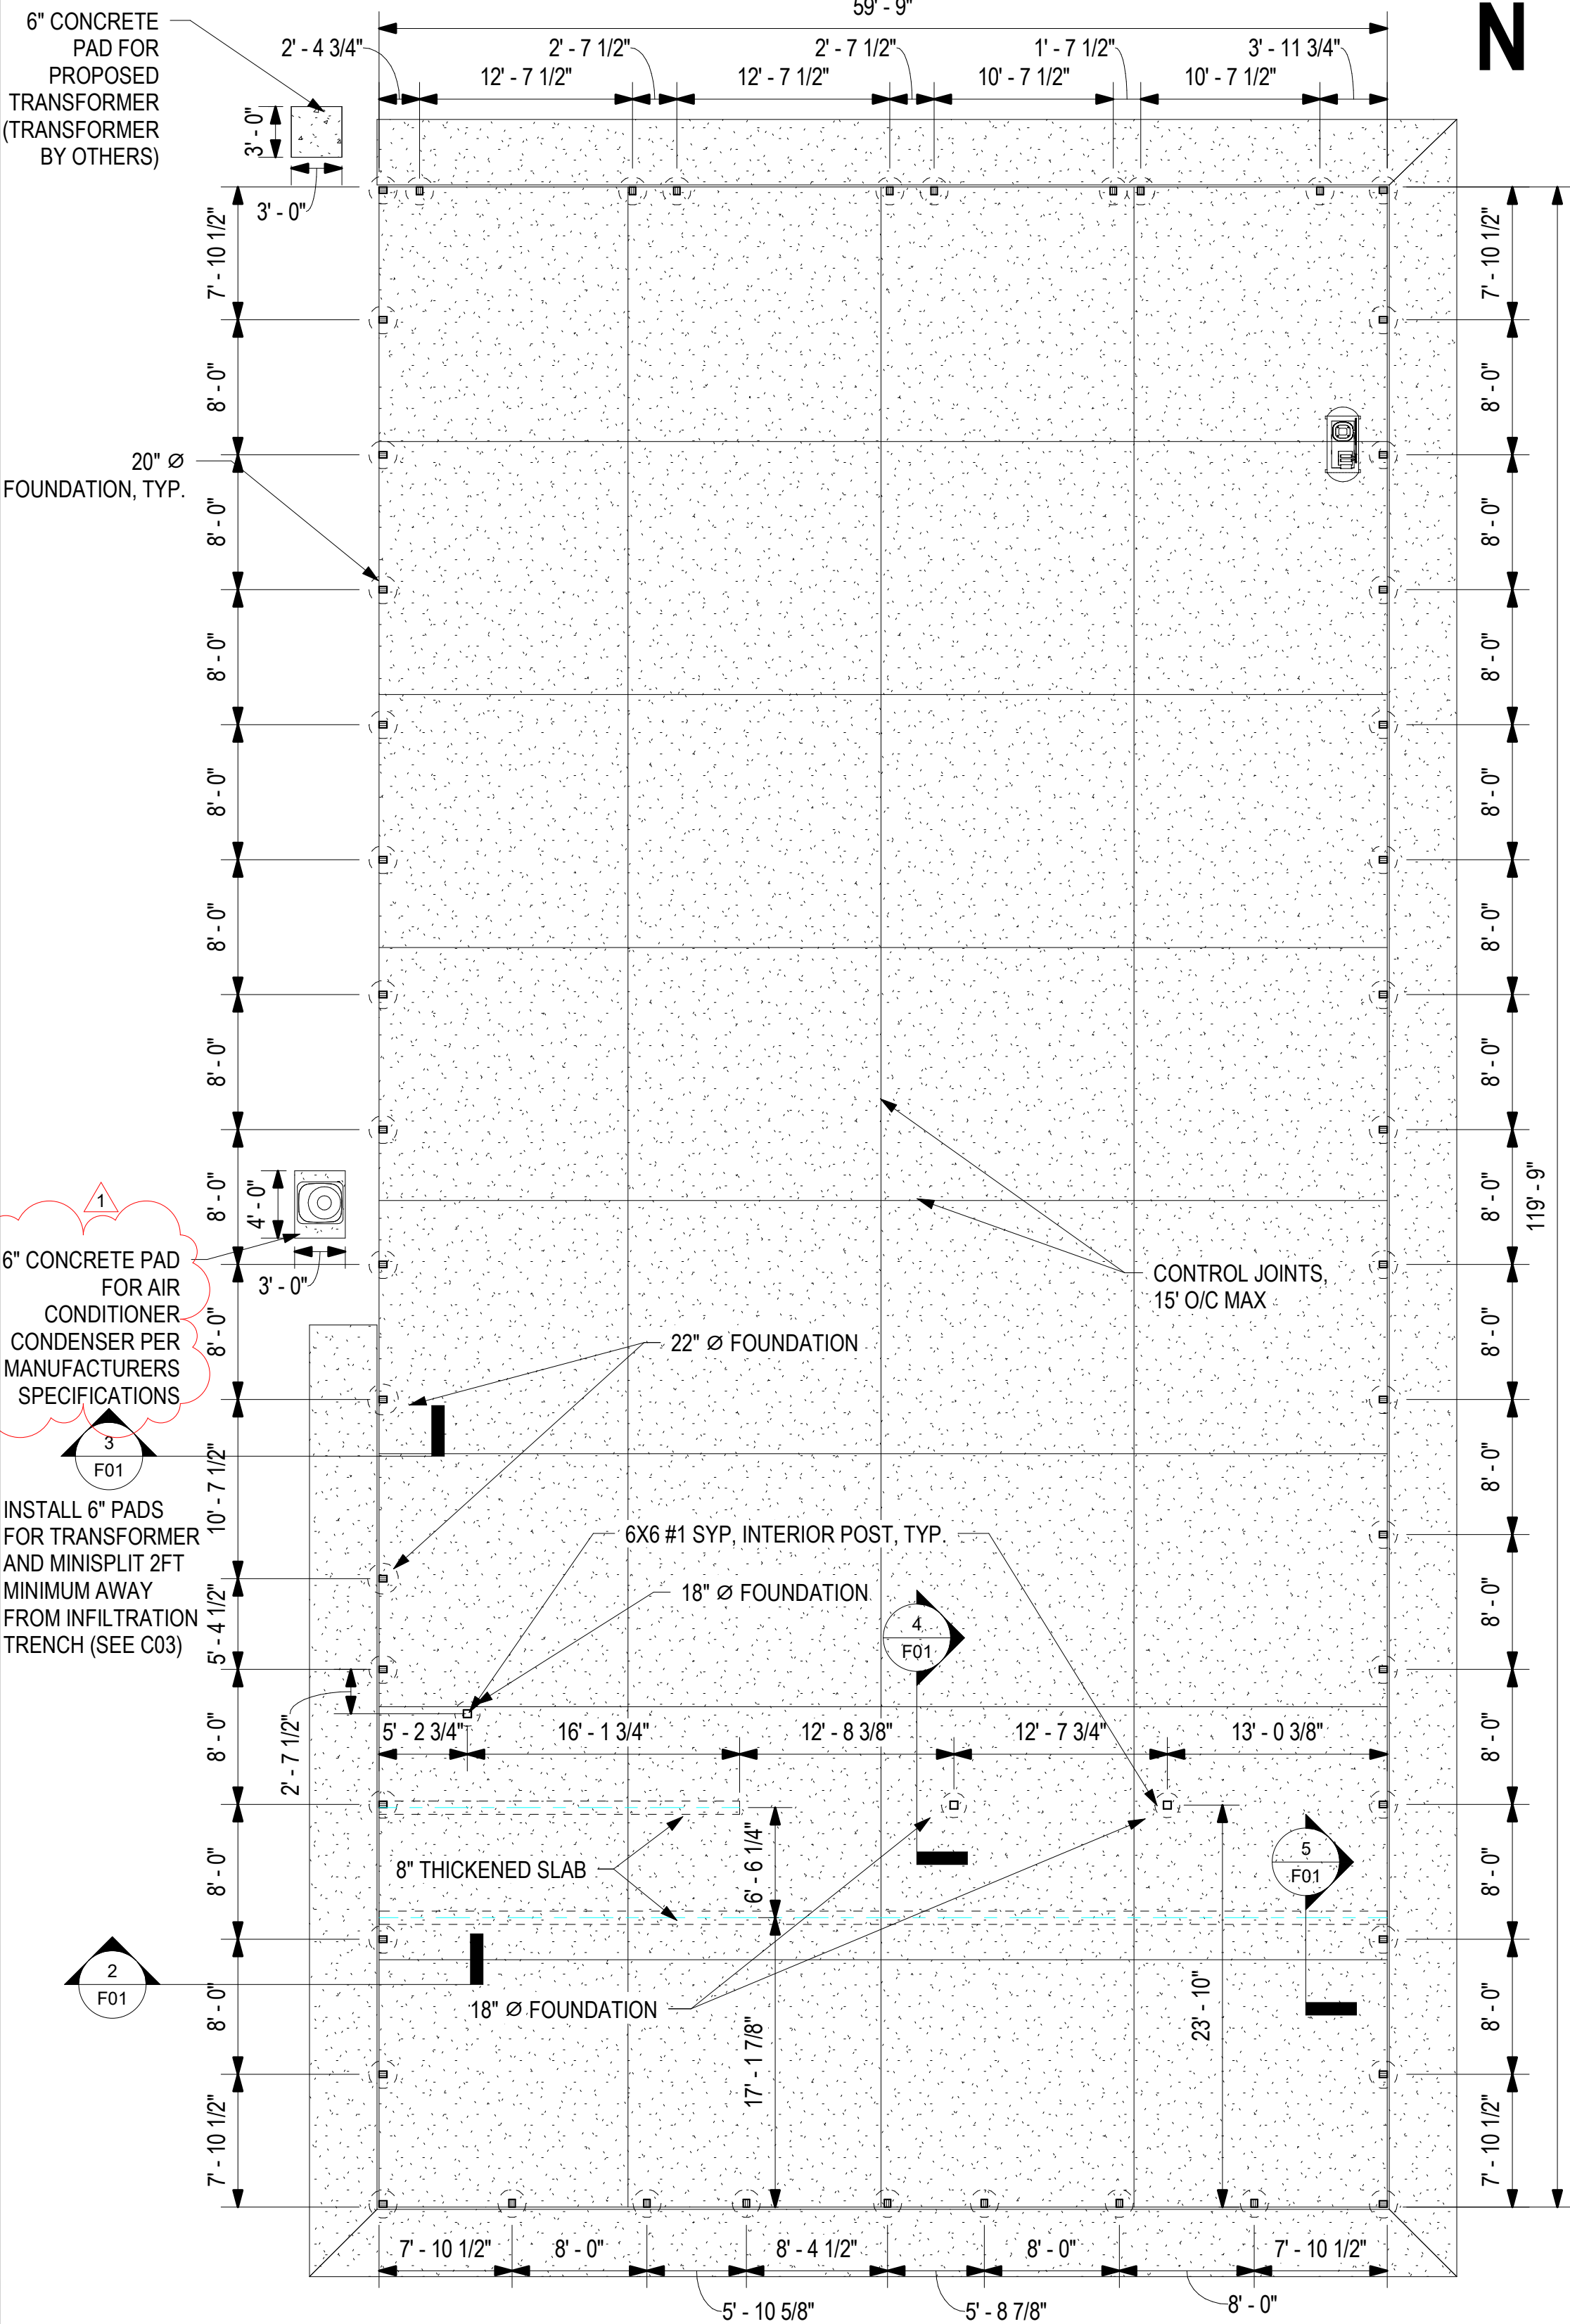


1 FOUNDATION PLAN
1/8" = 1'-0"

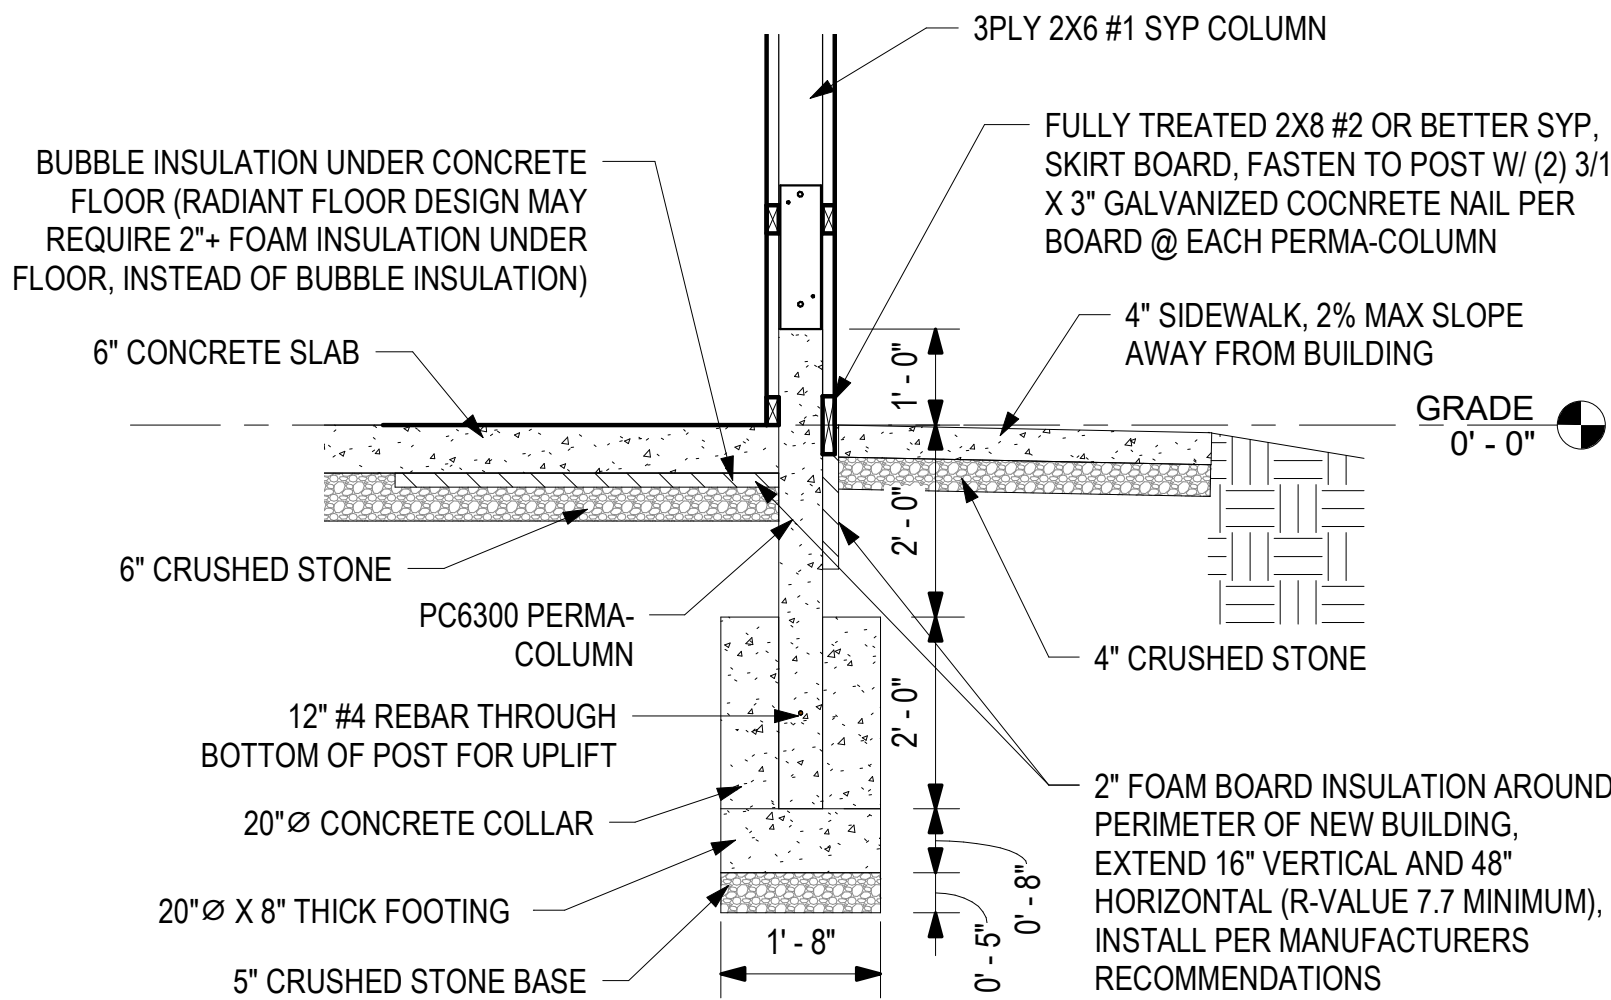


2 20" FOUNDATION DETAIL - TYPICAL
1/2" = 1'-0"

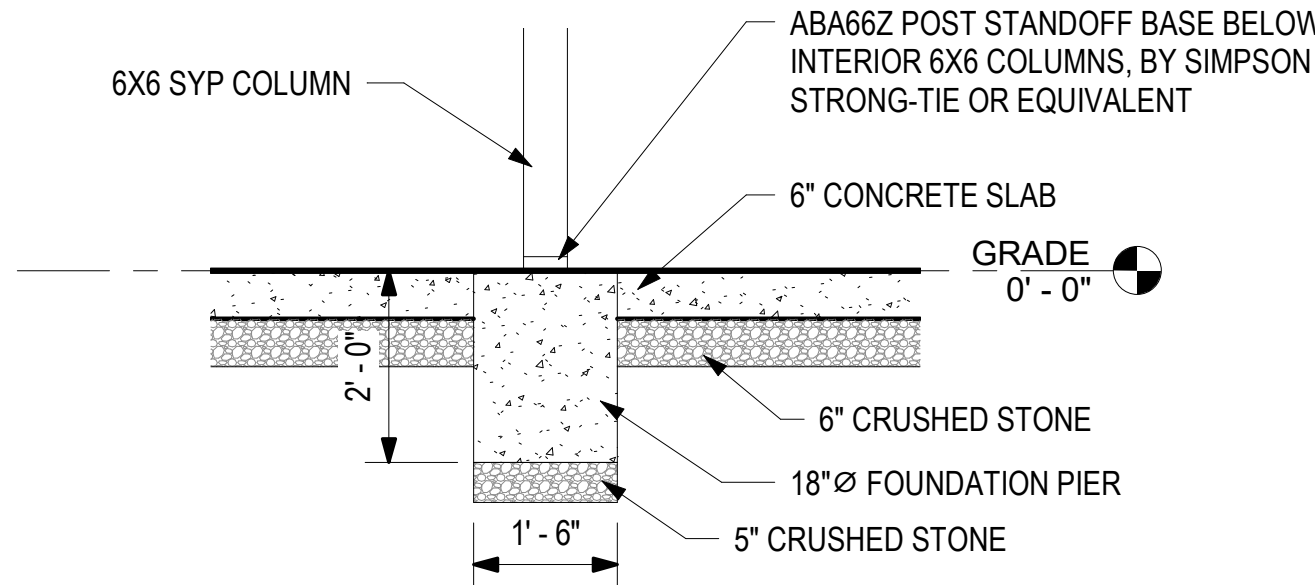

4 18" FOUNDATION DETAIL - SECTION
VIEW
1/2" = 1'-0"

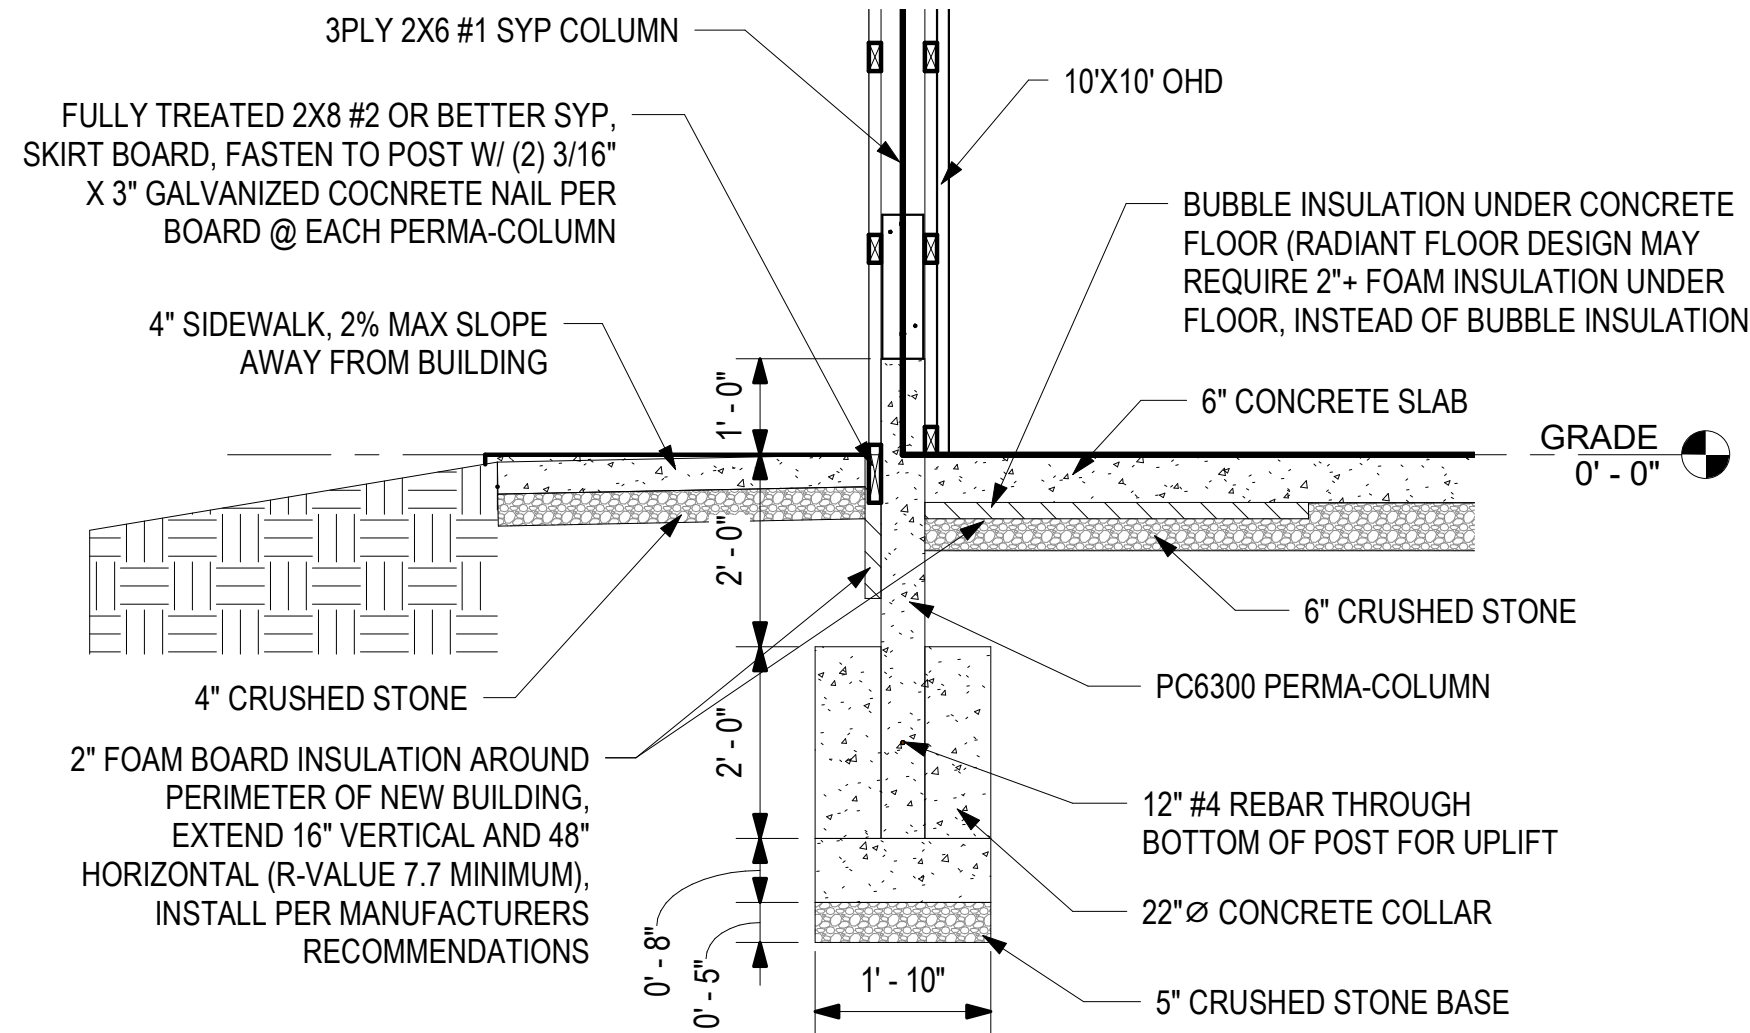


3 22" FOUNDATION DETAIL - SECTION
VIEW
1/2" = 1'-0"

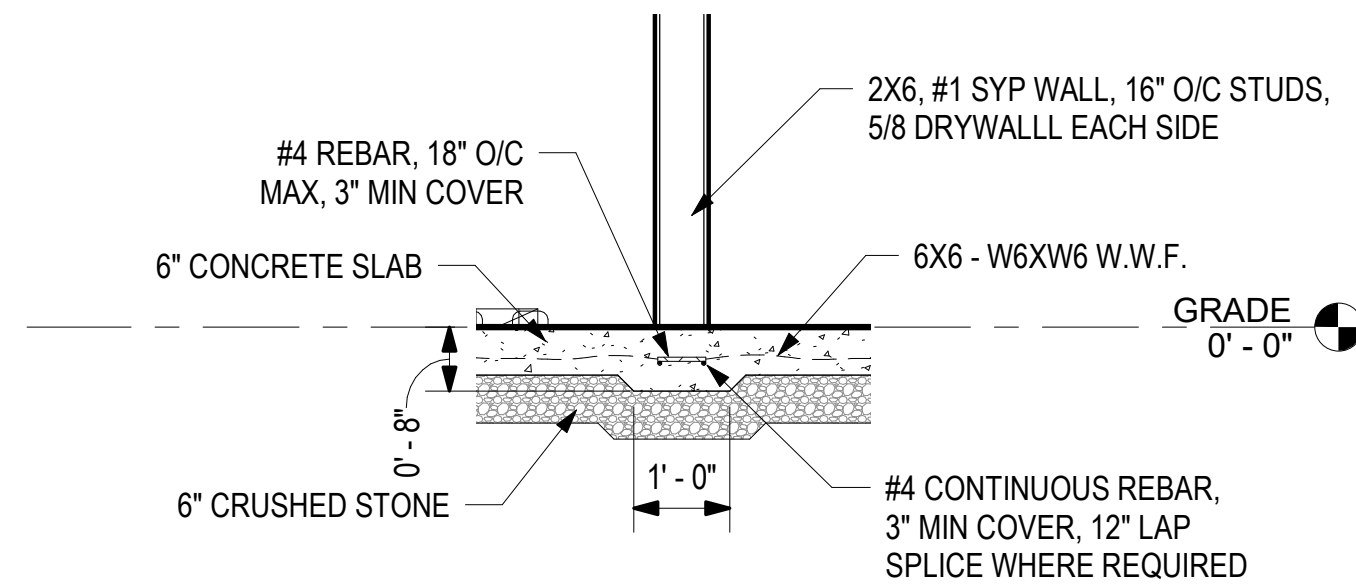


5 THICKENED SLAB - SECTION VIEW
1/2" = 1'-0"

*NOTE:
EVERY OTHER BAR SHALL EXTEND THROUGH CONTROL JOINTS. CUT ONE HALF OF HORIZONTAL STEEL AT THESE LOCATIONS

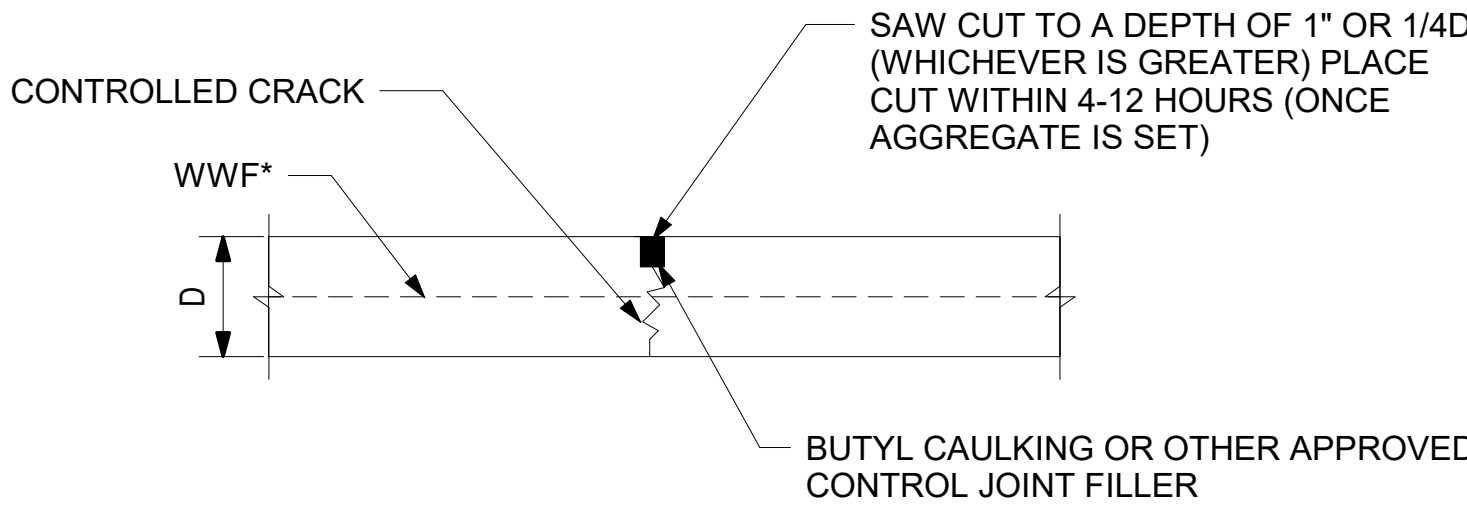

6 CONTROL JOINT DETAIL
1 1/2" = 1'-0"

MSS Engineering, LLC
ENGINEERING, CONSULTING & DESIGN
414 W 5th St., Auburn, IN 46706
Phone: (260) 267-7414
Email: tamcdaniel@mssengineer.com
Travis A. McDaniel, PE

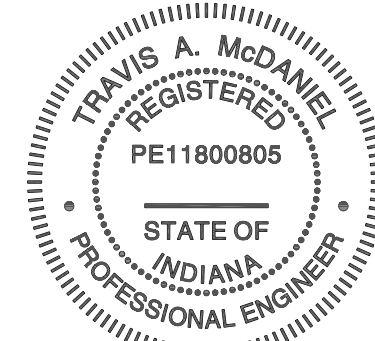

Travis A. McDaniel
05/26/23

PROJECT LOCATION:
560 S 900 E
MARION, IN 46953

PROJECT NAME:
BID SPEC &
DESIGN

DRAWING TITLE:
FOUNDATION
PLAN

REVISIONS:

NO.	DATE	DESCRIPTION	BY
1	5/18/23	UPDATE/CORRECT NOTATION	TAM

JOB NUMBER:
22.081.171

DRAWN
BY: CAS

ENGINEERED
BY: CAS



START DATE: 05/12/21

PROGRESS DATE: 7/13/21

CERTIFIED DATE: 05/26/23

SCALE: As indicated

PAGE NUMBER:

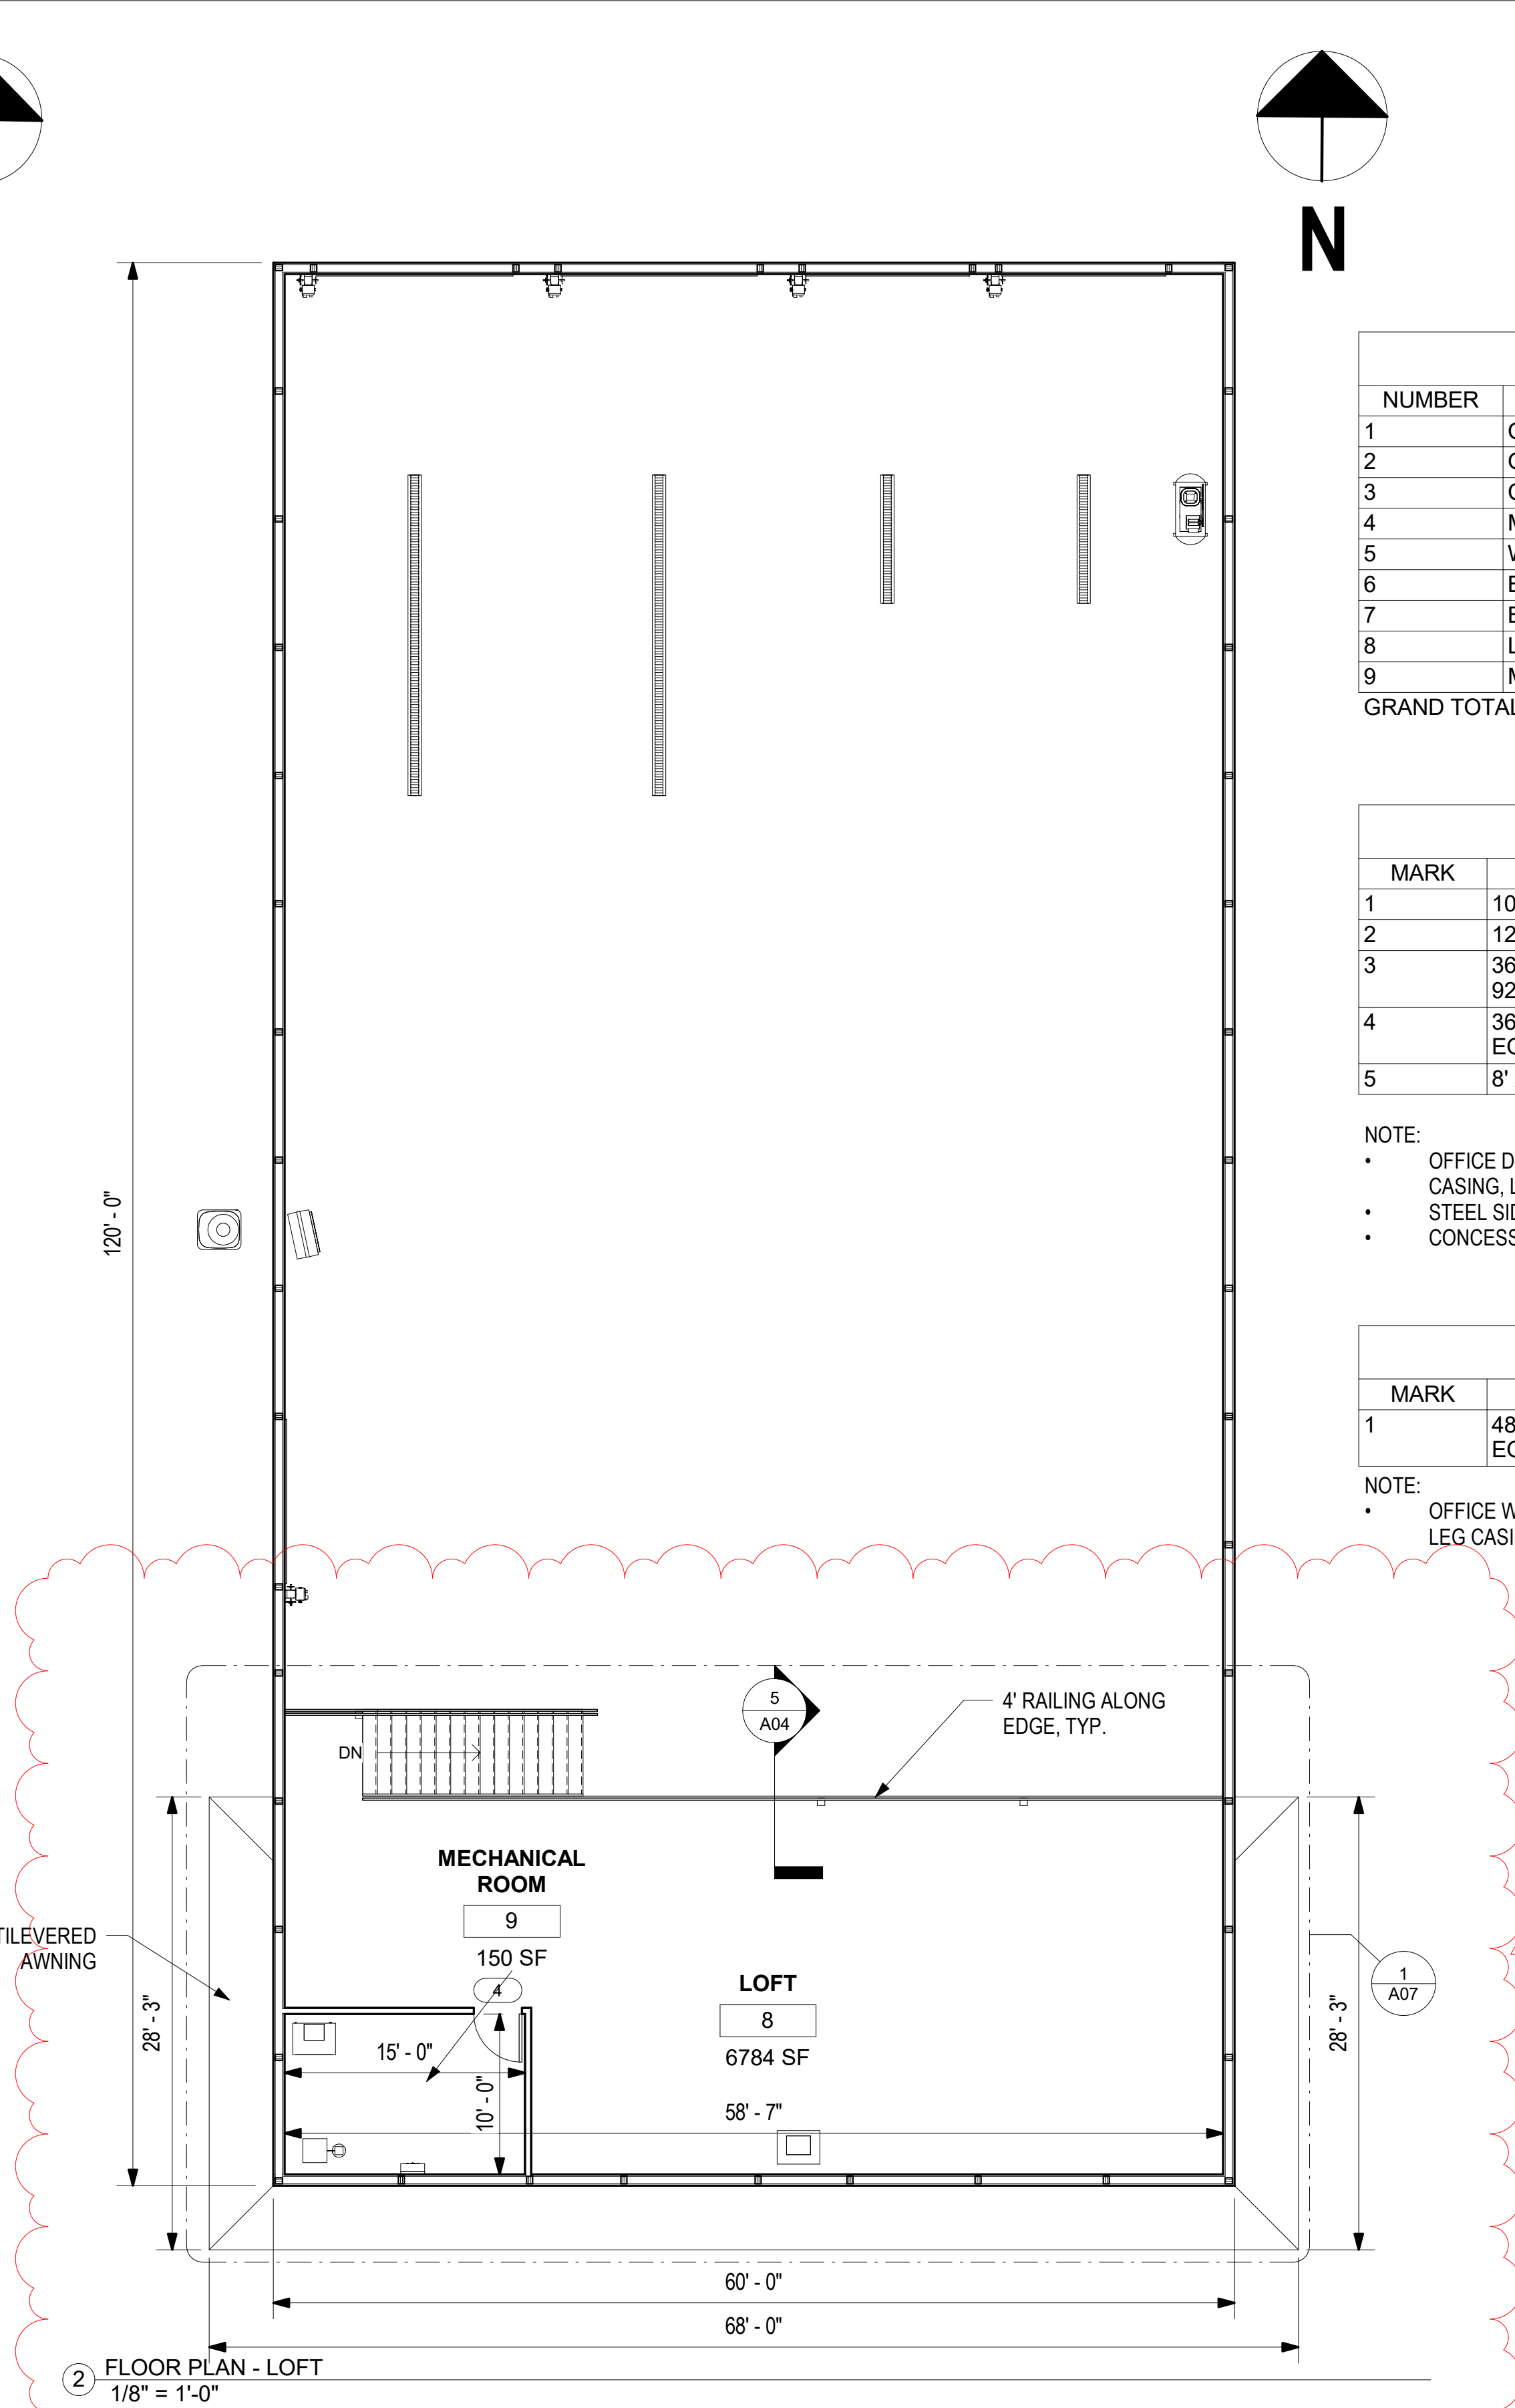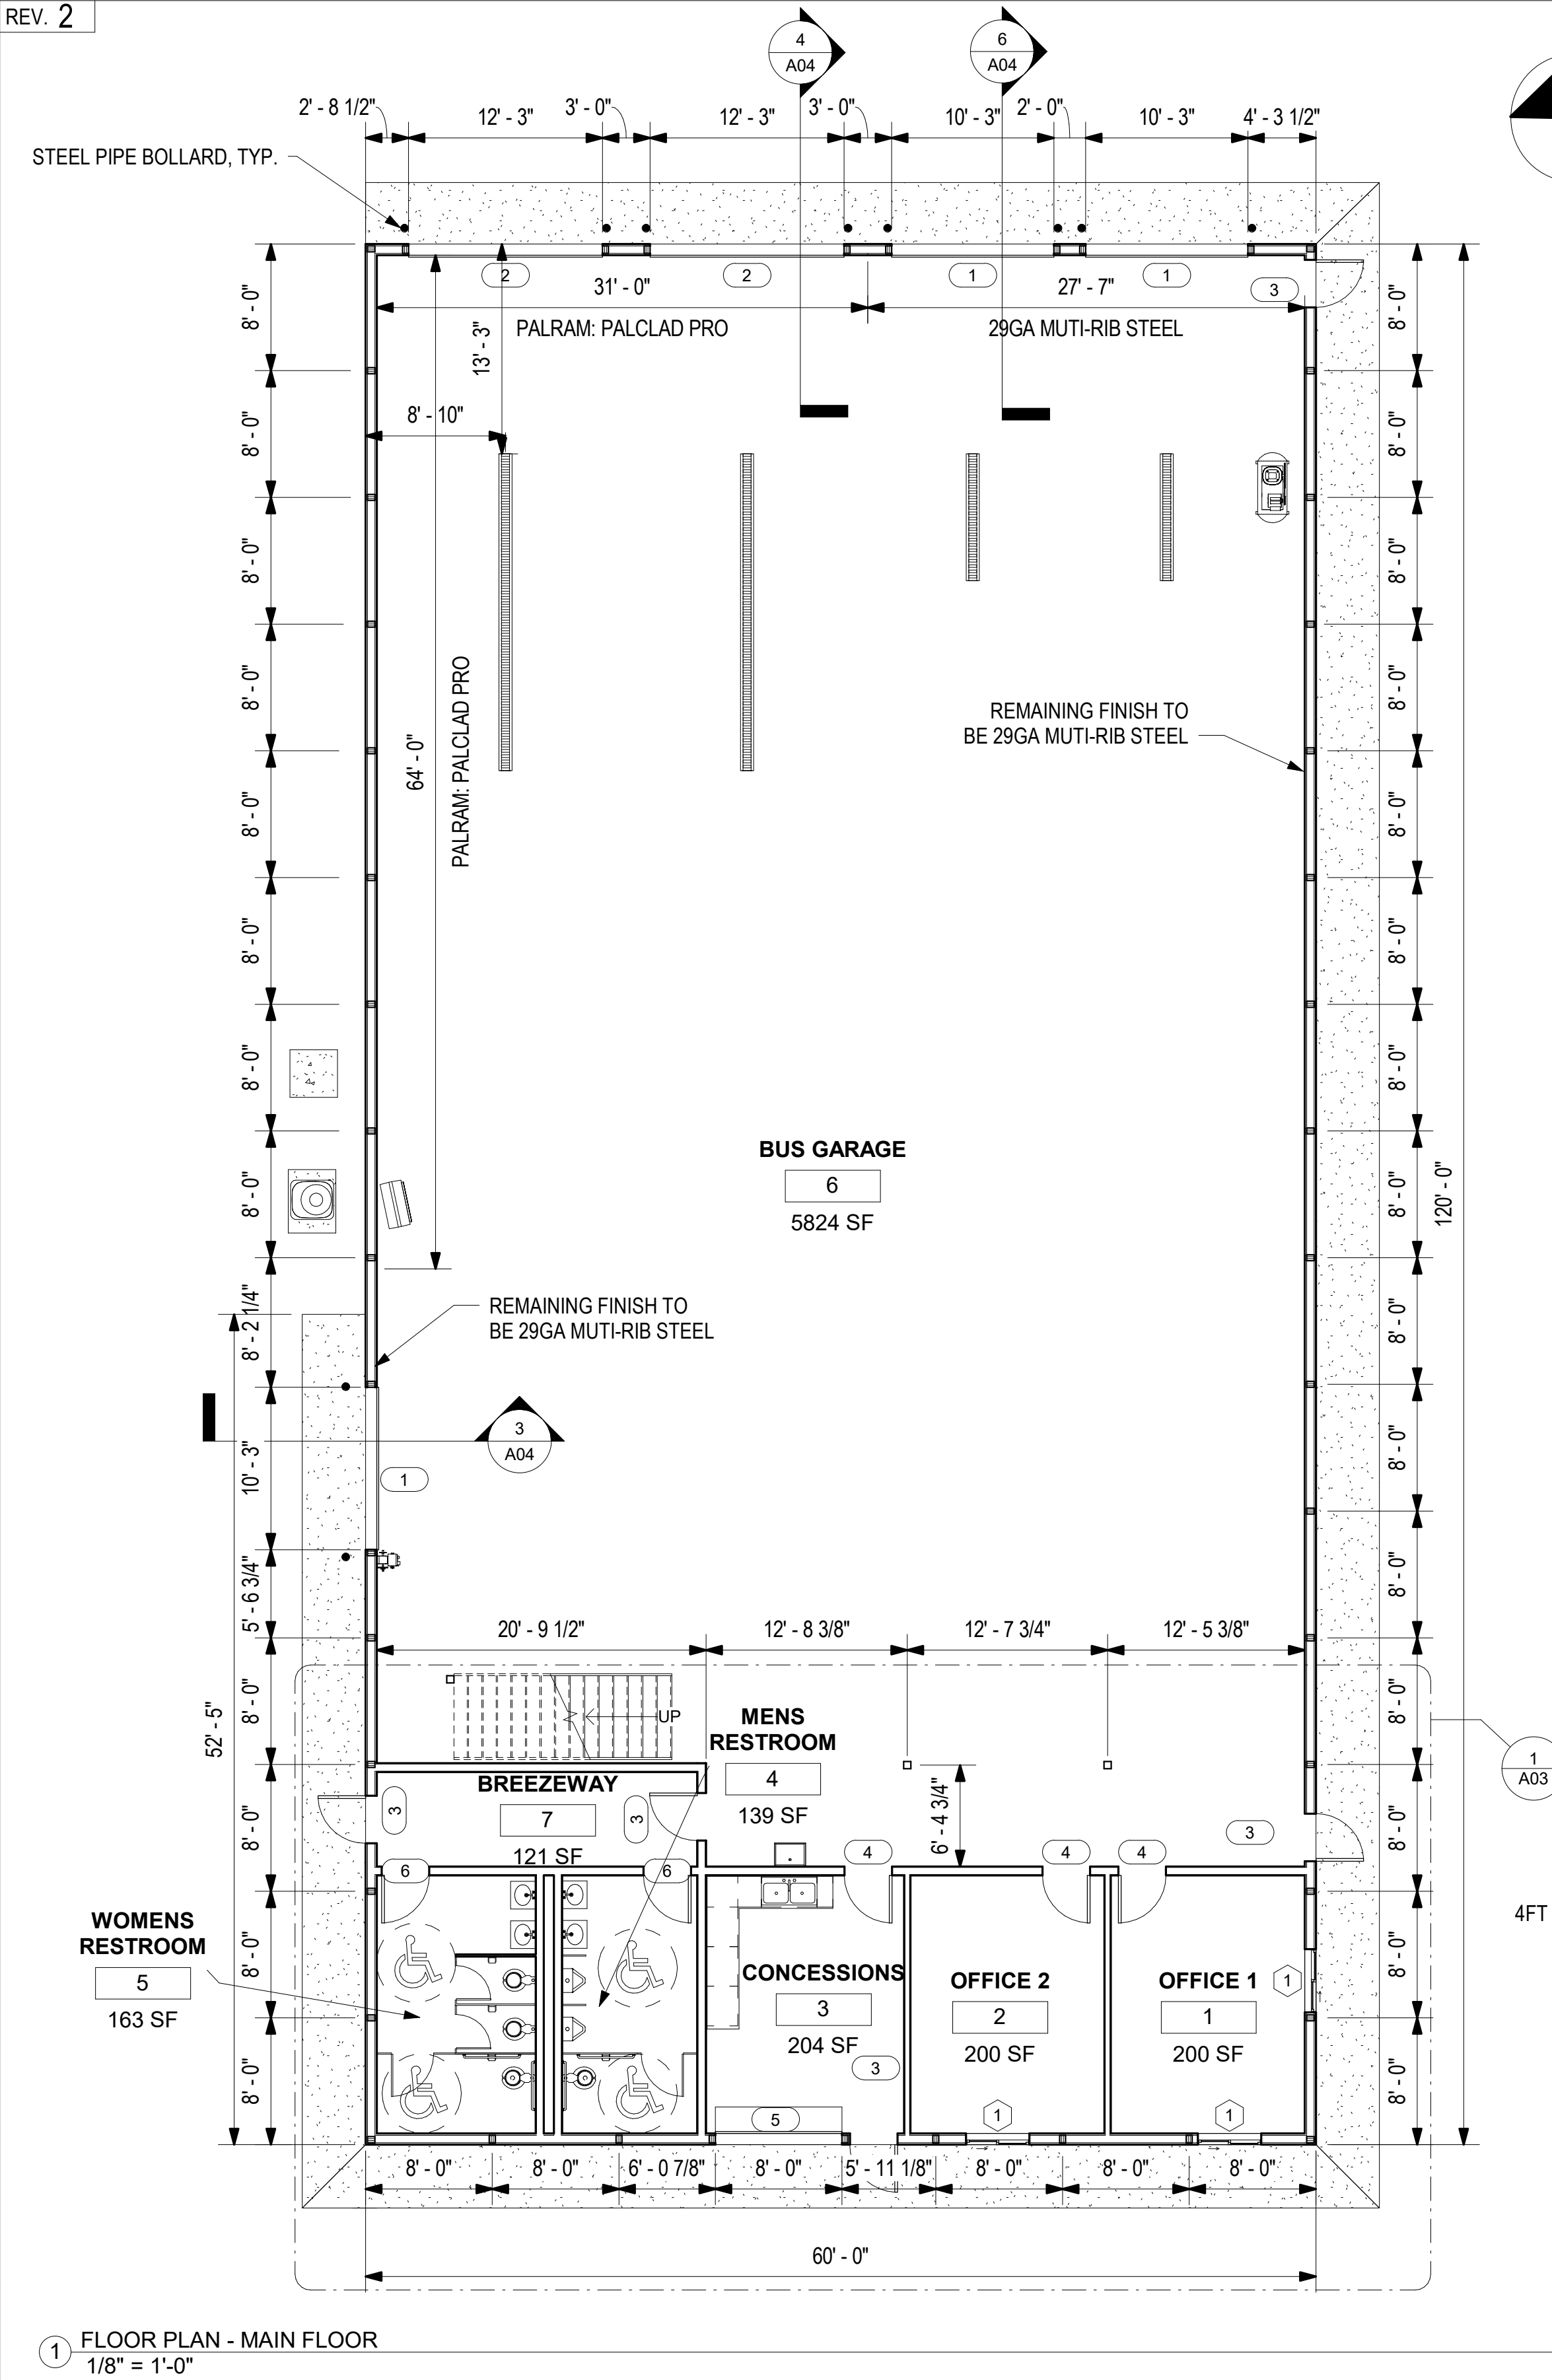

ROOM SCHEDULE				
NUMBER	NAME	AREA	LOAD FACTOR	OCCUPANT LOAD
1	OFFICE 1	200 SF	100 SF	3
2	OFFICE 2	200 SF	100 SF	3
3	CONCESSIONS	204 SF	200 SF	2
4	MENS RESTROOM	139 SF	45 SF	4
5	WOMENS RESTROOM	163 SF	45 SF	4
6	BUS GARAGE	5824 SF	300 SF	20
7	BREEZEWAY	121 SF	0 SF	
8	LOFT	6784 SF	300 SF	23
9	MECHANICAL ROOM	150 SF	300 SF	1
GRAND TOTAL		13783 SF		59

DOOR SCHEDULE		
MARK	TYPE	COUNT
1	10'X10' OHD, CLOPAY MODEL 3720	3
2	12'X14' OHD, CLOPAY MODEL 3720	2
3	36" x 84" EXTERIOR INSULATED COMMERCIAL DOOR (PLYCO 92 SERIES OR EQUIVALENT)	5
4	36" x 84" INTERIOR COMMERCIAL DOOR (PLYCO 92 SERIES OR EQUIVALENT)	6
5	8' x 4' ROLL UP CONCESSION DOOR, CLOPAY MODEL 150C	1

- NOTE:
- OFFICE DOOR INTERIORS TO BE TRIMMED W/ VINYL NO MITERED TRIM (HEAD CASING, LEG CASING)
 - STEEL SIDING TRIMOUT PER MANUFACTURERS RECOMMENDATIONS
 - CONCESSIONS DOOR TO BE FLASHED ON RETURNS

WINDOW SCHEDULE		
MARK	TYPE	COUNT
1	48" x 36" INSULATED VIYNL SLIDER W/ SCREEN (PLYCO CTB OR EQUIVALENT)	3

- NOTE:
- OFFICE WINDOWS TO BE TRIMMED W/ VINYL NO MITERED TRIM (HEAD CASING, LEG CASING, STOOL/HORN, APRON)

FINISH SCHEDULE									
NUMBER	NAME	FLOOR FINISH	BASE FINISH	WALL FINISH				CEILING FINISH	
				NORTH	SOUTH	EAST	WEST		
1	OFFICE 1	VINYL PLANK FLOORING	4" PVC VINYL WALL BASE MOLDING	5/8" DRYWALL	5/8" DRYWALL	5/8" DRYWALL	5/8" DRYWALL	5/8" DRYWALL	
2	OFFICE 2	VINYL PLANK FLOORING	4" PVC VINYL WALL BASE MOLDING	5/8" DRYWALL	5/8" DRYWALL	5/8" DRYWALL	5/8" DRYWALL	5/8" DRYWALL	
3	CONCESSIONS	CONCRETE - UNFINISHED	4" PVC VINYL WALL BASE MOLDING	5/8" DRYWALL	5/8" DRYWALL	5/8" DRYWALL	5/8" DRYWALL	5/8" DRYWALL	
4	MENS RESTROOM	CONCRETE - UNFINISHED	4" PVC VINYL WALL BASE MOLDING	*PALRAM: PALCLAD PRO	*PALRAM: PALCLAD PRO	*PALRAM: PALCLAD PRO	*PALRAM: PALCLAD PRO	*PALRAM: PALCLAD PRO	
5	WOMENS RESTROOM	CONCRETE - UNFINISHED	4" PVC VINYL WALL BASE MOLDING	*PALRAM: PALCLAD PRO	*PALRAM: PALCLAD PRO	*PALRAM: PALCLAD PRO	*PALRAM: PALCLAD PRO	*PALRAM: PALCLAD PRO	
6	BUS GARAGE	CONCRETE - UNFINISHED	TRIM PER MANUFACTURER RECOMMENDATIONS	NW HALF TO BE *PALRAM: PALCLAD PRO; NE TO 29GA MULTI-RIB	29GA MULTI-RIB	29GA MULTI-RIB	*PALRAM: PALCLAD PRO	29GA MULTI-RIB	
7	BREEZEWAY	CONCRETE - UNFINISHED	4" PVC VINYL WALL BASE MOLDING	*PALRAM: PALCLAD PRO	*PALRAM: PALCLAD PRO	*PALRAM: PALCLAD PRO	*PALRAM: PALCLAD PRO	*PALRAM: PALCLAD PRO	
8	LOFT	3/4" T&G DECKING - UNFINISHED	-	-	29GA MULTI-RIB	29GA MULTI-RIB	29GA MULTI-RIB	29GA MULTI-RIB	
9	MECHANICAL ROOM	3/4" T&G DECKING - UNFINISHED	-	5/8" TYPE-X DRYWALL	5/8" TYPE-X DRYWALL	5/8" TYPE-X DRYWALL	5/8" TYPE-X DRYWALL	5/8" TYPE-X DRYWALL	

1 NOTE: PALRAM PALCLAD PRO SHOULD BE ADHERED TO 5/8" PLYWOOD OR DRYWALL. SELECT ADHESIVE PER MANUFACTURERS RECOMMENDATIONS.

MSS Engineering, LLC
ENGINEERING, CONSULTING & DESIGN
414 W 5th St., Auburn, IN 46706
Phone: (260) 267-7414
Email: tamcdaniel@mssengineer.com
Travis A. McDaniel, PE

Travis A. McDaniel
05/26/23

PROJECT LOCATION:
560 S 900 E
MARION, IN 46953

PROJECT NAME:
BID SPEC &
DESIGN


DRAWING TITLE:
FLOOR PLAN

REVISIONS:			
NO.	DATE	DESCRIPTION	BY
1	5/18/23	UPDATE/CORRECT NOTATION	TAM
2	5/26/23	ADD TO AWNING LENGTH	TAM


JOB NUMBER:
22.081.171

DRAWN BY: CAS
ENGINEERED BY: CAS

START DATE: 05/12/21
PROGRESS DATE: 7/13/21
CERTIFIED DATE: 05/26/23
SCALE: 1/8" = 1'-0"
PAGE NUMBER:

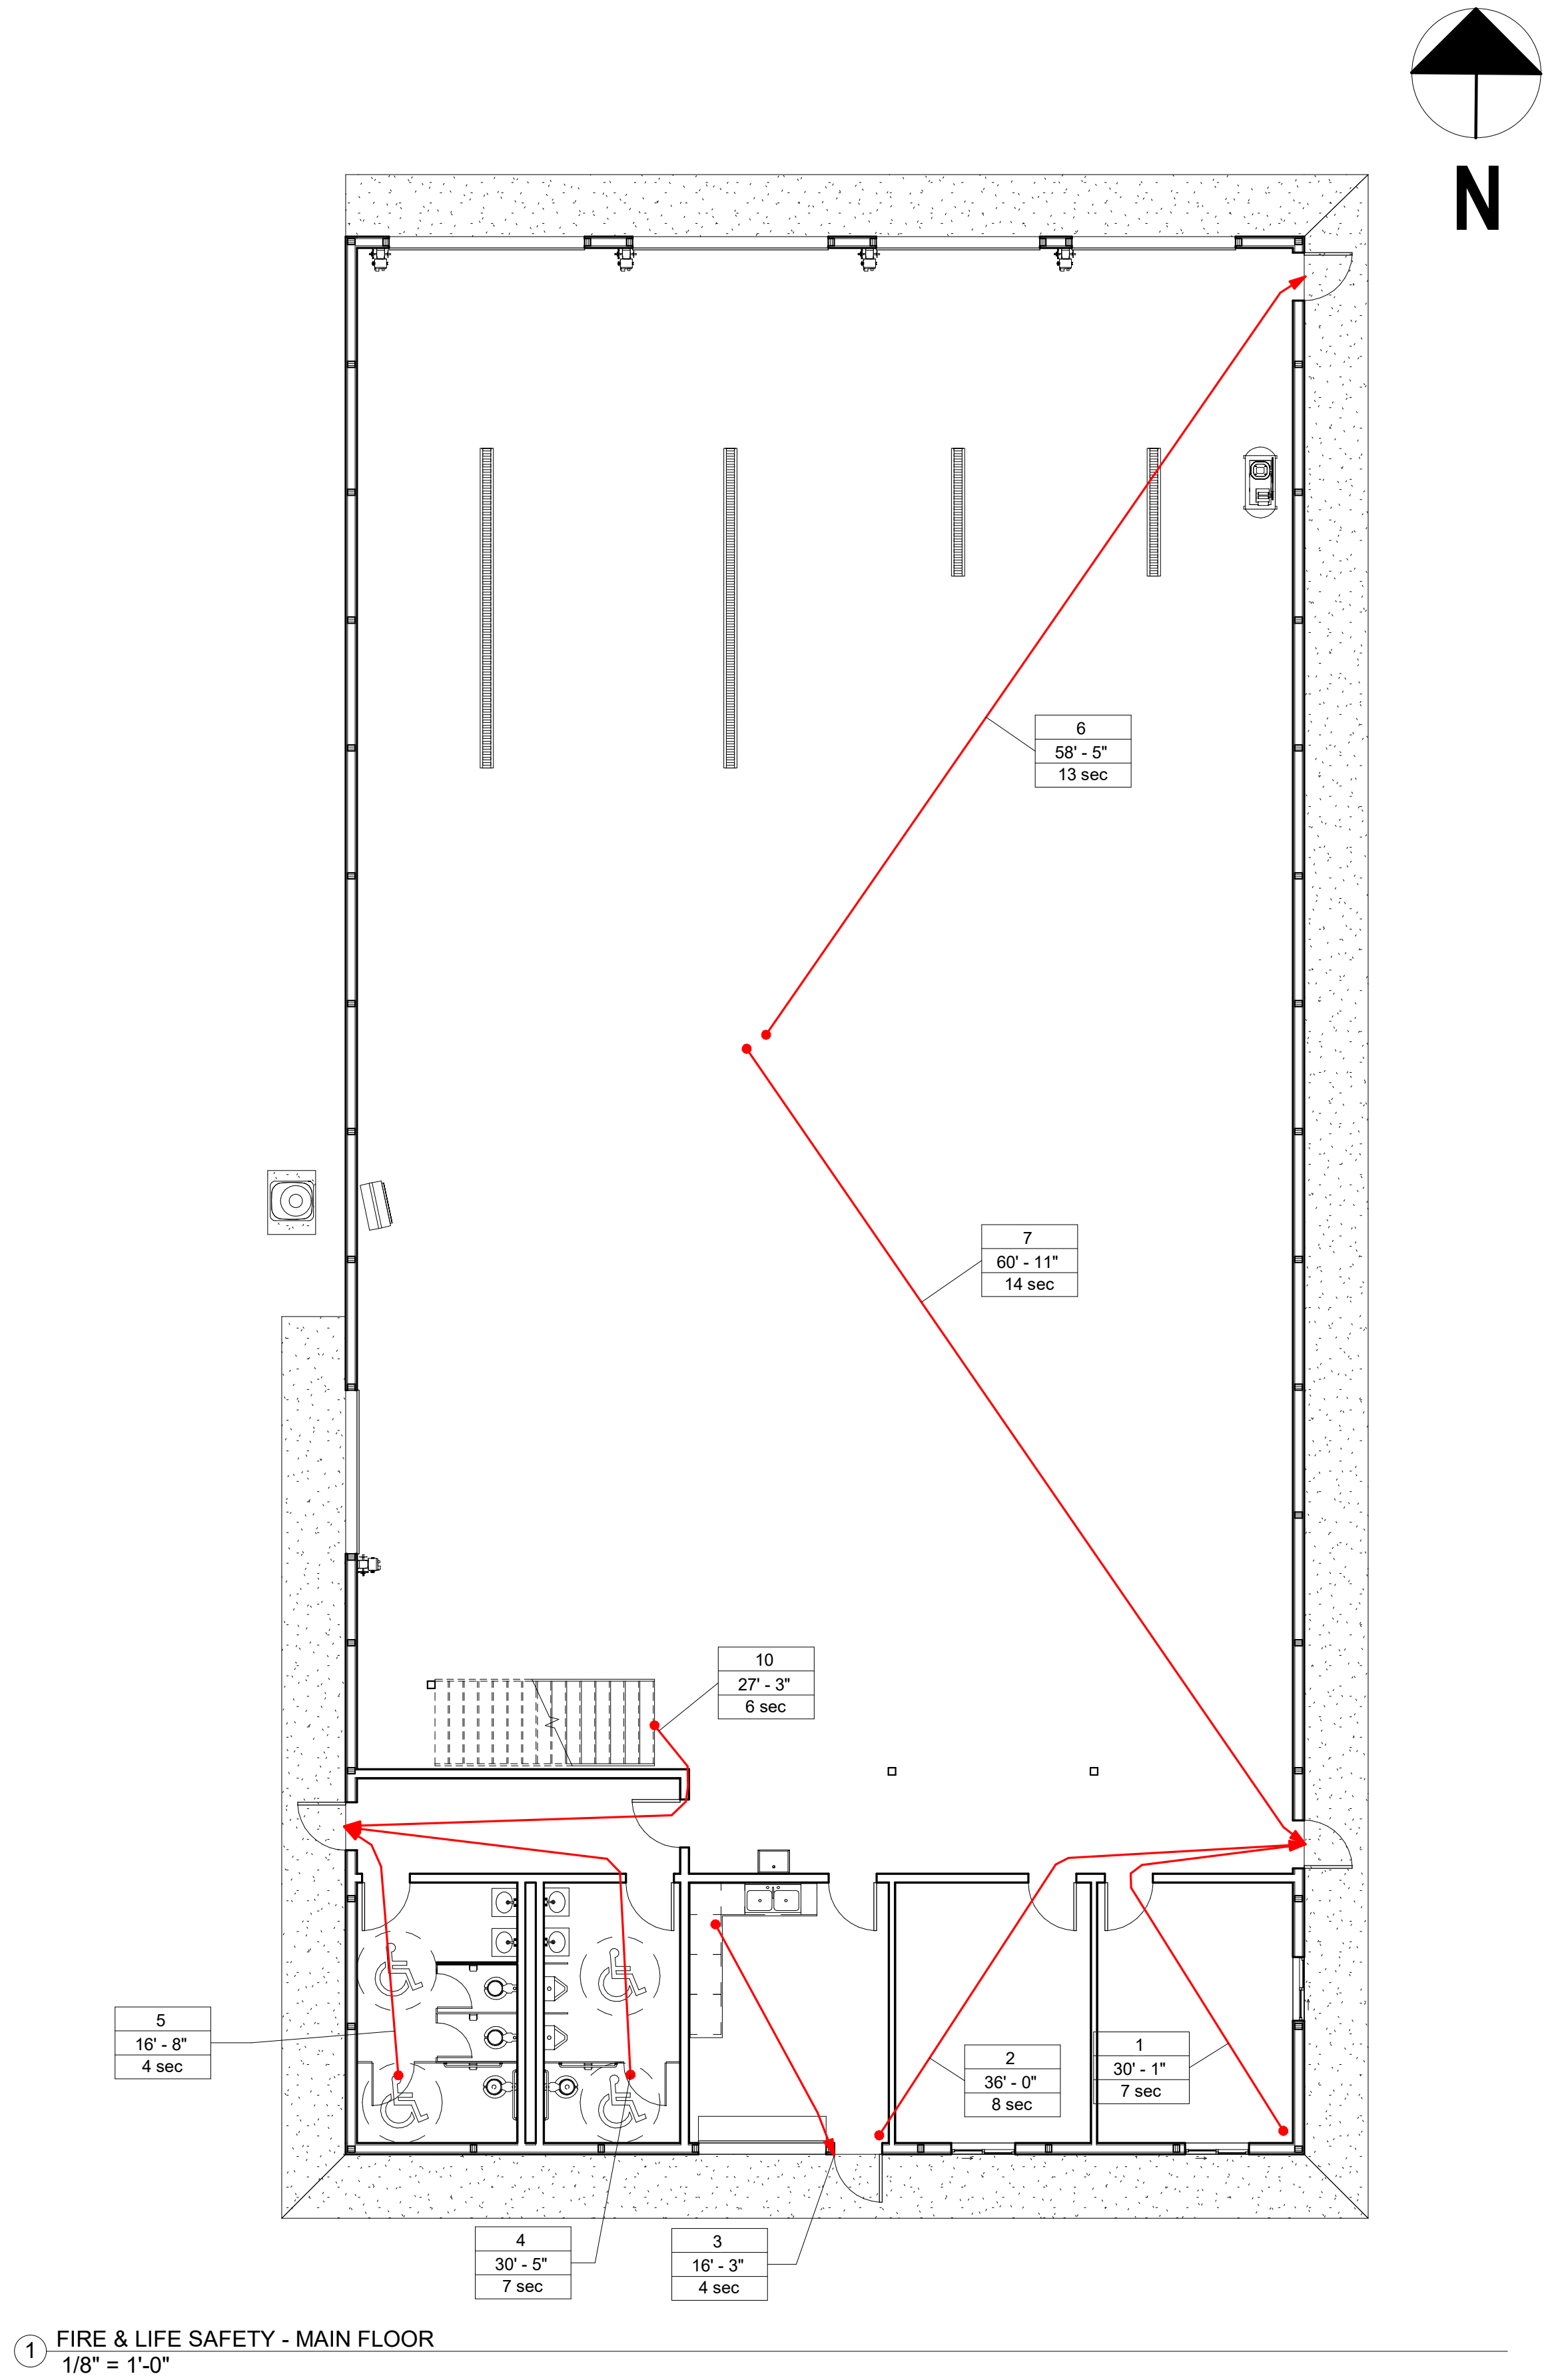


① FIRE & LIFE SAFETY - MAIN FLOOR
1/8" = 1'-0"

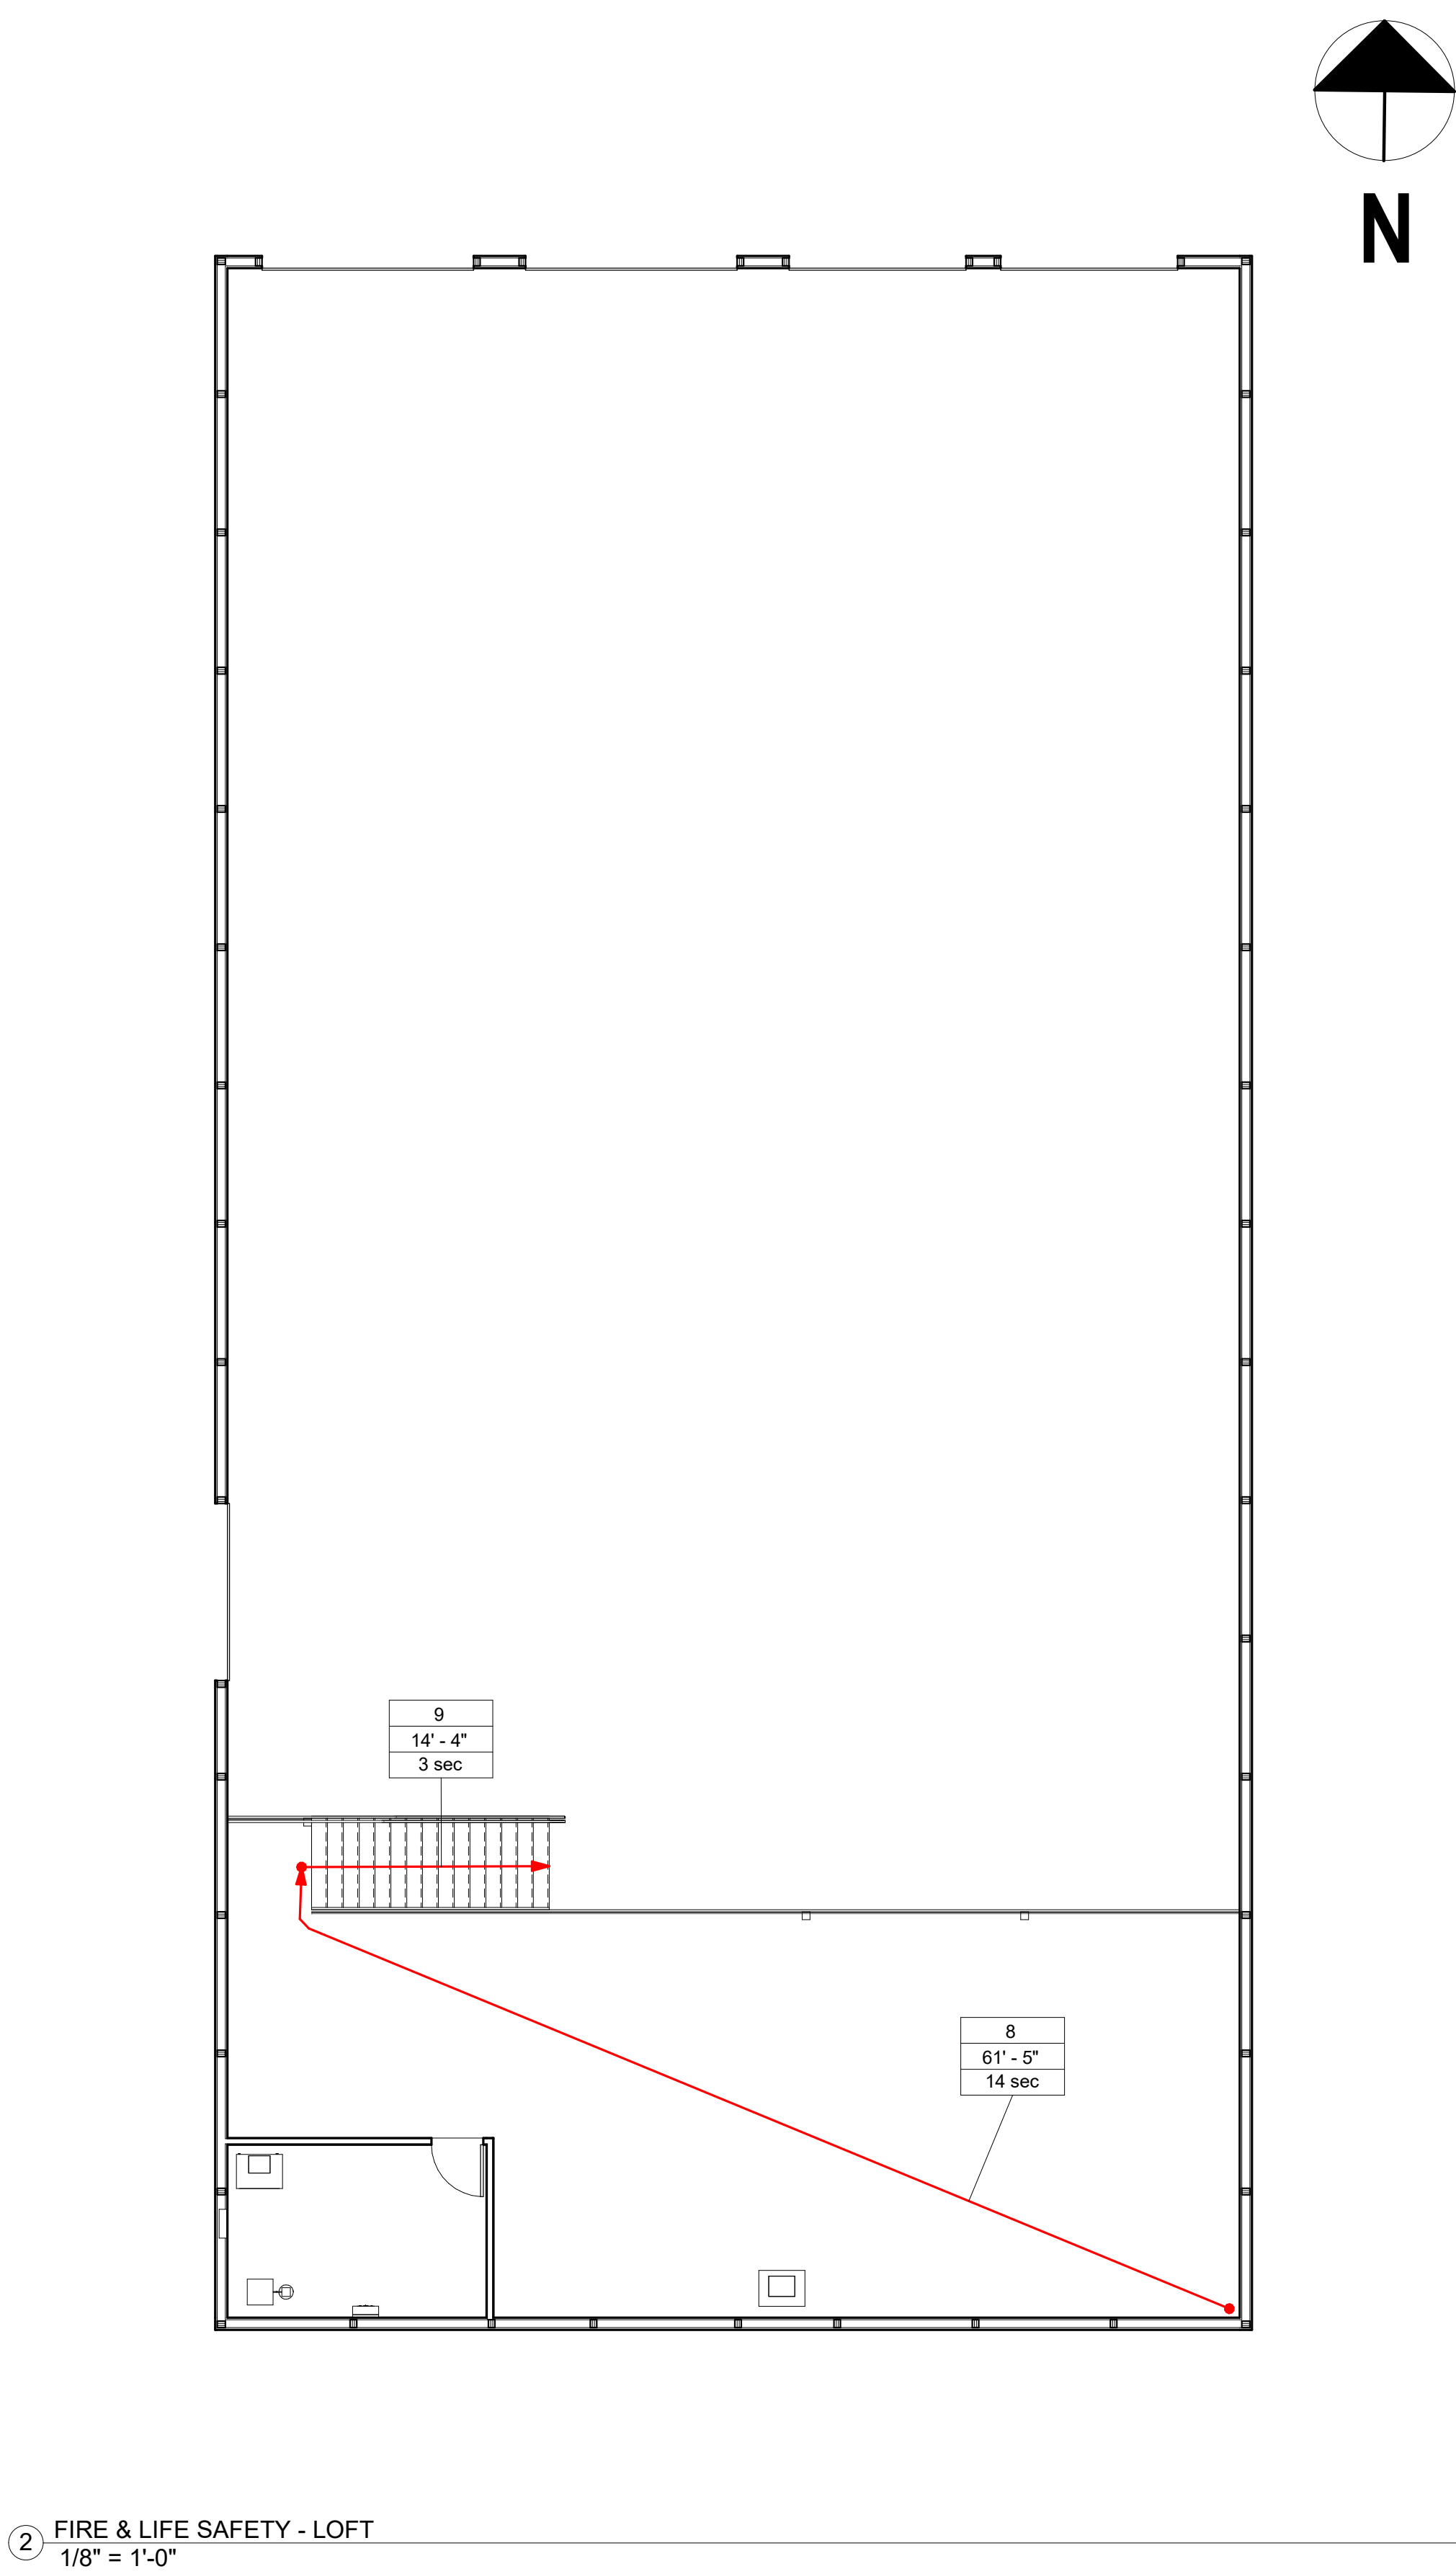

② FIRE & LIFE SAFETY - LOFT
1/8" = 1'-0"

PATH OF TRAVEL SCHEDULE			
MARK	LENGTH	SPEED	TIME
1	30' - 0 19/32"	3.0 mph	6.8 s
2	36' - 0 1/32"	3.0 mph	8.2 s
3	16' - 3 7/16"	3.0 mph	3.7 s
4	30' - 5 3/32"	3.0 mph	6.9 s
5	16' - 7 1/2"	3.0 mph	3.8 s
6	58' - 4 17/32"	3.0 mph	13.3 s
7	60' - 11 1/8"	3.0 mph	13.8 s
8	61' - 4 13/16"	3.0 mph	14.0 s
9	14' - 4"	3.0 mph	3.3 s
10	27' - 2 27/32"	3.0 mph	6.2 s

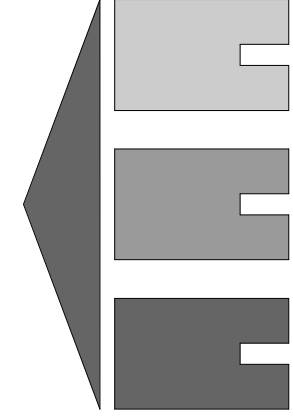

MSS Engineering, LLC
ENGINEERING, CONSULTING & DESIGN

414 W 5th St., Auburn, IN 46706
Phone: (260) 267-7414
Email: tamcdaniel@mssengineer.com
Travis A. McDaniel, PE



Travis A. McDaniel
05/26/23

PROJECT LOCATION:
560 S 900 E
MARION, IN 46953

PROJECT NAME:
BID SPEC &
DESIGN

DRAWING TITLE:
FIRE & LIFE
SAFETY PLAN

REVISIONS:			
NO.	DATE	DESCRIPTION	BY

JOB NUMBER:
22.081.171

DRAWN BY: CAS

ENGINEERED BY: CAS

START DATE: 05/12/21

PROGRESS DATE: 7/13/21

CERTIFIED DATE: 05/26/23


SCALE: 1/8" = 1'-0"

PAGE NUMBER:


A02 OF A09 SHEETS

REV.

CASEWORK SCHEDULE						
TAG	DESCRIPTION	HEIGHT	WIDTH	DEPTH	COUNT	FINISH
A	Base Cabinet-Double Door & 2 Drawer	2' - 10 1/2"	2' - 6"	2' - 0"	3	Painted Cabinets w/ Laminate Doors and Door Fronts
B	Base Cabinet-Single Door & Drawer	2' - 10 1/2"	1' - 6"	2' - 0"	1	Painted Cabinets w/ Laminate Doors and Door Fronts
C	Base Cabinet-Single Door & Drawer	2' - 10 1/2"	1' - 0"	2' - 0"	1	Painted Cabinets w/ Laminate Doors and Door Fronts
D	Base Cabinet-Double Door Sink Unit	2' - 10 1/2"	3' - 6"	2' - 0"	1	Painted Cabinets w/ Laminate Doors and Door Fronts
E	Counter Top-L Shaped w Sink	3' - 0"		2' - 1"	1	Laminate
F	Counter Top	3' - 0"		1' - 8"	1	Stainless Steel

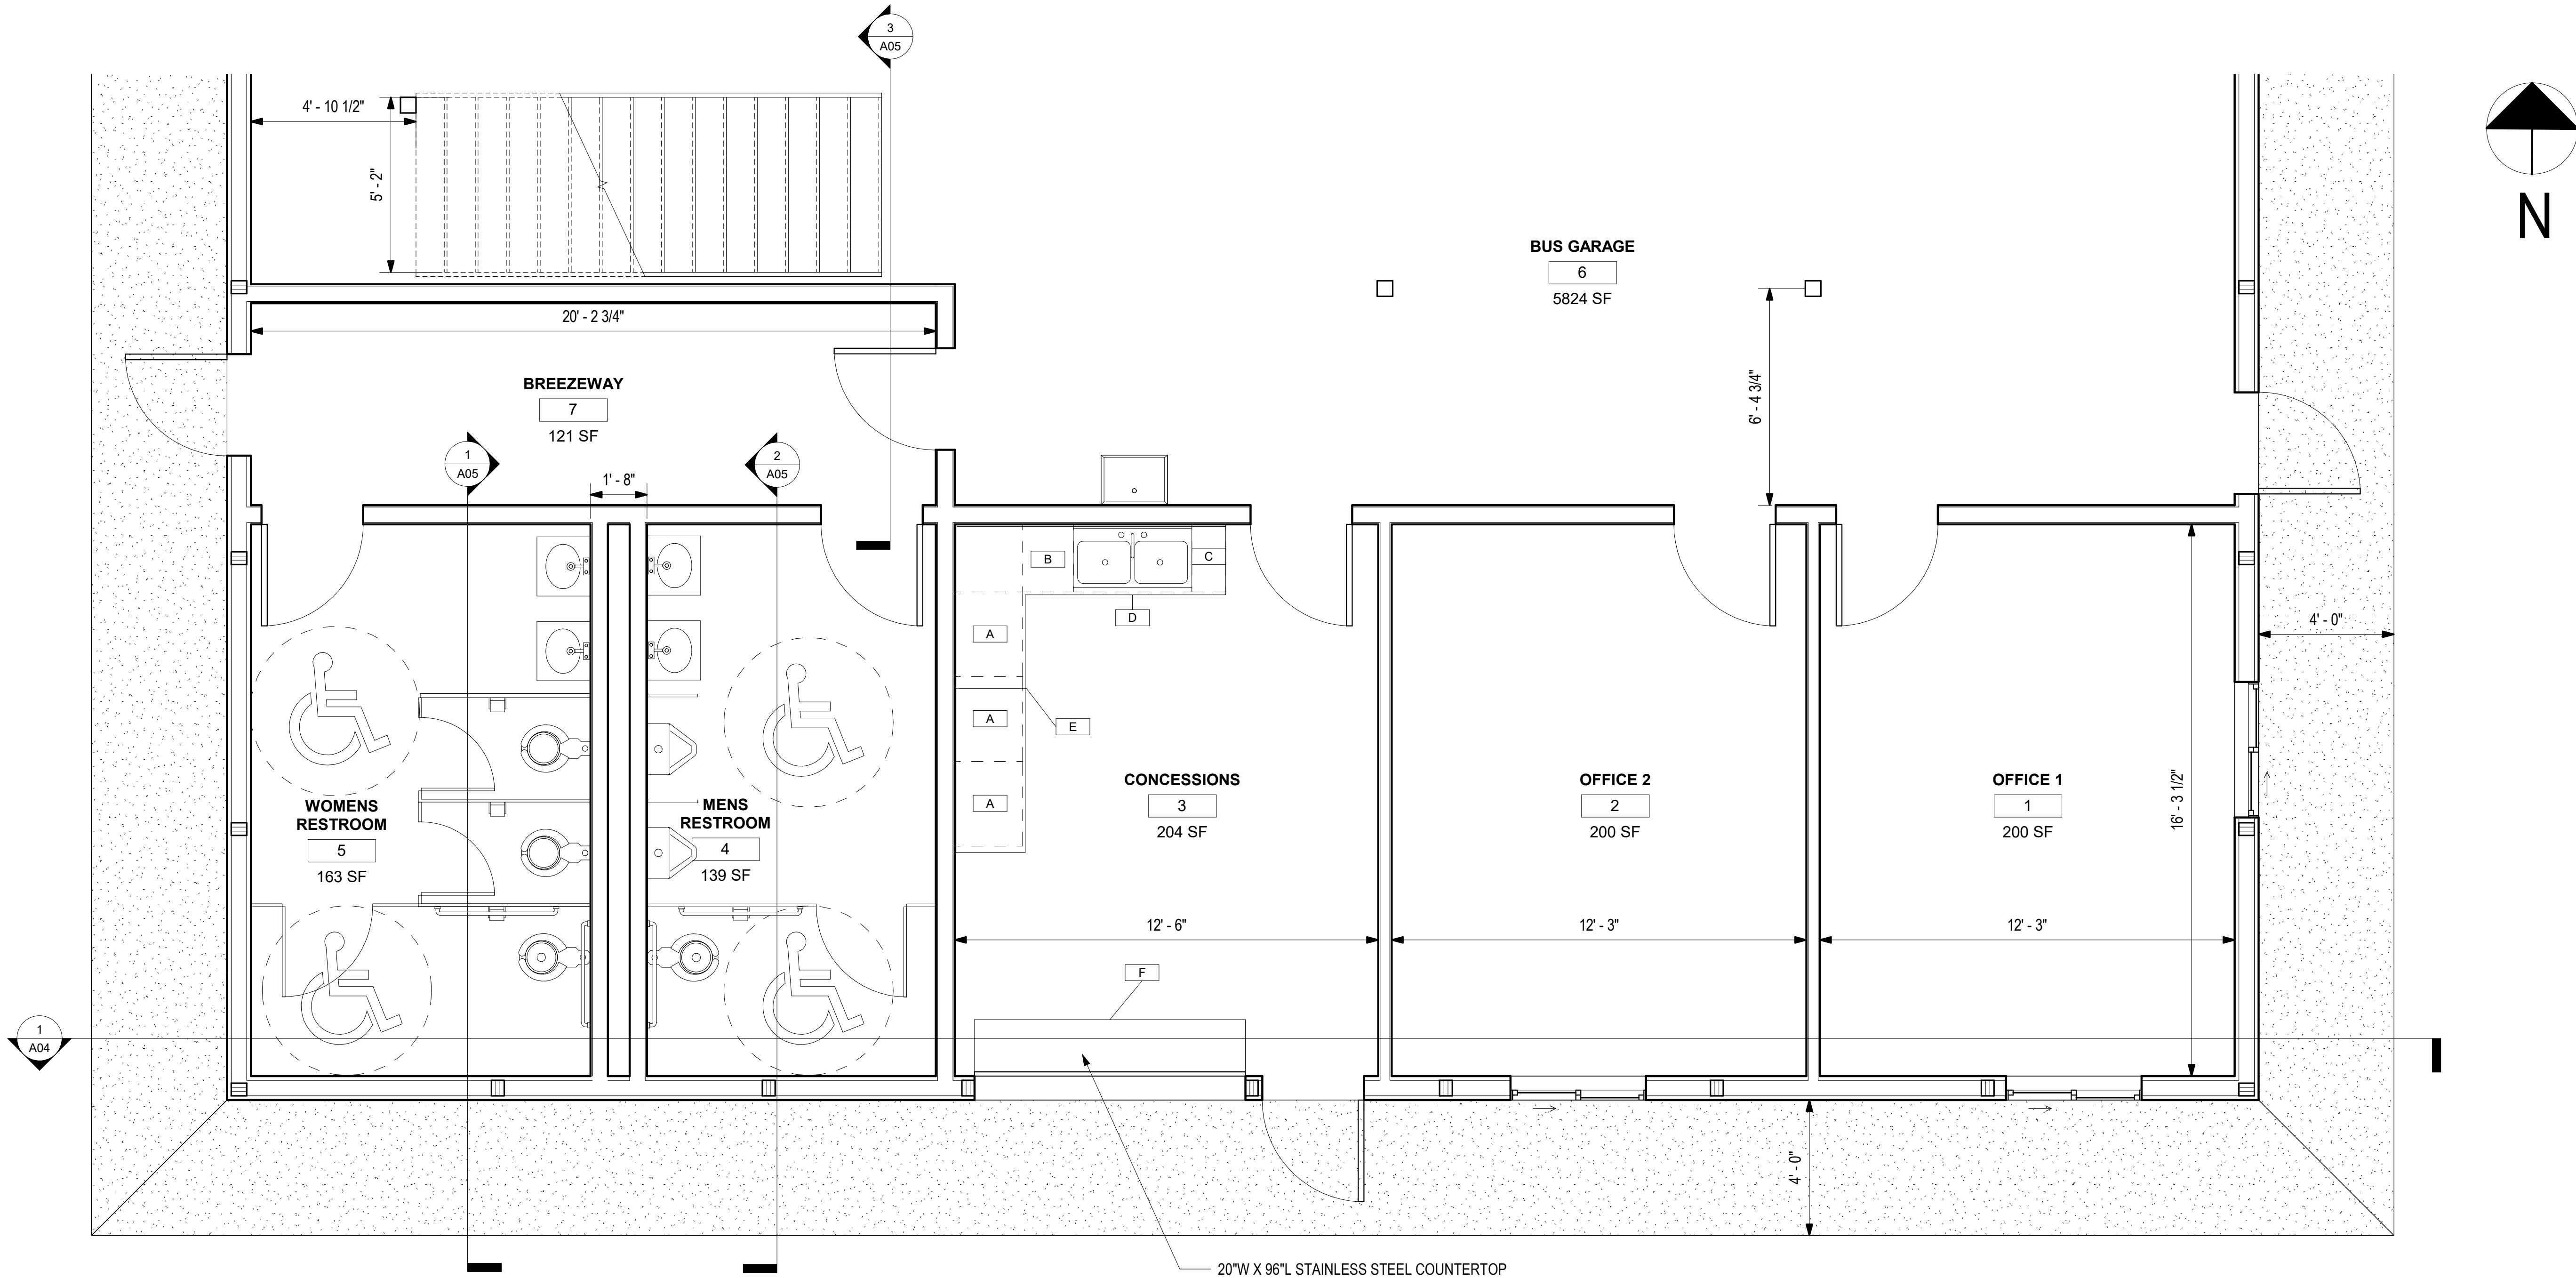


1 FLOOR PLAN - MAIN FLOOR - CALLOUT
3/8" = 1'-0"

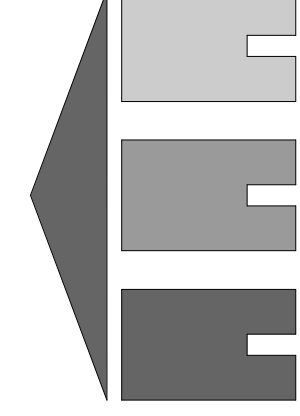

MSS Engineering, LLC
ENGINEERING, CONSULTING & DESIGN

414 W 5th St., Auburn, IN 46706
Phone: (260) 267-7414
Email: tamcdaniel@mssengineer.com

Travis A. McDaniel, PE

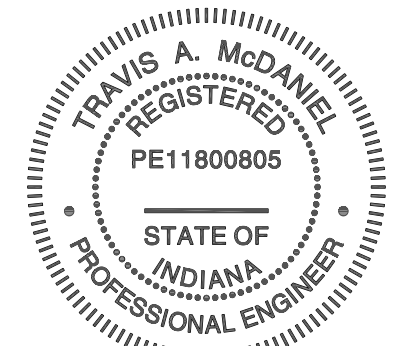

Travis A. McDaniel
05/26/23

PROJECT LOCATION:
560 S 900 E
MARION, IN 46953

PROJECT NAME:
BID SPEC &
DESIGN




DRAWING TITLE:
FLOOR PLAN -
MAIN FLOOR
CALLOUTS

REVISIONS:			
NO.	DATE	DESCRIPTION	BY

JOB NUMBER:
22.081.171

DRAWN BY: CAS	ENGINEERED BY: CAS
----------------------	---------------------------

  
START DATE: 05/12/21
PROGRESS DATE: 7/13/21
CERTIFIED DATE: 05/26/23
SCALE: 3/8" = 1'-0"
PAGE NUMBER:

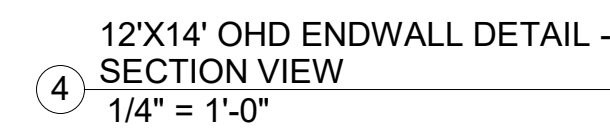

414 W 5th St., Auburn, IN 46706

Phone: (260) 267-7414

Email: tamcdaniel@mssengineer.com
 Travis A. McDaniel, PE

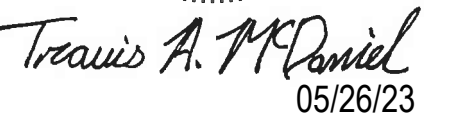

PROJECT LOCATION:

560 S 900 E
MARION, IN 46953

PROJECT NAME:
BID SPEC &
DESIGN

DRAWING TITLE: BUILDING SECTION VIEWS AND DETAILS

REVISIONS:

JOB NUMBER:
22.081.171

DRAWN
BY: CAS

ENGINEERED
BY: CAS

START DATE: 05/12/21

PROGRESS DATE: 7/13/21

 
 
 
CERTIFIED DATE: 05/26/23

SCALE: As indicated

PAGE NUMBER:


A04 OF A09 SHEETS

y.



414 W 5th St., Auburn, IN 46706
Phone: (260) 267-7414

Email: tamcdaniel@mssengineer.com
Travis A. McDaniel, PE

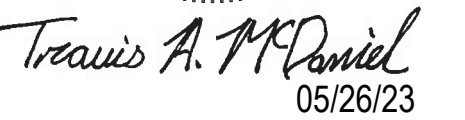

PROJECT LOCATION:

560 S 900 E
MARION, IN 46953

PROJECT NAME:

**BID SPEC &
DESIGN**

DRAWING TITLE:
RESTROOM AND
STAIR SECTION
VIEWS

REVISIONS:

JOB NUMBER:
22.081.171

DRAWN
BY: CAS

**ENGINEERED
BY: CAS**


START DATE: 05/12/21

PROGRESS DATE: 7/13/21

CERTIFIED DATE: 05/26/23


SCALE: 1/2" = 1'-0"

PAGE NUMBER:

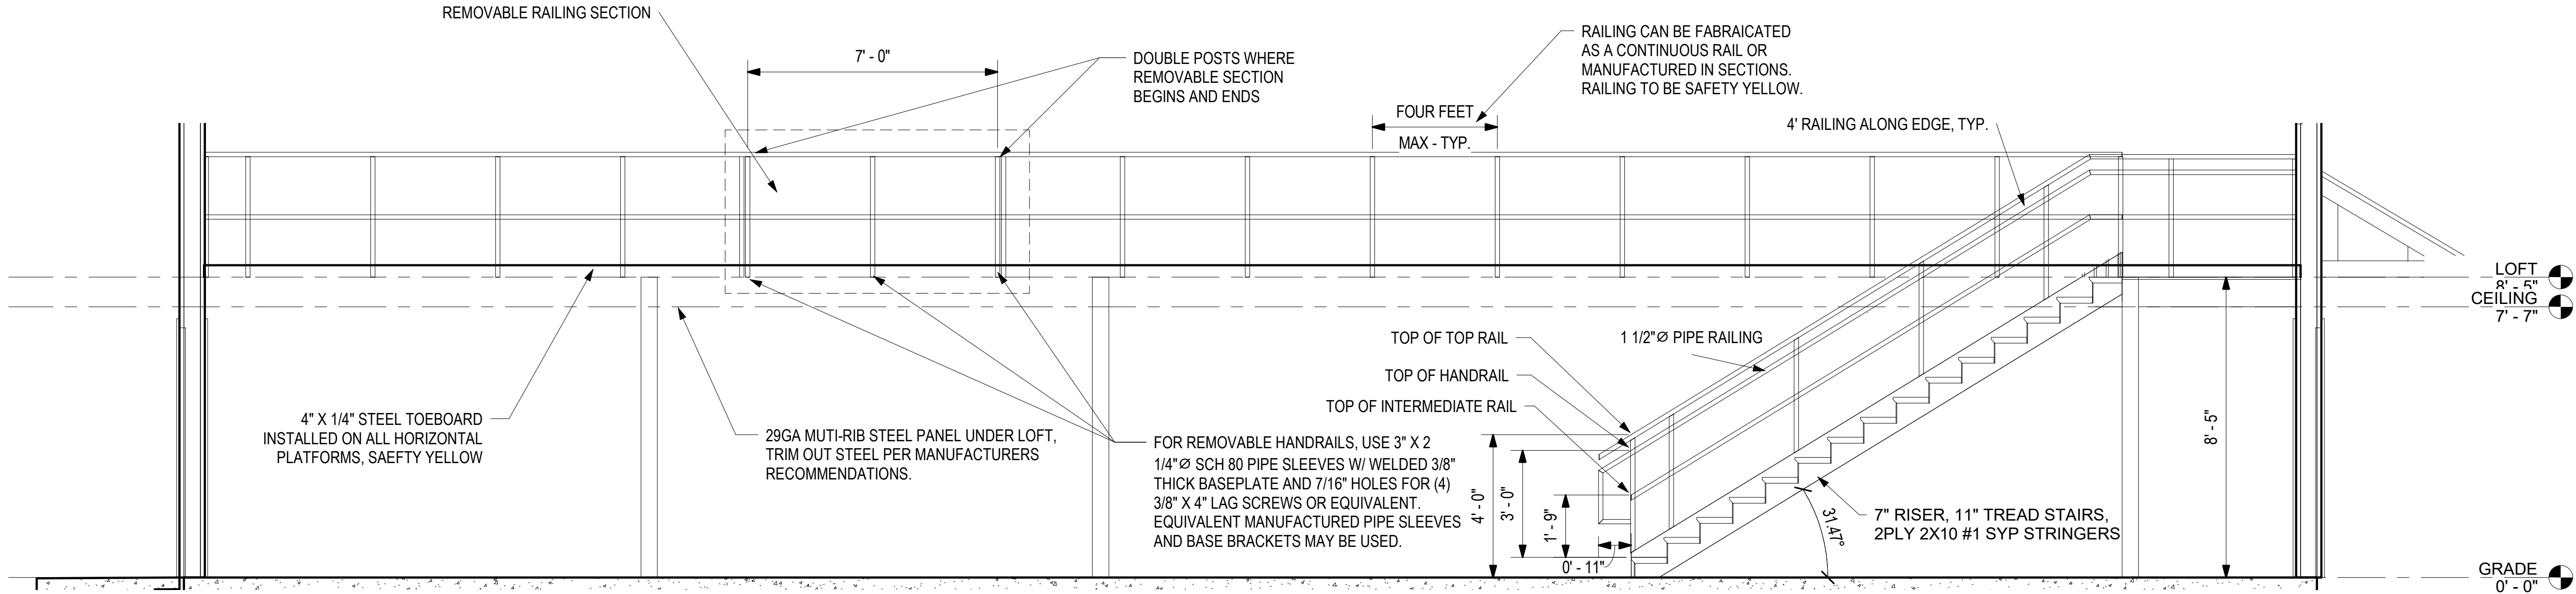


2 STAIRWELL - SECTION VIEW 3
3/8" = 1'-0"

NOTE: 3" X 2 1/4" Ø SCH 80 PIPE SLEEVES FOR
BASE BRACKET, MANUFACTURED PIPE
SLEEVES AND BASE BRACKETS MAY BE USED.
(SIMILAR TO MCMASTER-CARR 5062T45)
FASTEN TO WOOD FRAMING W/ (4) 3/8" X 4" LAG
SCREWS OR EQUIVALENT.

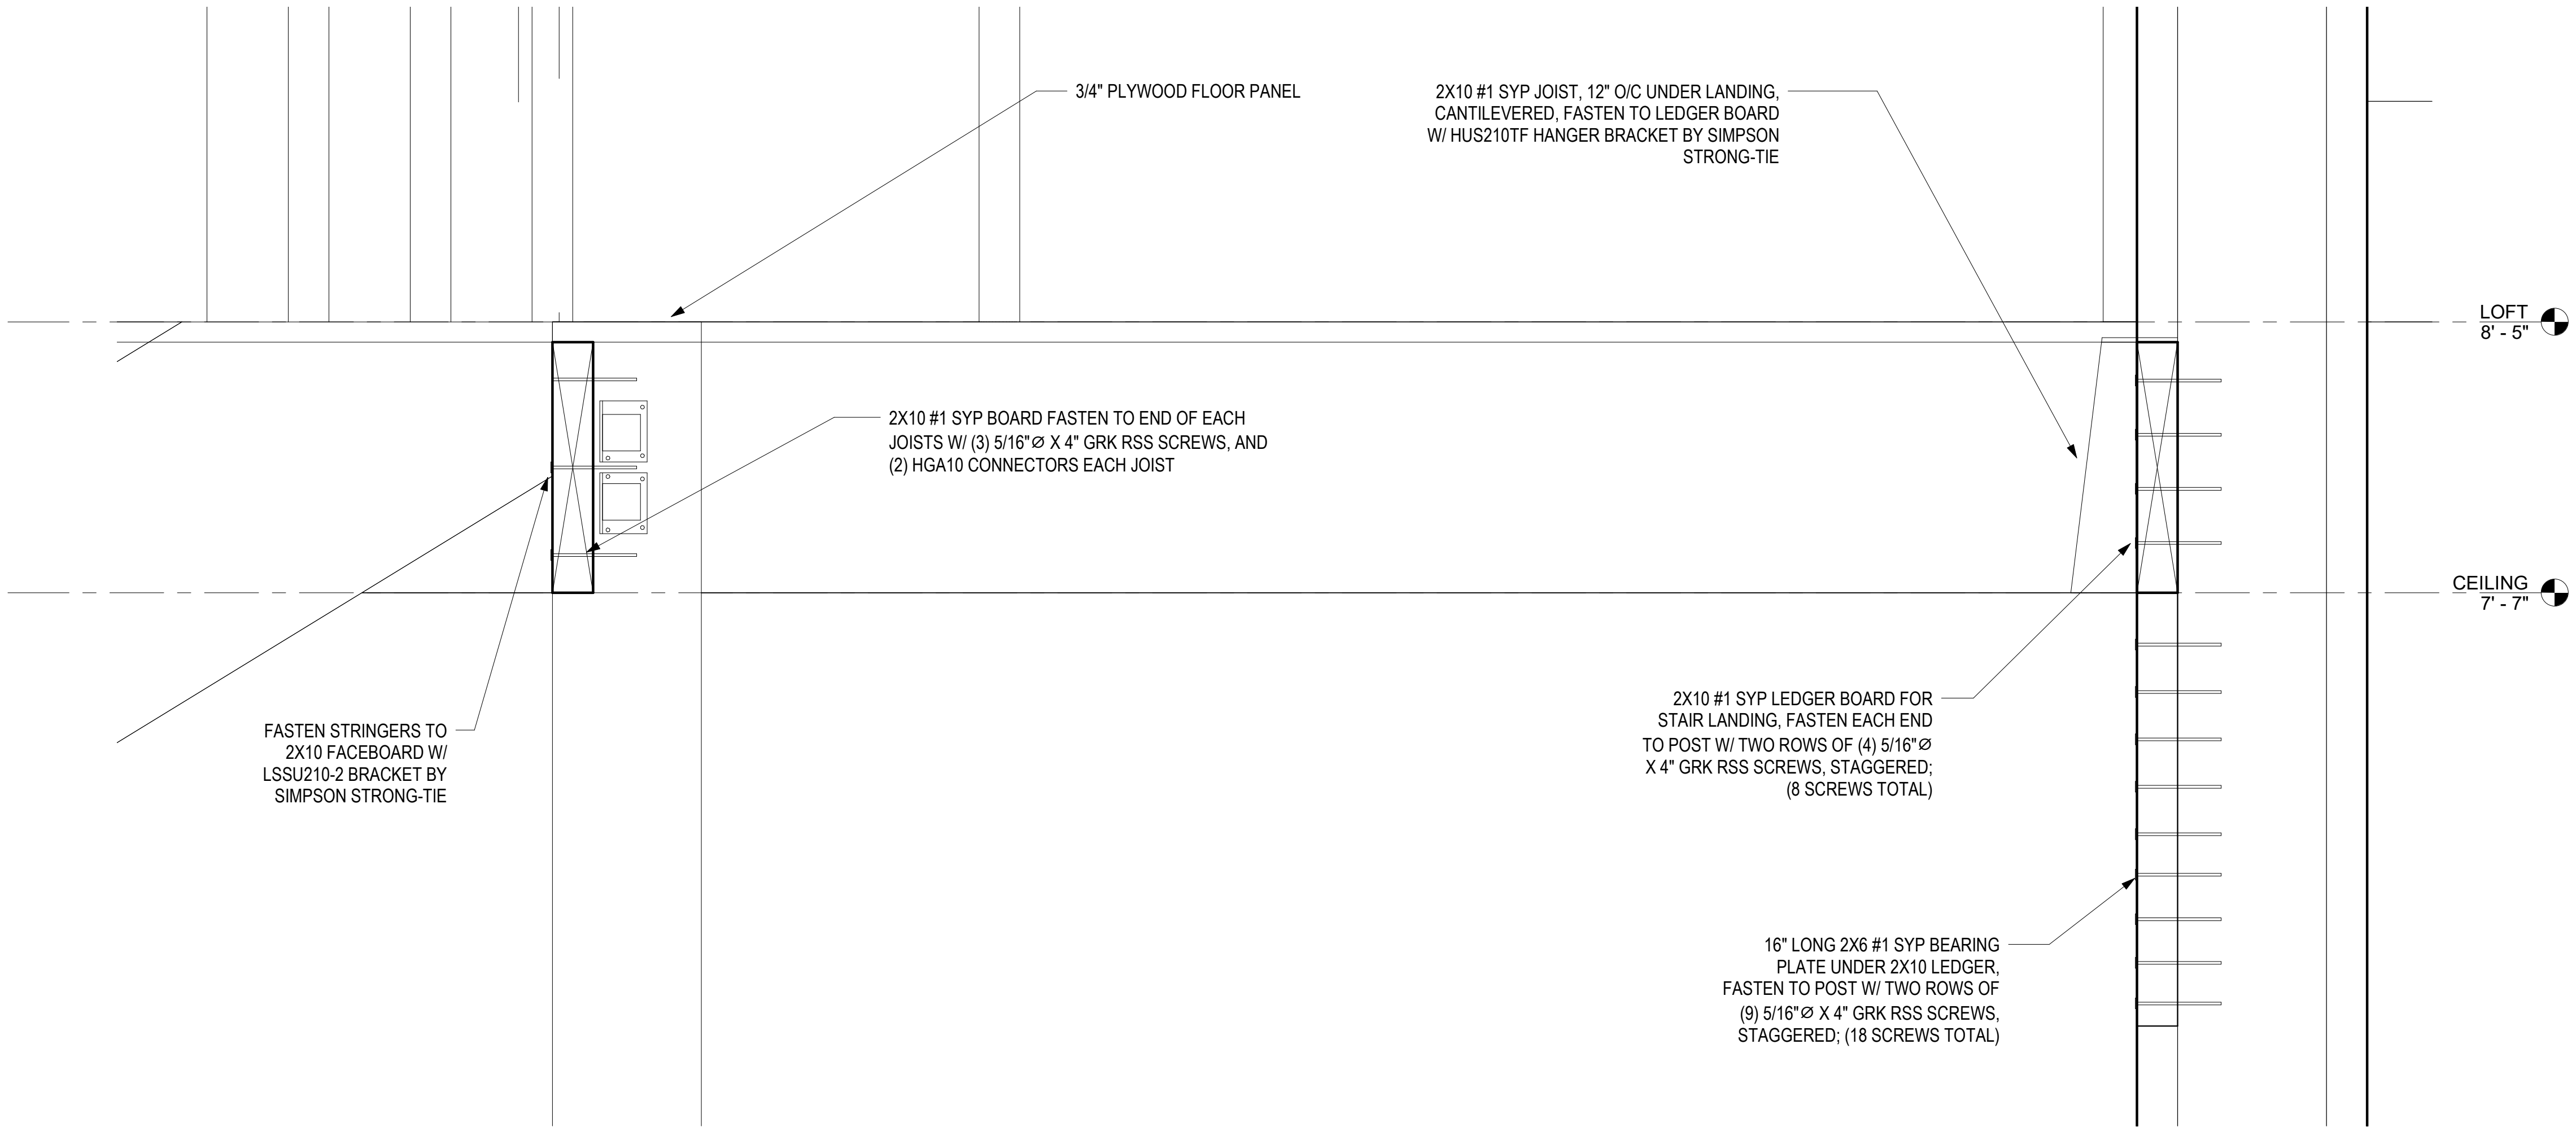

1 STAIRWELL - SECTION VIEW 2 -
CALLOUT
3" = 1'-0"

MSS Engineering, LLC
ENGINEERING, CONSULTING & DESIGN
414 W 5th St., Auburn, IN 46706
Phone: (260) 267-7414
Email: tamcdaniel@mssengineer.com
Travis A. McDaniel, PE

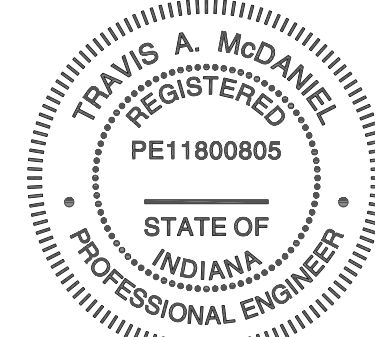

Travis A. McDaniel
05/26/23

PROJECT LOCATION:
560 S 900 E
MARION, IN 46953

PROJECT NAME:
BID SPEC &
DESIGN

DRAWING TITLE:
STAIR DETAILS

REVISIONS:

NO.	DATE	DESCRIPTION	BY
-----	------	-------------	----

JOB NUMBER:
22.081.171

DRAWN
BY: CAS

ENGINEERED
BY: CAS


START DATE: 05/12/21

PROGRESS DATE: 7/13/21


CERTIFIED DATE: 05/26/23

SCALE: As indicated


PAGE NUMBER:

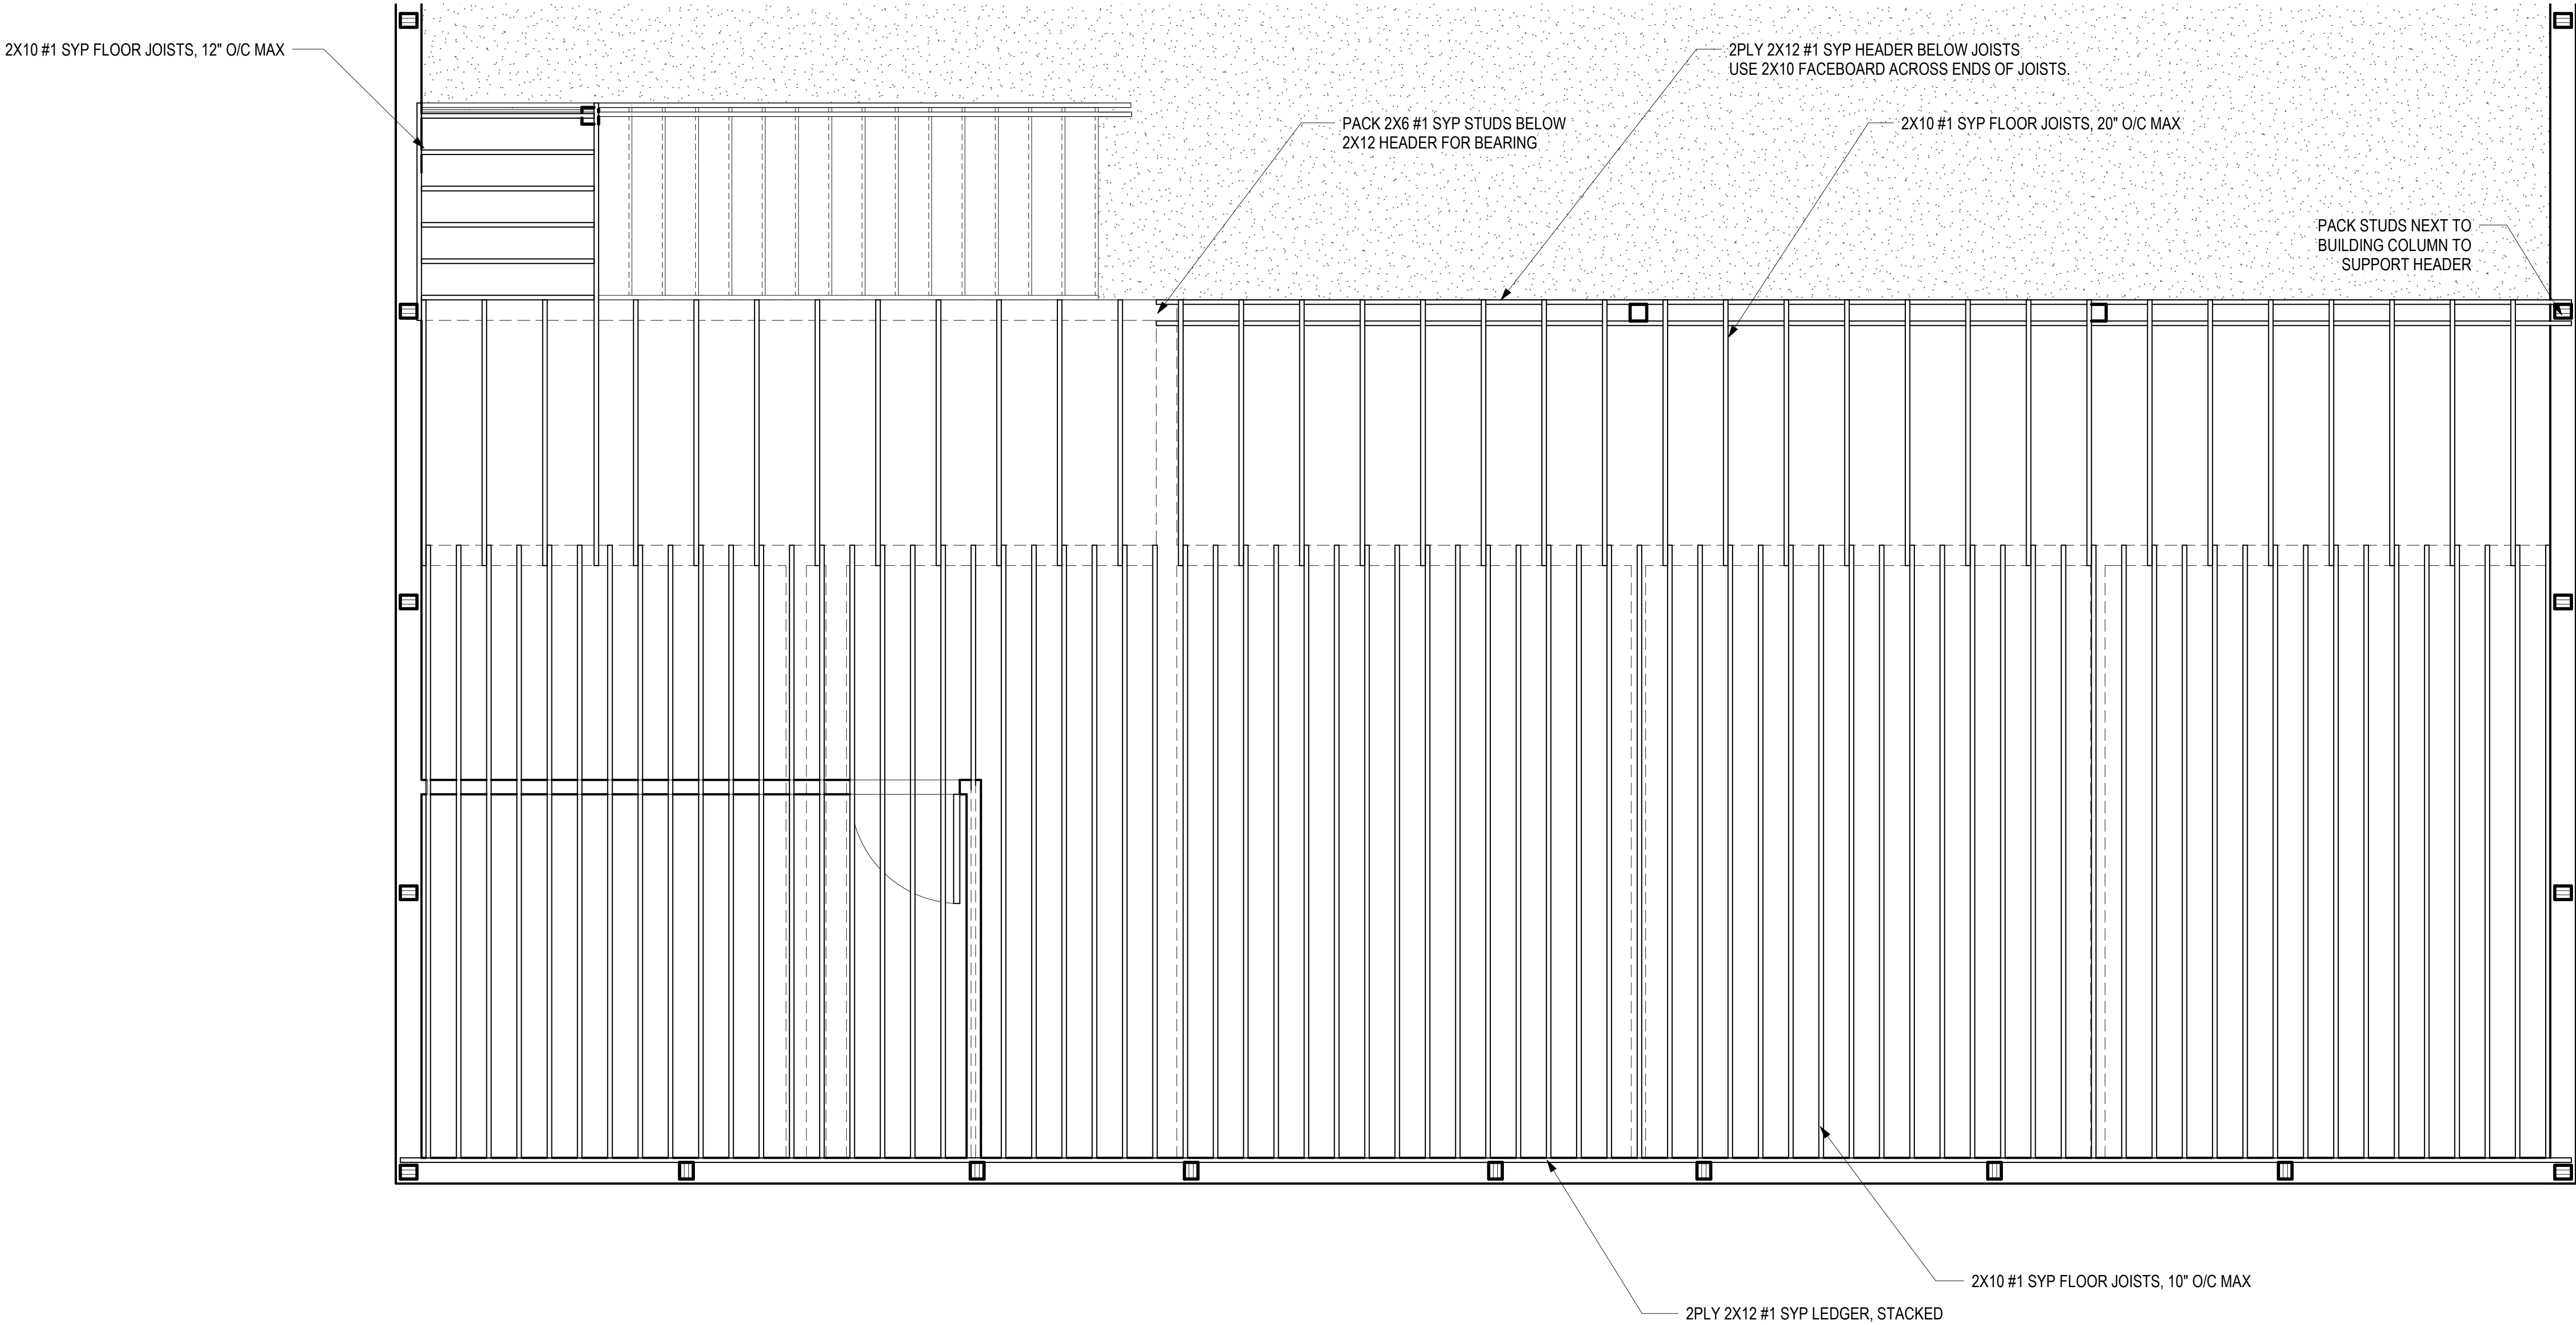

1 LOFT - FLOOR FRAMING PLAN
3/8" = 1'-0"

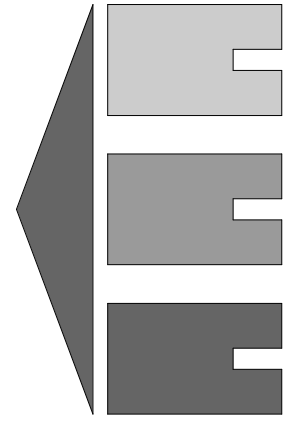

MSS Engineering, LLC
ENGINEERING, CONSULTING & DESIGN
414 W 5th St., Auburn, IN 46706
Phone: (260) 267-7414
Email: tamcdaniel@mssengineer.com
Travis A. McDaniel, PE

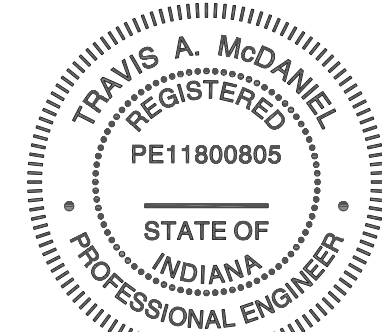

Travis A. McDaniel
05/26/23

PROJECT LOCATION:
560 S 900 E
MARION, IN 46953

PROJECT NAME:
BID SPEC &
DESIGN

DRAWING TITLE:
LOFT - FLOOR
FRAMING PLAN

REVISIONS:

NO.	DATE	DESCRIPTION	BY
-----	------	-------------	----

JOB NUMBER:
22.081.171

**DRAWN
BY:** TAM

**ENGINEERED
BY:** TAM

START DATE: 09/16/21



PROGRESS DATE: 7/13/21

CERTIFIED DATE: 05/26/23


SCALE: 3/8" = 1'-0"

PAGE NUMBER:


ROOF FRAMING LINE LEGEND	
	X-BRACING
	DIAGONAL BRACING
	CORNER BRACING
	LATERAL RESTRAINT
	OVERHANG
	RIDGE LINE

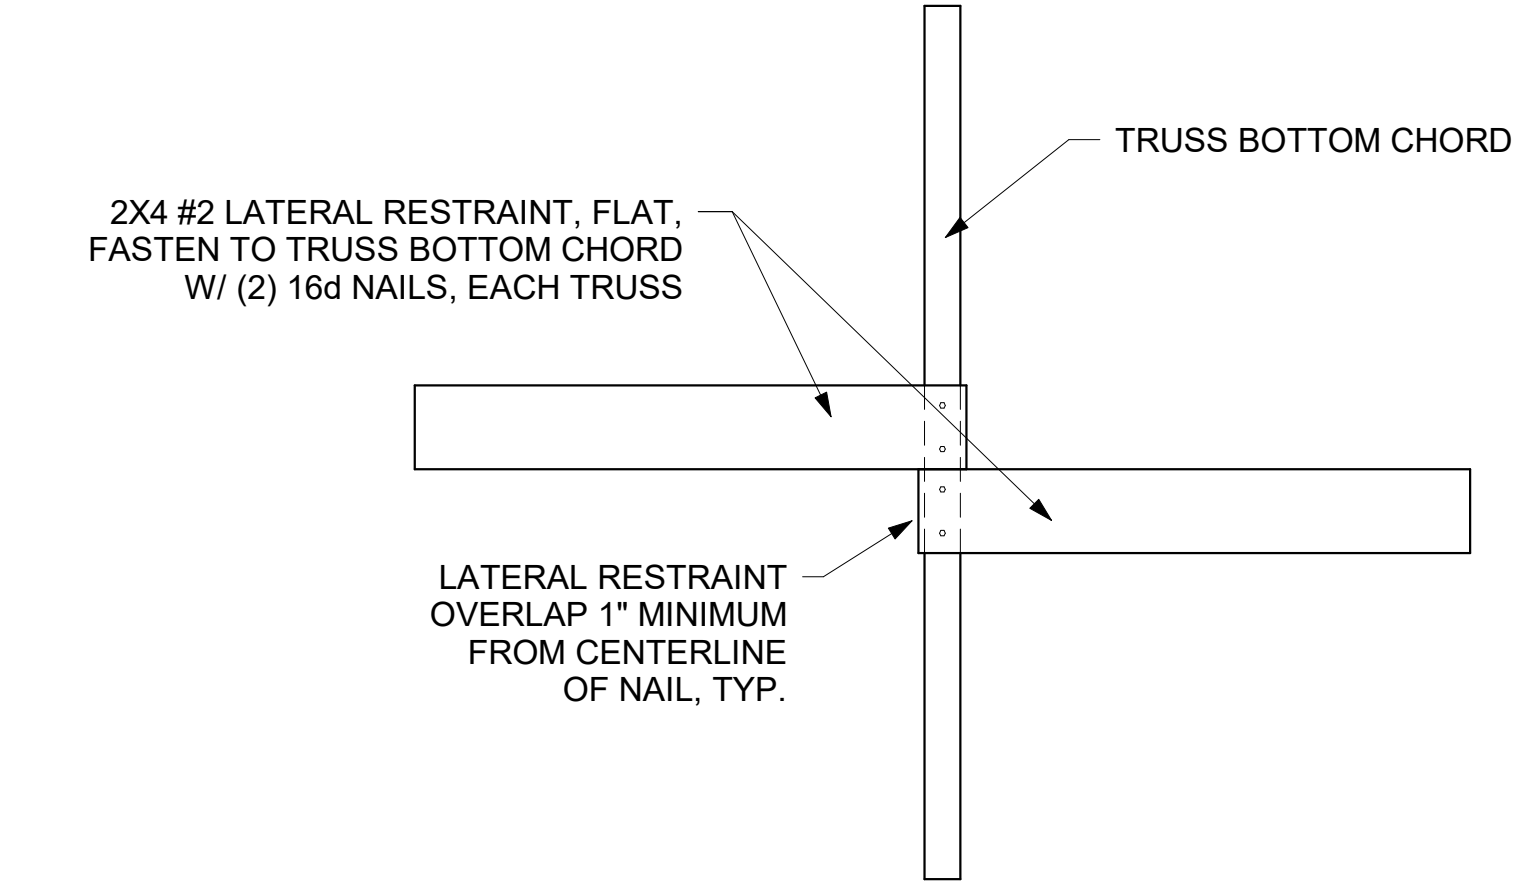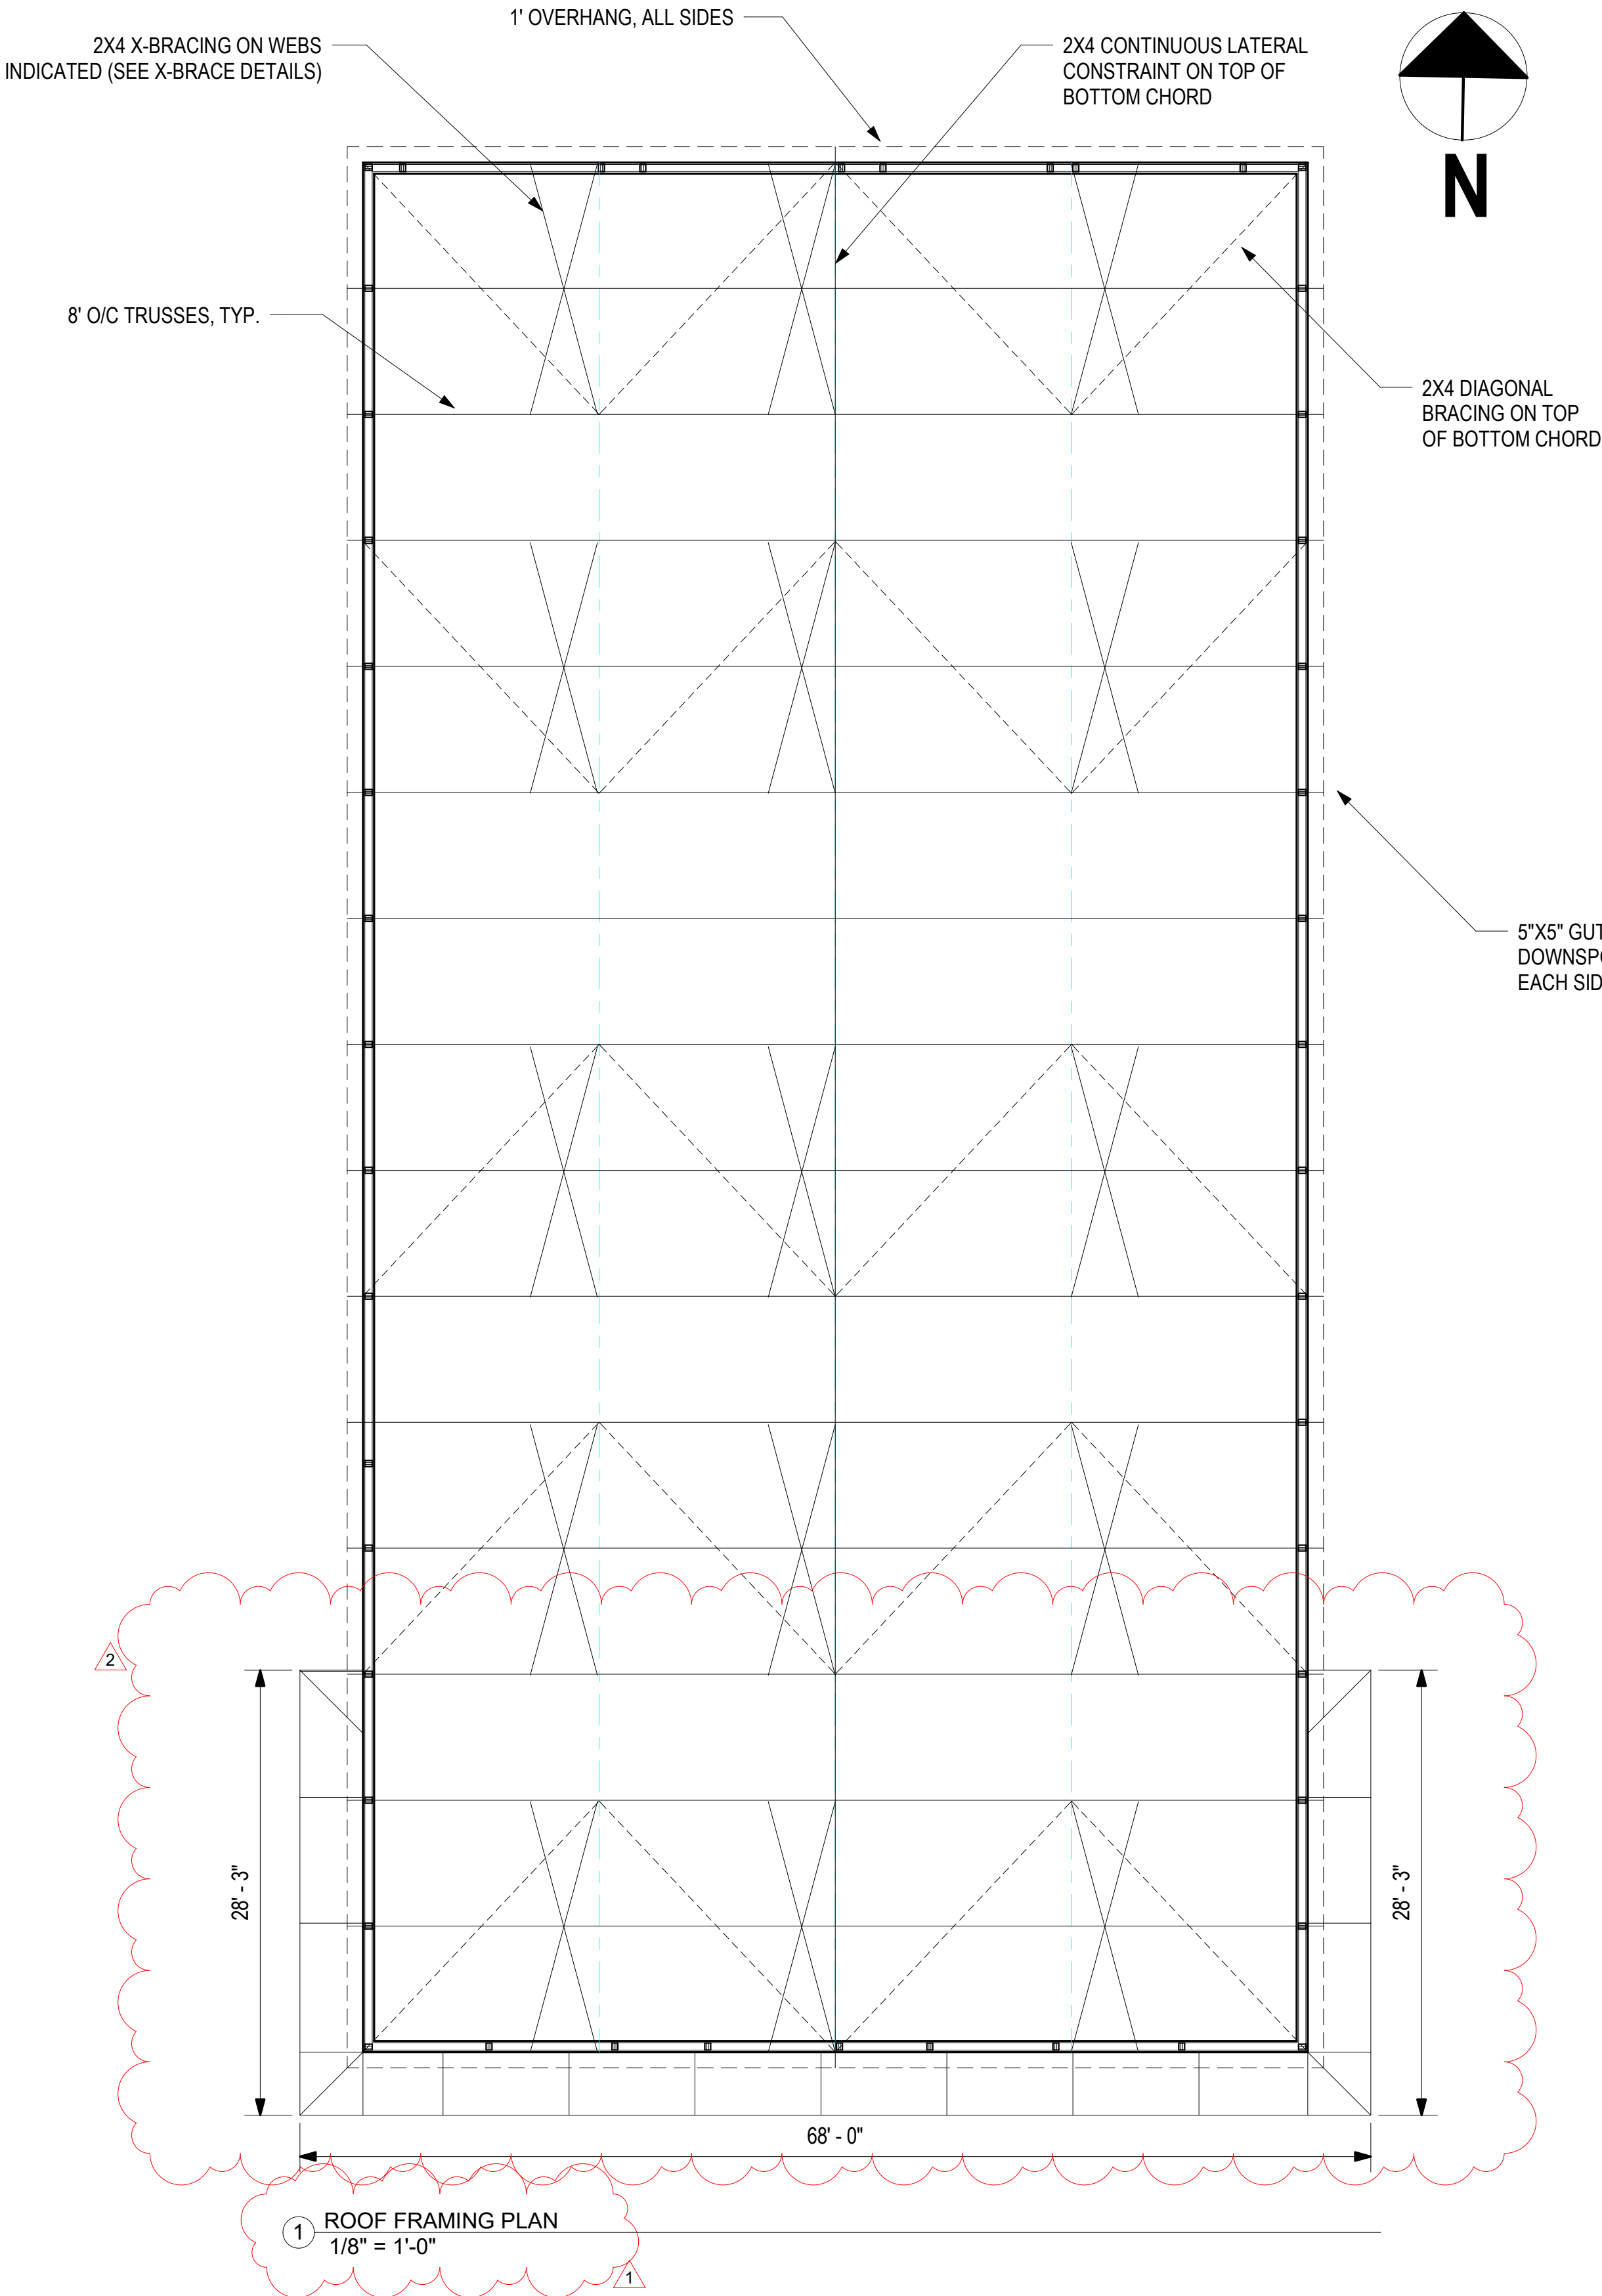

③ LATERAL RESTRAINT END LAP DETAIL
1 1/2" = 1'-0"

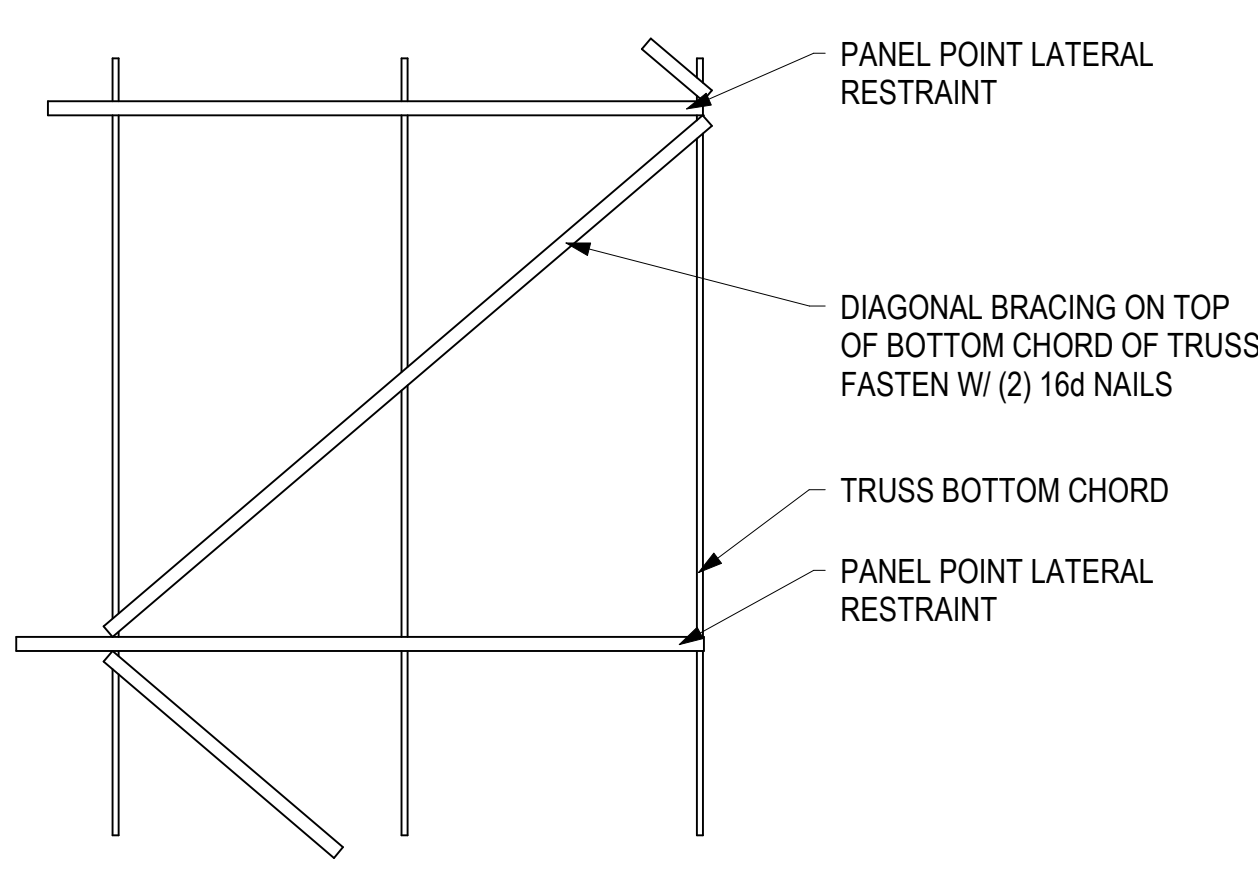


② DIAGONAL BRACING DETAIL
1/4" = 1'-0"

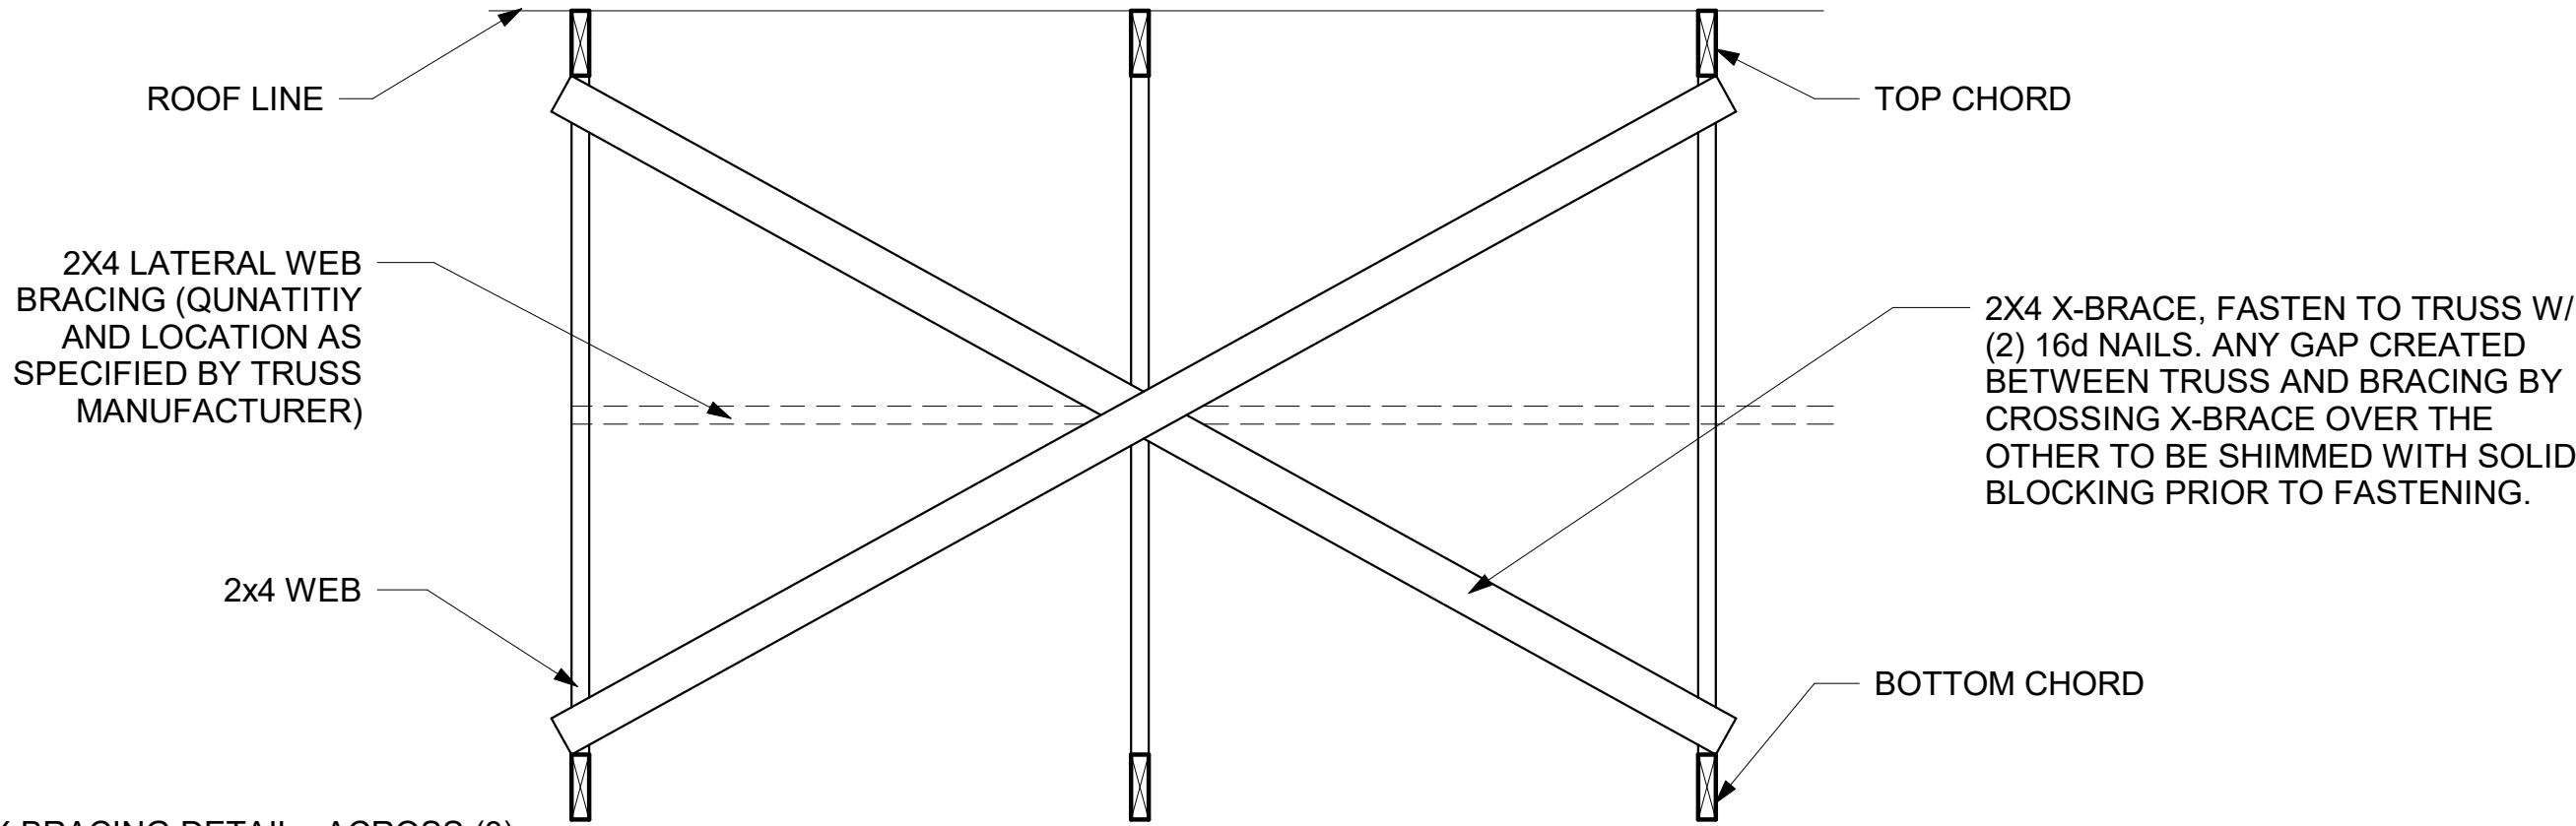

④ X-BRACING DETAIL - ACROSS (3) TRUSSES
3/4" = 1'-0"

MSS Engineering, LLC
ENGINEERING, CONSULTING & DESIGN
414 W 5th St., Auburn, IN 46706
Phone: (260) 267-7414
Email: tamcdaniel@mssengineer.com
Travis A. McDaniel, PE

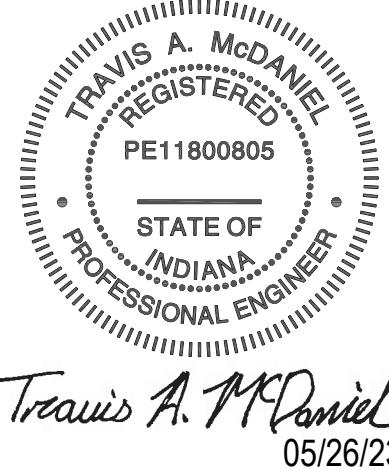

PROJECT LOCATION:
560 S 900 E
MARION, IN 46953

PROJECT NAME:
BID SPEC &
DESIGN

DRAWING TITLE:
ROOF FRAMING
PLAN

REVISIONS:

NO.	DATE	DESCRIPTION	BY
1	5/18/23	UPDATE/CORRECT NOTATION	TAM
2	5/26/23	ADD TO AWNING LENGTH	TAM

JOB NUMBER:
22.081.171

DRAWN BY: CAS

ENGINEERED BY: CAS






START DATE: 05/12/21

PROGRESS DATE: 7/13/21

CERTIFIED DATE: 05/26/23

SCALE: As indicated

PAGE NUMBER:

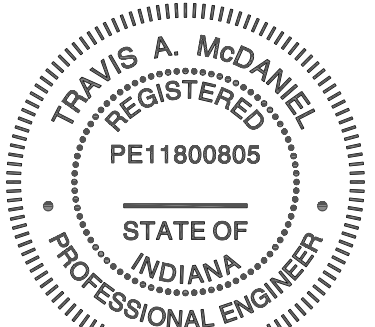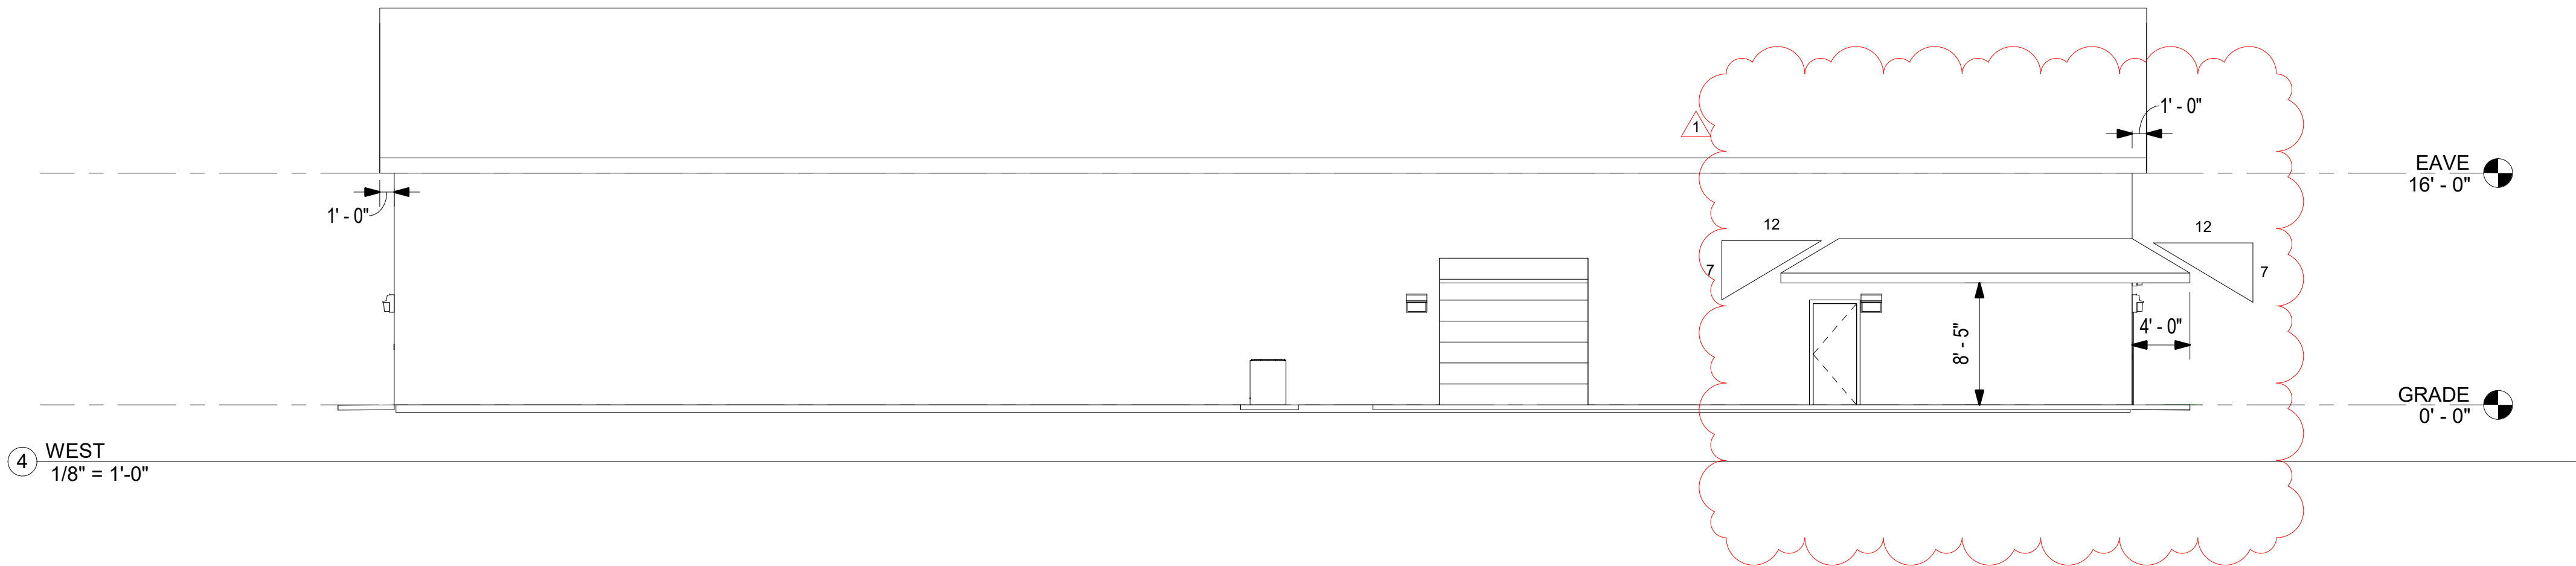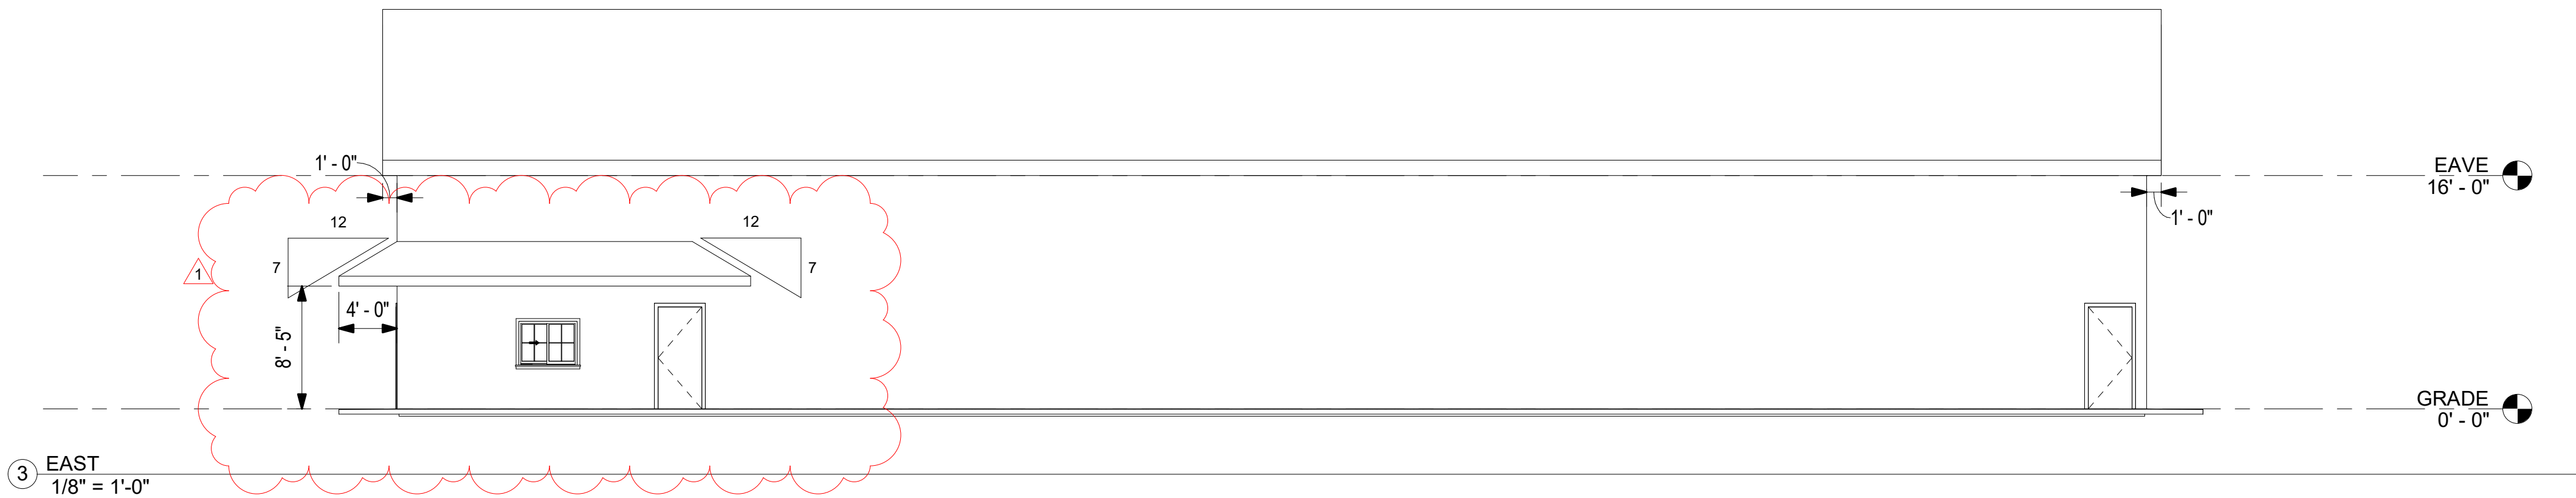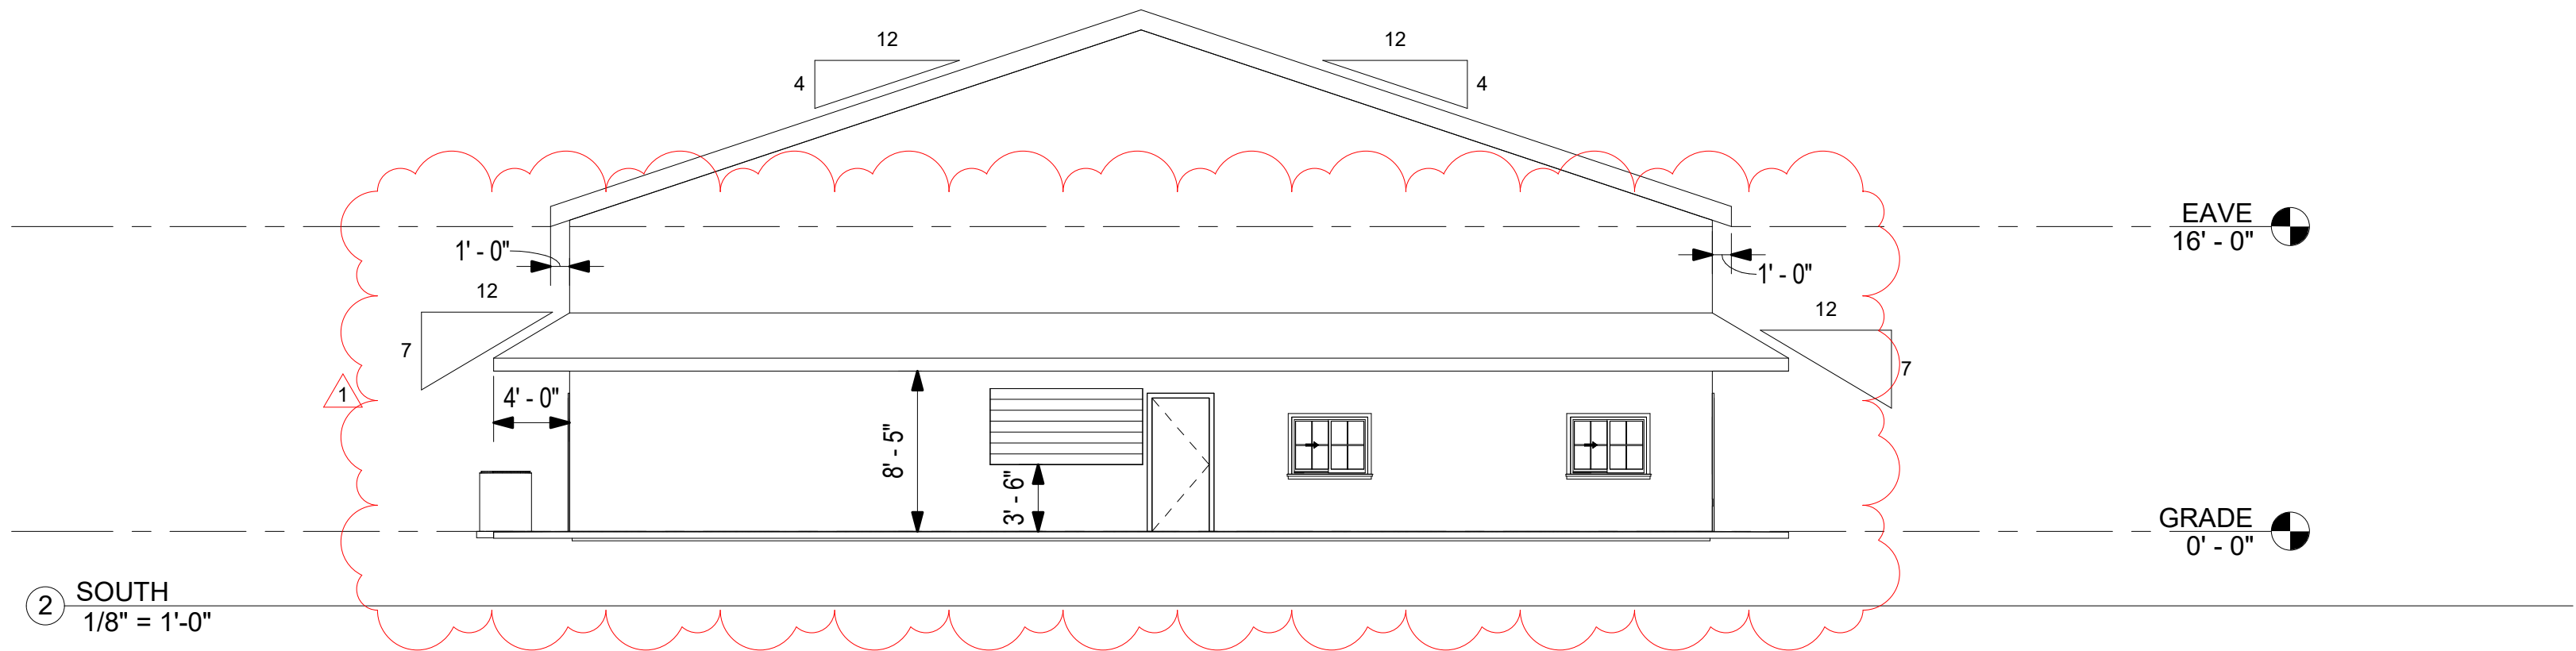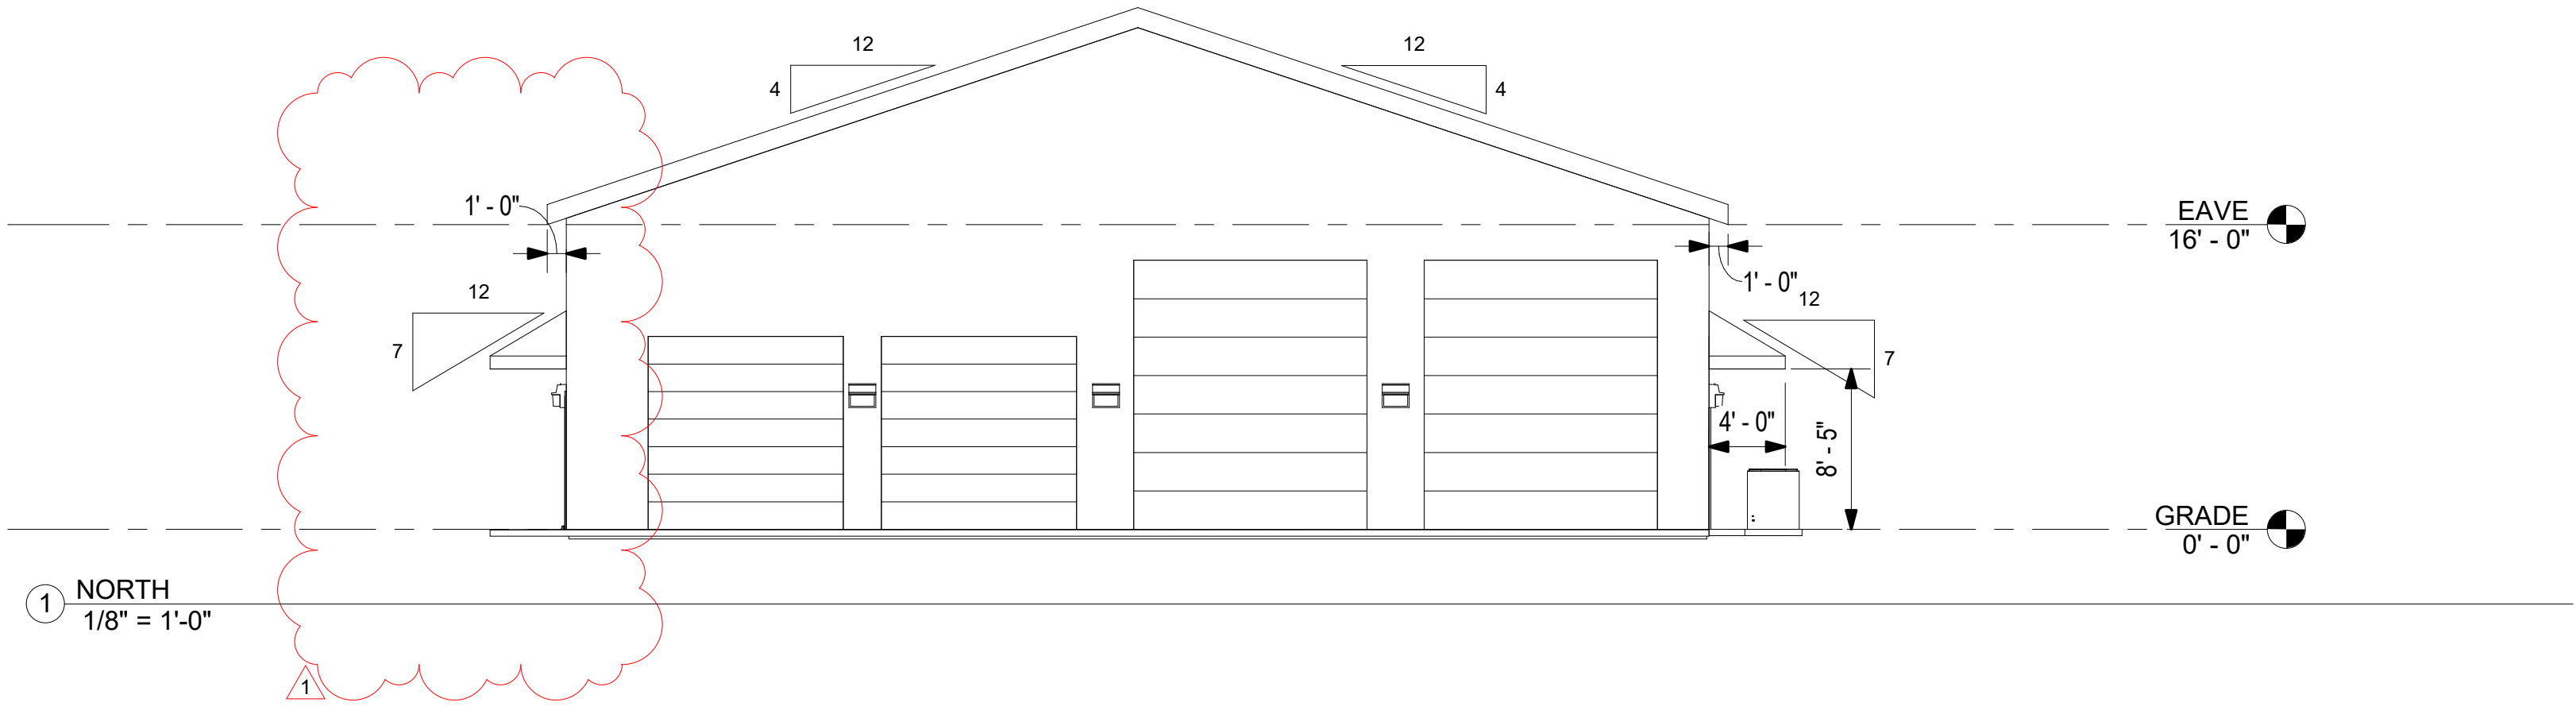

Travis A. McDaniel
05/26/23

PROJECT LOCATION:
560 S 900 E
MARION, IN 46953

PROJECT NAME:
BID SPEC &
DESIGN

DRAWING TITLE:
ELEVATIONS

REVISIONS:

NO.	DATE	DESCRIPTION	BY
1	5/26/23	ADD TO AWNING LENGTH	TAM

JOB NUMBER:
22.081.171

DRAWN BY: CAS

ENGINEERED BY: CAS


START DATE: 05/12/21

PROGRESS DATE: 7/13/21

CERTIFIED DATE: 05/26/23

SCALE: 1/8" = 1'-0"

PAGE NUMBER:

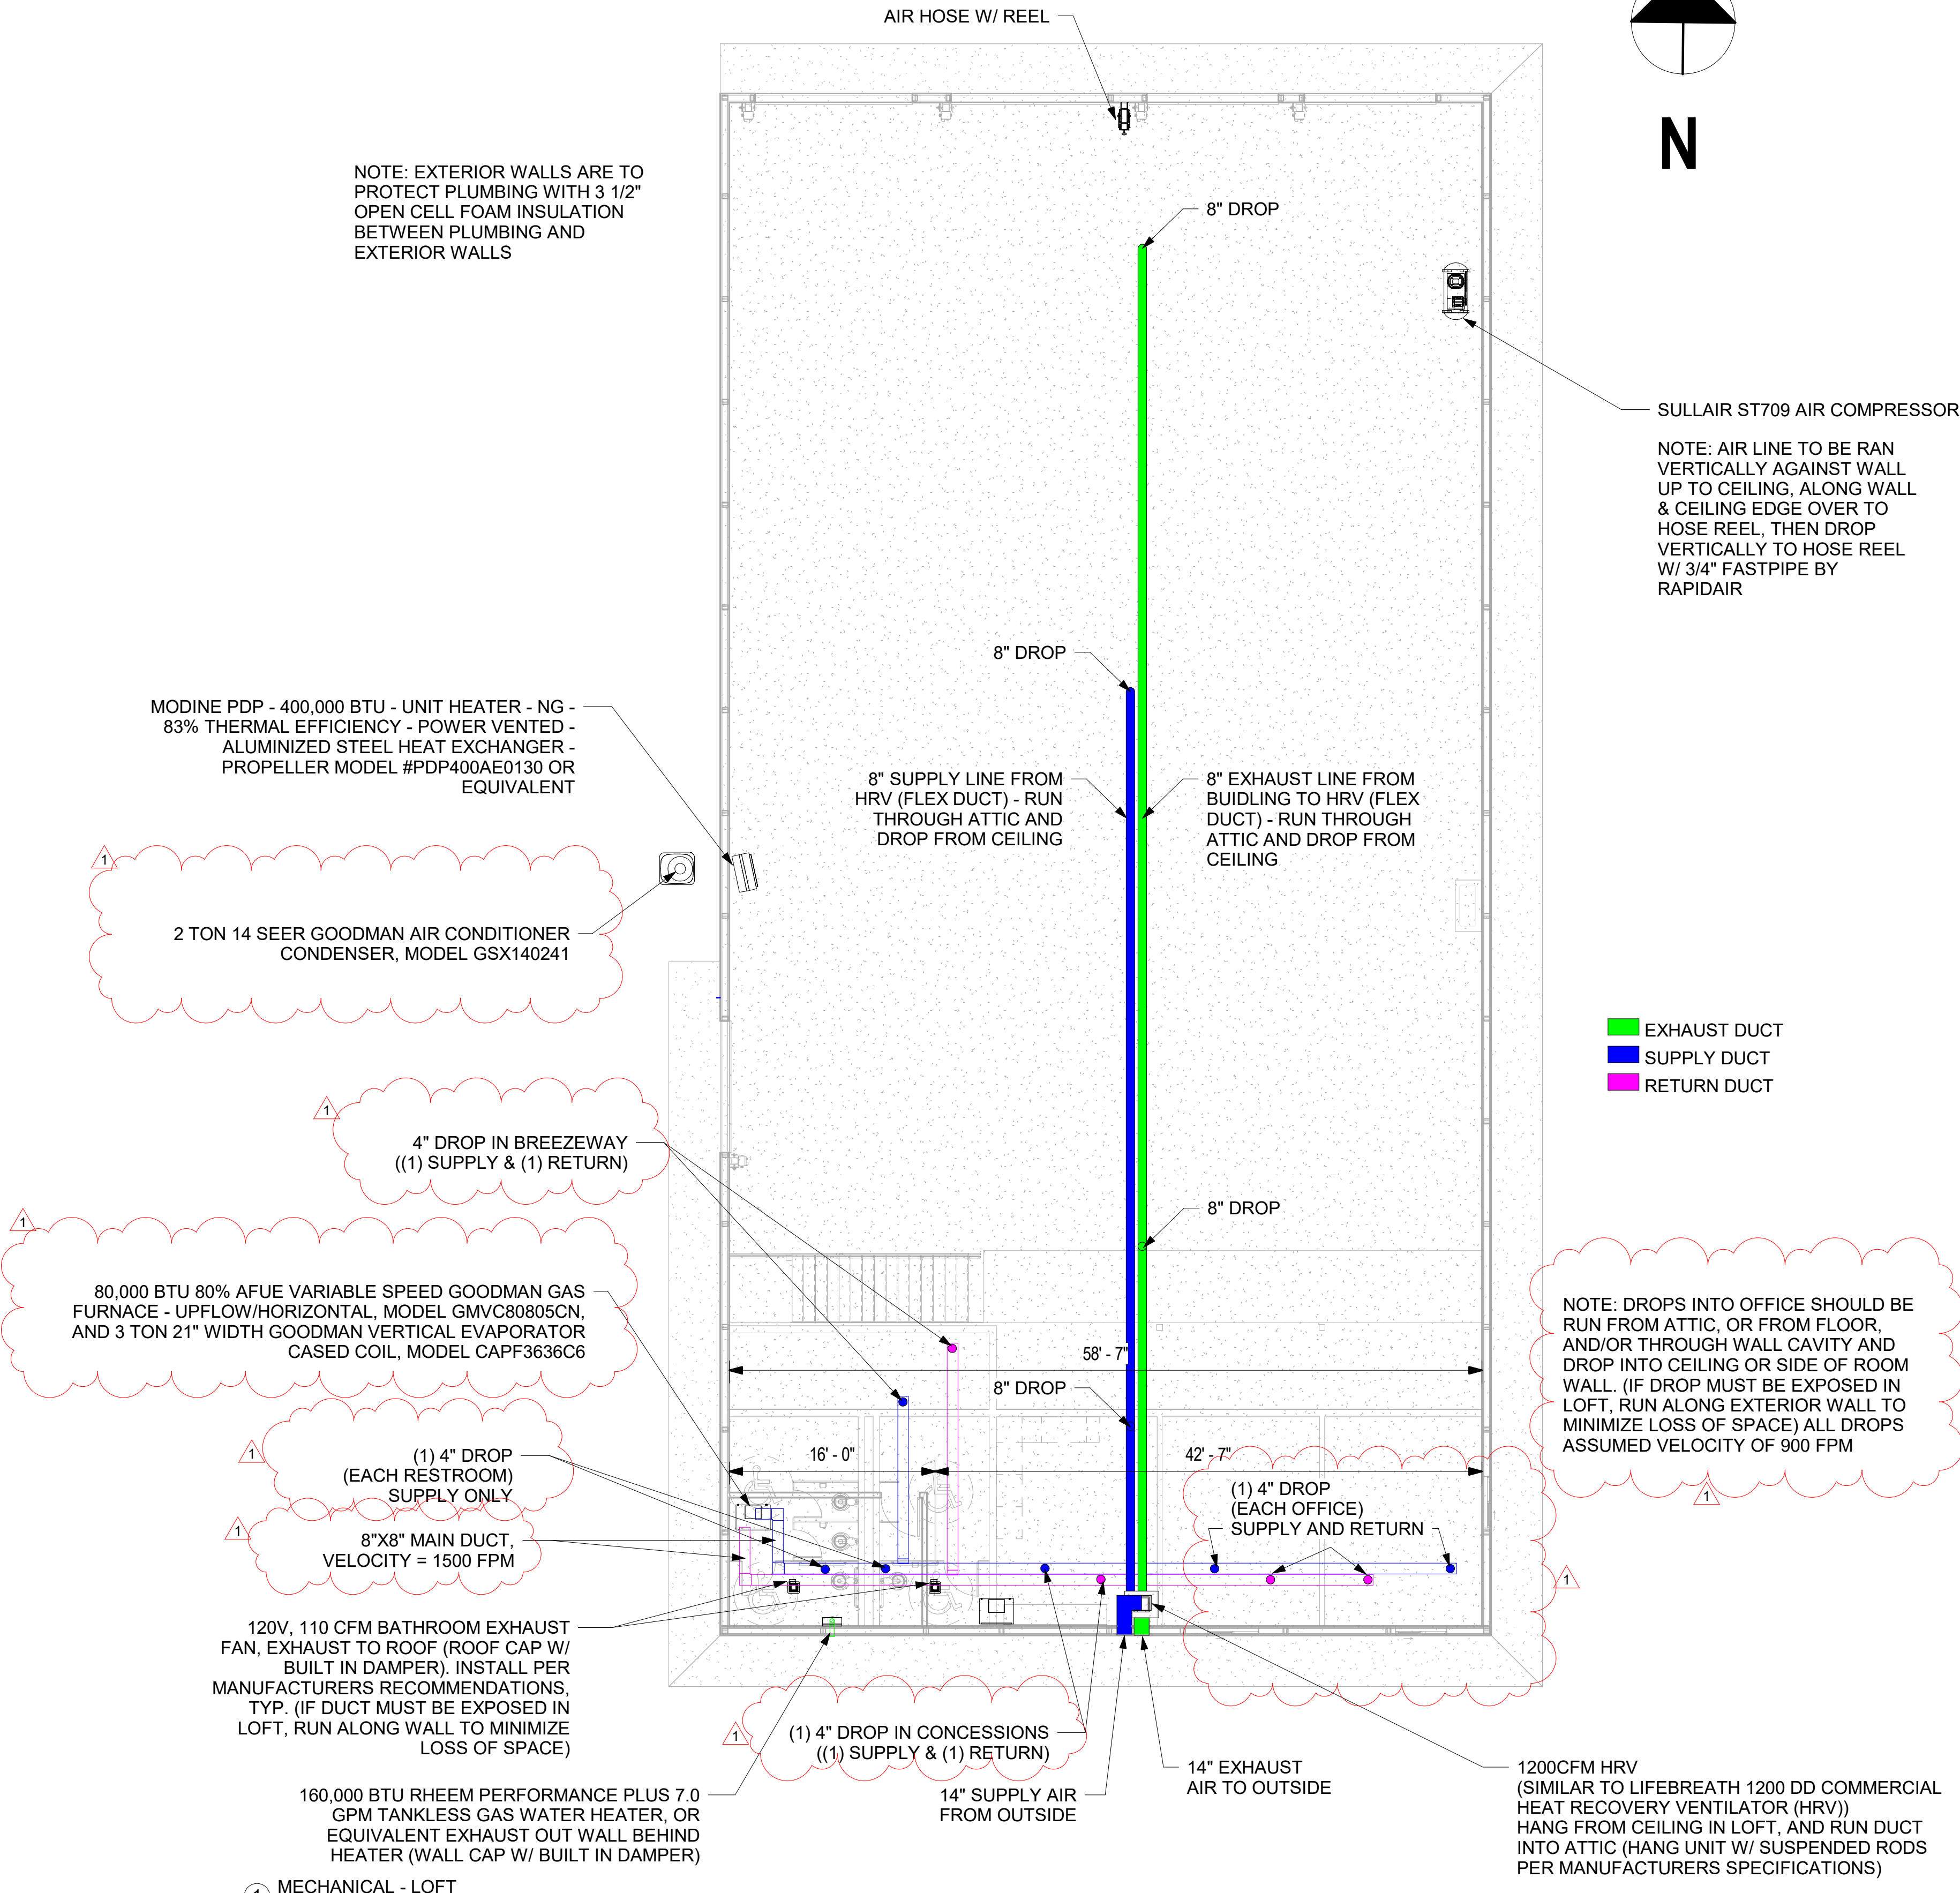

PROJECT LOCATION:
560 S 900 E
MARION, IN 46953

PROJECT NAME:
BID SPEC &
DESIGN

DRAWING TITLE:
MECHANICAL
PLAN

REVISIONS:

NO.	DATE	DESCRIPTION	BY
1	8/18/23	HVAC SYSTEM UPDATES	TAM

JOB NUMBER:
22.081.171

DRAWN
BY: CAS

**ENGINEERED
BY: TAM**

START DATE:	05/12/21
--------------------	----------


PROGRESS DATE:	07/13/21
----------------	----------

CERTIFIED DATE: 05/28/23

SCALE: 1/8" = 1'-0"

PAGE NUMBER:

NOTE: EACH OHD TO HAVE A 02-103L 3-BUTTON SURFACE MOUNT STATION, PROVIDE (2) 893MAX VISOR REMOTE CONTROLS

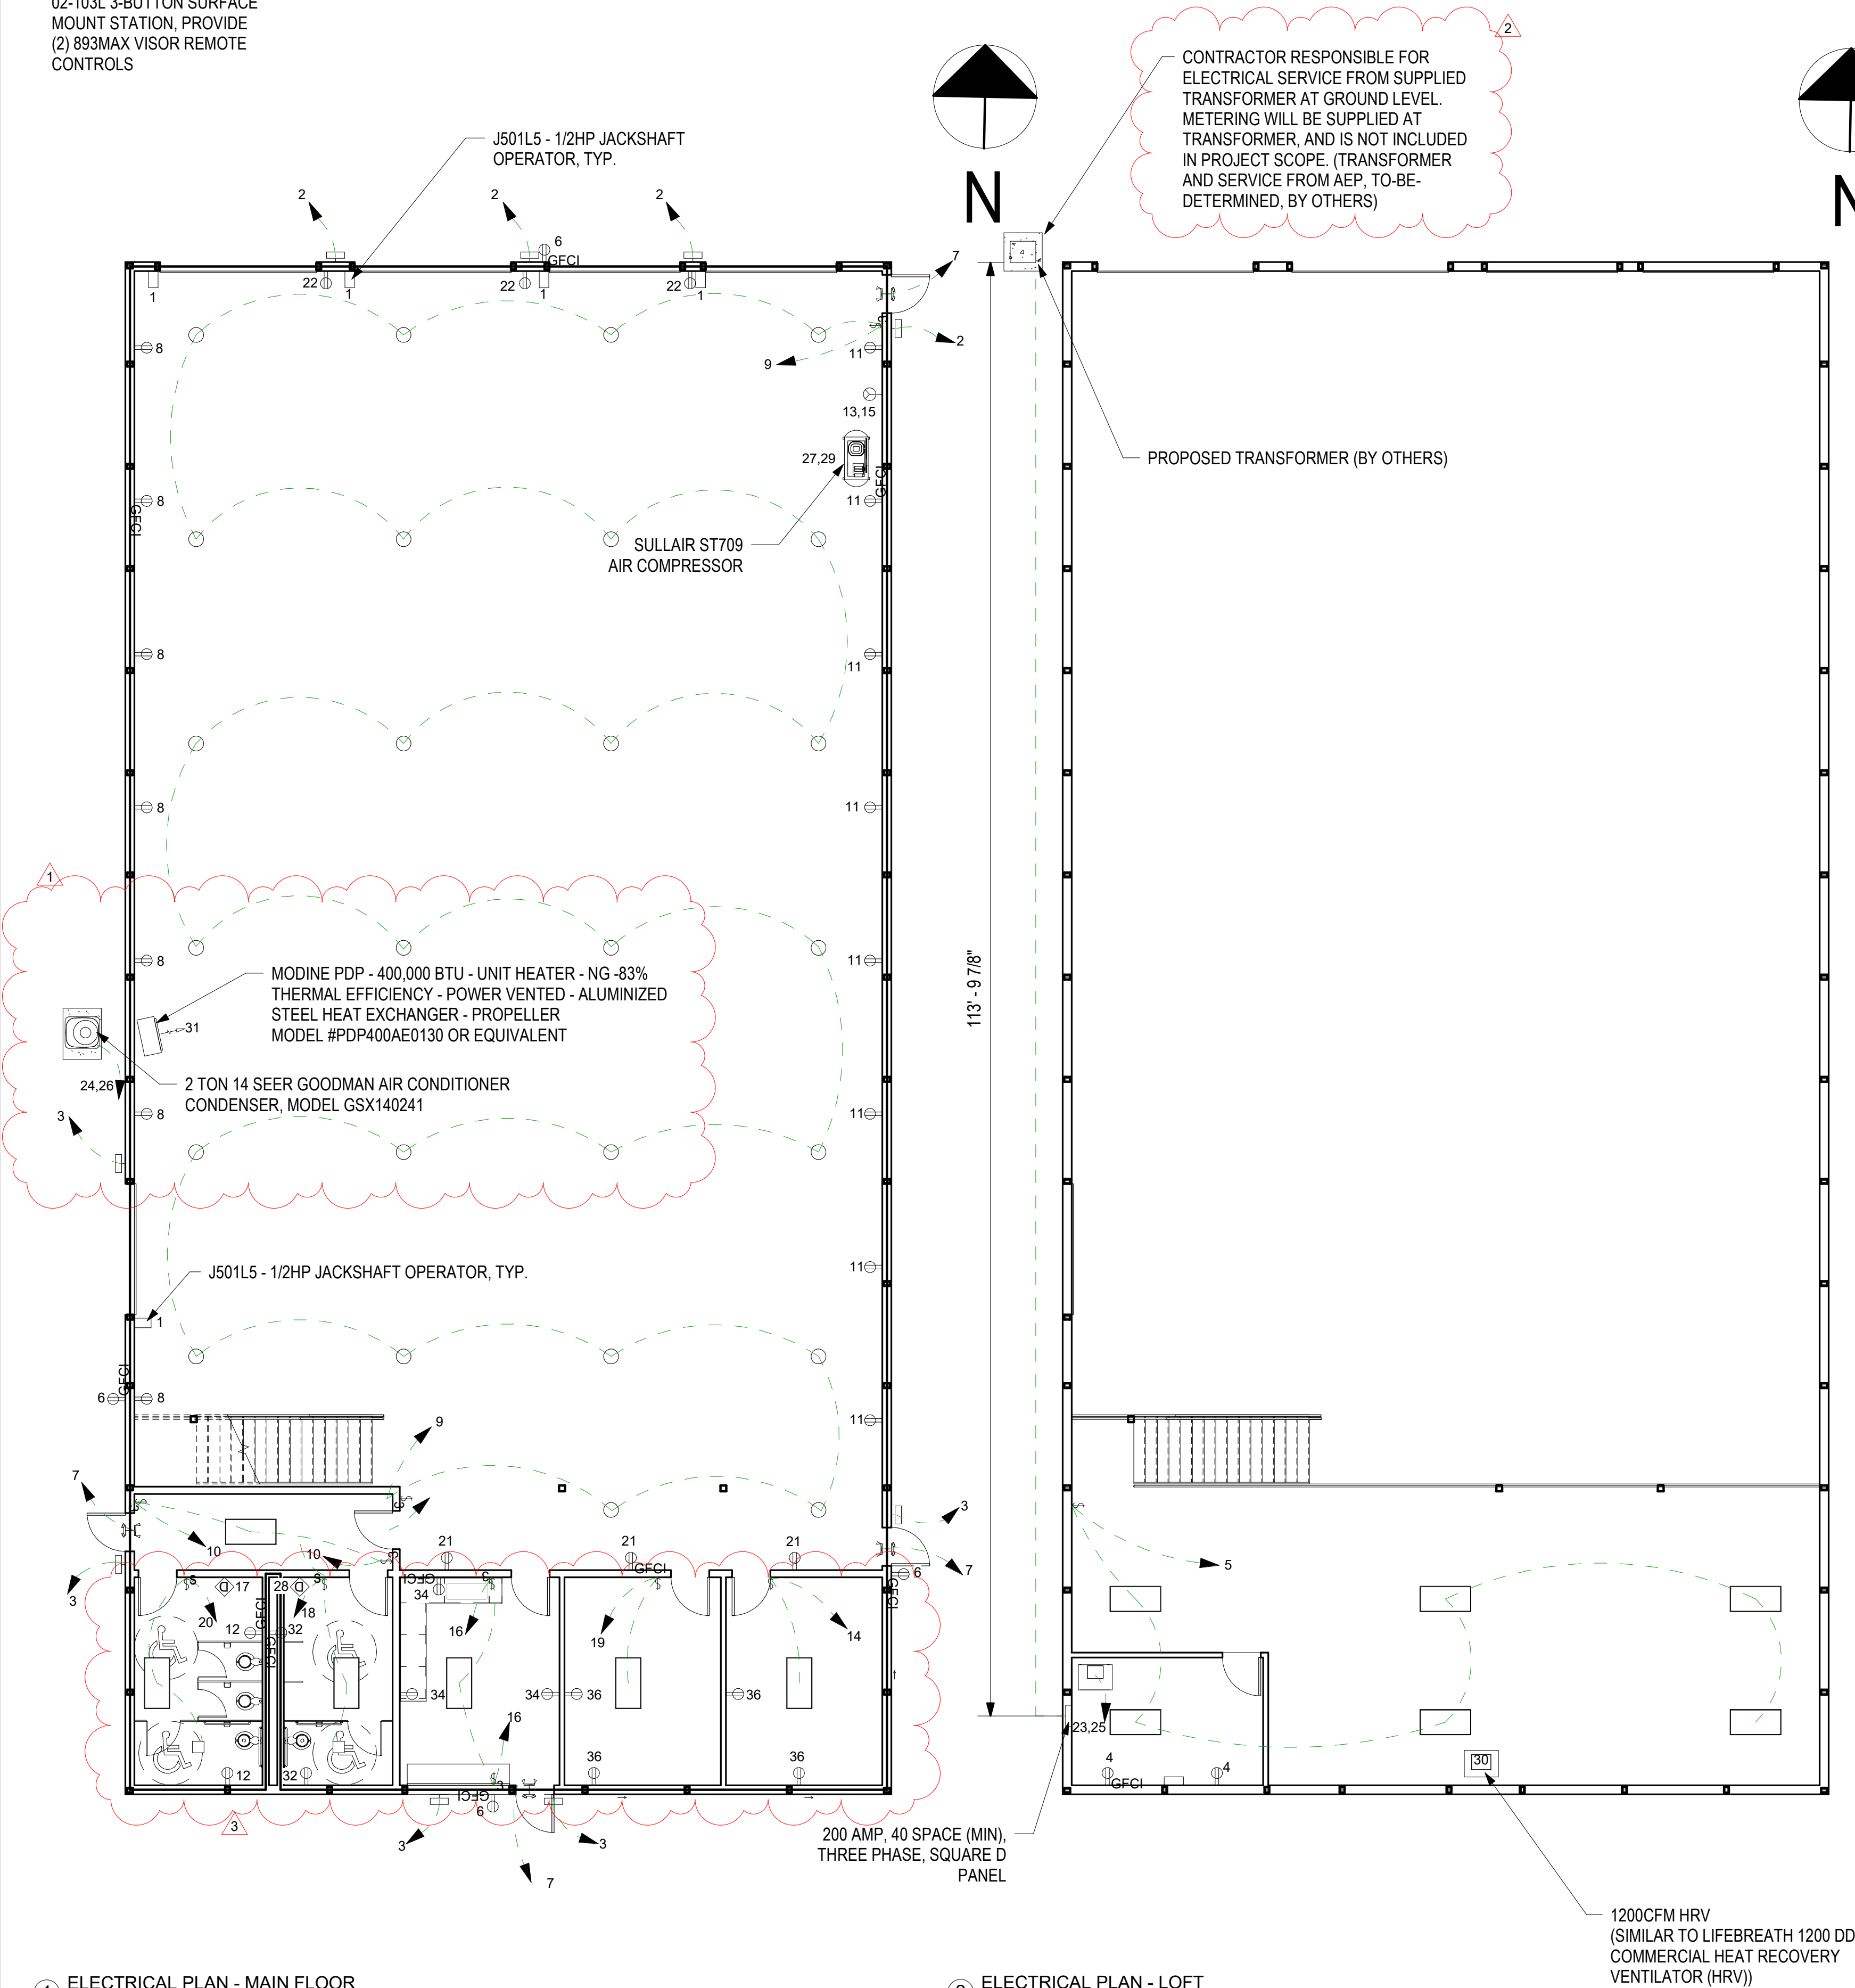

1 ELECTRICAL PLAN - MAIN FLOOR
1/8" = 1'-0"

2 ELECTRICAL PLAN - LOFT
1/8" = 1'-0"

CONTRACTOR RESPONSIBLE FOR ELECTRICAL SERVICE FROM SUPPLIED TRANSFORMER AT GROUND LEVEL. METERING WILL BE SUPPLIED AT TRANSFORMER, AND IS NOT INCLUDED IN PROJECT SCOPE. (TRANSFORMER AND SERVICE FROM AEP, TO-BE-DETERMINED, BY OTHERS)

PROPOSED TRANSFORMER (BY OTHERS)

Branch Panel: PL-1

Location: MECHANICAL ROOM 9
Supply From:
Mounting: Recessed
Enclosure:

Volts: 120/240 Single
Phases: 1 (120/208)
Wires: 3

A.I.C. Rating:
Mains Type:
Mains Rating: 200 A
MCB Rating: 200 A

Notes:

CKT	Circuit Description	Trip	Poles	A	B	Poles	Trip	Circuit Description	CKT
1	OHD OPERATORS	20 A	1	0 VA	280 VA	1	20 A	EXTERIOR LIGHTING - NORTH END	2
3	EXTERIOR LIGHTING - SOUTH END	20 A	1			1	20 A	DUPLEX RECEPTILES - LOFT	4
5	LOFT LIGHTING	20 A	1	510 VA	720 VA	1	20 A	EXT. GFCI PROTECTED RECEPTILES - NEMA 4	6
7	EMERGENCY EXIT SIGNS	20 A	1		500 VA	1	20 A	DUPLEX RECEPTILES - BUS GARAGE WEST	8
9	LIGHTING - BUS GARAGE	20 A	1	4186 VA	80 VA	1	20 A	LIGHTING - BREEZEWAY	10
11	DUPLEX RECEPTILES - BUS GARAGE EAST	20 A	1		1440 VA	1	20 A	GFCI PROT. RECEPTILES - MEN'S RESTROOM	12
13	220V RECEPTICLE - BUS GARAGE	20 A	2	180 VA	111 VA	1	20 A	LIGHTING - OFFICE 1	14
15	--	--	--		0 VA	1	20 A	LIGHTING - CONCESSIONS	16
17	DYSON AIRBLADE V, MODEL HU02 - WOMENS...	20 A	1	1080 VA	229 VA	1	20 A	LIGHTING - MENS RESTROOM	18
19	LIGHTING - OFFICE 2	20 A	1		111 VA	1	20 A	LIGHTING - WOMENS RESTROOM	20
21	DUPLEX RECEPTILES - BUS GARAGE SOUTH	20 A	1	540 VA	540 VA	1	20 A	DUPLEX RECEPTILES - BUS GARAGE NORTH	22
23	GOODMAN 5 TON CABINET HAVAC SYSTEM	30 A	2		5408 VA	2	30 A	GOODMAN HEAT PUMP	24
25	--	--	--	5408 VA	2530 VA		--	--	26
27	SULLAIR ST709 AIR COMPRESSOR	30 A	2		15 VA	1	20 A	DYSON AIRBLADE V, MODEL HU02, MENS...	28
29	--	--	--	15 VA	100 VA	1	20 A	1200CFM HEAT RECOVERY VENTILATOR (HRV)	30
31	Modine PDP - 400,000 BTU - UNIT HEATER	20 A	1		828 VA	1	20 A	GFCI PROT. RECEPTILES - WOMEN'S...	32
33	Spare	20 A	1	0 VA	540 VA	1	20 A	GFCI PROT. RECEPTILES - CONCESSIONS	34
35	Spare	20 A	1		0 VA	1	20 A	DUPLEX RECEPTILES - OFFICES	36
37	Spare	20 A	1	0 VA	0 VA	1	20 A	Spare	38
39	Spare	20 A	1		0 VA	1	20 A	Spare	40
Total Load:		16517 VA		14918 VA					
Total Amps:		138 A		124 A					




Legend:

Load Classification	Connected Load	Demand Factor	Estimated Demand	Panel Totals
Appliance - Dwelling Unit	2160 VA	100.00%	2160 VA	
Cooling	15976 VA	100.00%	15976 VA	Total Conn. Load: 31425 VA
Heating	828 VA	100.00%	828 VA	Total Est. Demand: 31582 VA
Lighting - Dwelling Unit	960 VA	100.00%	960 VA	Total Conn.: 131 A
Lighting - Exterior	630 VA	125.00%	788 VA	Total Est. Demand: 132 A
Other	270 VA	100.00%	270 VA	
Receptacle	7020 VA	100.00%	7020 VA	
Lighting	4827 VA	100.00%	4827 VA	


Notes:
EXISTING CONNECTED LOAD ESTIMATES BASED ON CONSERVATIVE ASSUMPTIONS.

ELECTRICAL SYMBOL LEGEND	
OUTLETS	
	220 VOLT RECEPTACLE
	DUPLEX RECEPTACLE
	DUPLEX RECEPTACLE, GFCI
SWITCHES	
	SINGLE POLE SWITCH
	OCCUPANCY SENSOR SWITCH
	3-WAY SWITCH

   ELECTRICAL SYMBOL LEGEND
1/4" = 1'-0"

LIGHT FIXTURE SYMBOL LEGEND & SCHEDULE	
	4' - LED PANEL, CEILING OR SURFACE MOUNT LIGHT FIXTURE
	22" Ø - LED HIGH BAY
	18 WATT LED EXTERIOR WALL MOUNTED LIGHT FIXTURE (WALL PACK) WITH PHOTOCELL. EQUAL TO LUMARK XTOR2B-W-PC.
	SELF-POWERED EMERGENCY EXIT LIGHT W/ DUAL HEAD AND REMOTE. EXTERIOR DUAL HEAD (NEAR THE DOOR) EMERGENCY LIGHTING & CHARGER WITH EMERGENCY BATTERY BACKUP FOR A DURATION OF NOT LESS THAN 1-1/2 HOURS. EQUAL TO ECONOLITE E-XCL2RCW SERIES.
	110 CFM - BATHROOM EXHAUST FAN W/ LIGHT

LIGHT FIXTURE SYMBOL LEGEND & SCHEDULE
1/4" = 1'-0"

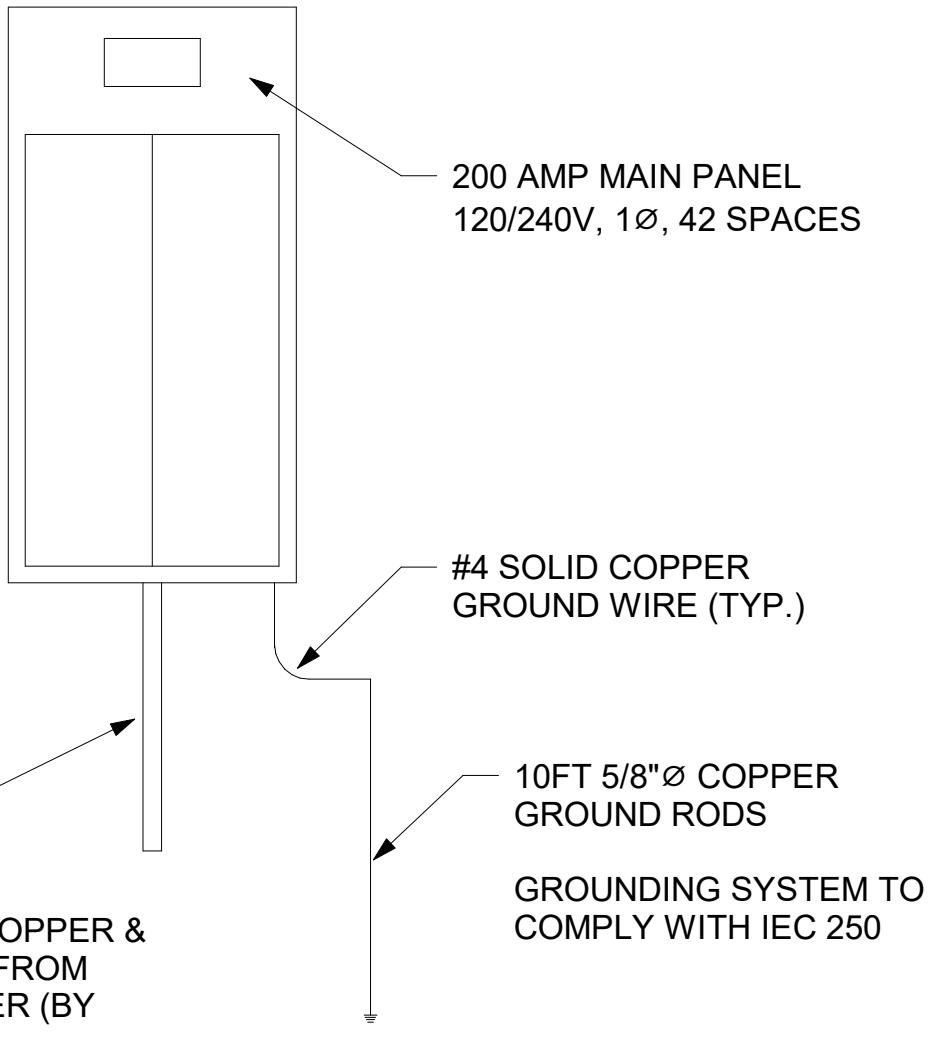

POWER RISER DIAGRAM
NOT TO SCALE

MAIN BREAKERS TO BE 50,000 AIC
RATED ALL BREAKERS TO BE 10,000 AIC RATED

WIRE AND CONDUIT SIZE SCHEDULE

AMPS	WIRE SIZE	CONDUIT SIZE
20A	#12	3/4"
25A	#10	3/4"
30A	#10	3/4"
35A	#8	1"
50A	#8	1"
60A	#6	1"
85A	#4	1 1/4"
100A	#3	1 1/2"
200A	#3/0 THHN	2"

INSULATION TYPE FOR 75° C THHN OR THWN DEPENDING ON LOCATION AND ALL EQUIPMENT AND TERMINATIONS. ANY OTHER DIFFERENCES IN INSTALLATIONS SHALL BE GIVEN TO PLAN REVIEW AND PROVIDE CATALOG CUT SHEETS.

PROJECT LOCATION:

560 S 900 E
MARION, IN 46953

PROJECT NAME:

BID SPEC &
DESIGN

DRAWING TITLE:
ELECTRICAL PLAN

REVISIONS:

NO.	DATE	DESCRIPTION	BY
1	5/18/23	UPDATE/CORRECT NOTATION	TAM
2	5/26/23	ELECTRICAL PLAN UPDATES	TAM
3	5/26/23	UPDATE RECEPTICLE CIRCUIT FOR PANEL	TAM

JOB NUMBER:

22.081.171

DRAWN
BY: CAS

ENGINEERED
BY: TAM

START DATE: 05/12/21

PROGRESS DATE: 7/13/21


CERTIFIED DATE: 05/26/23

SCALE: As indicated

PAGE NUMBER:



E01 OF E01 SHEETS

MSS Engineering, LLC
ENGINEERING, CONSULTING & DESIGN
414 W 5th St., Auburn, IN 46706
Phone: (260) 267-7414
Email: tamcdaniel@mssengineer.com
Travis A. McDaniel, PE

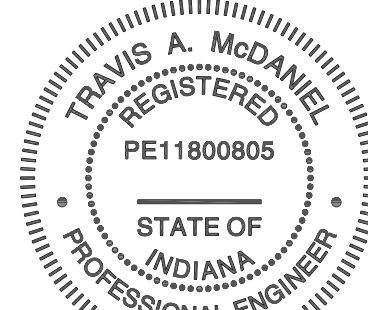

Travis A. McDaniel
05/26/23

NOTE: WATER SUPPLY LINES CAN BE INSTALLED IN EXTERIOR BETWEEN GIRTS AND IN FRONT OF COLUMNS, AND SHALL BE PROTECTED WITH ADDITIONAL 3 1/2" OPEN CELL FOAM CAVITY INSULATION BETWEEN PLUMBING AND EXTERIOR WALLS. ADDITIONALLY PROTECTED WATER SUPPLY LINES MAY BE INSTALLED IN THE SLAB OR IN CEILING, AS LONG AS LINES ARE PROTECTED FROM FREEZE. SEE PEX TUBING NOTES.


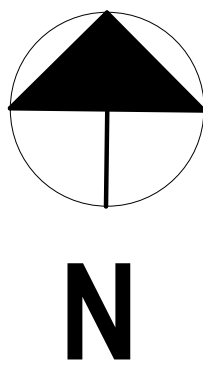
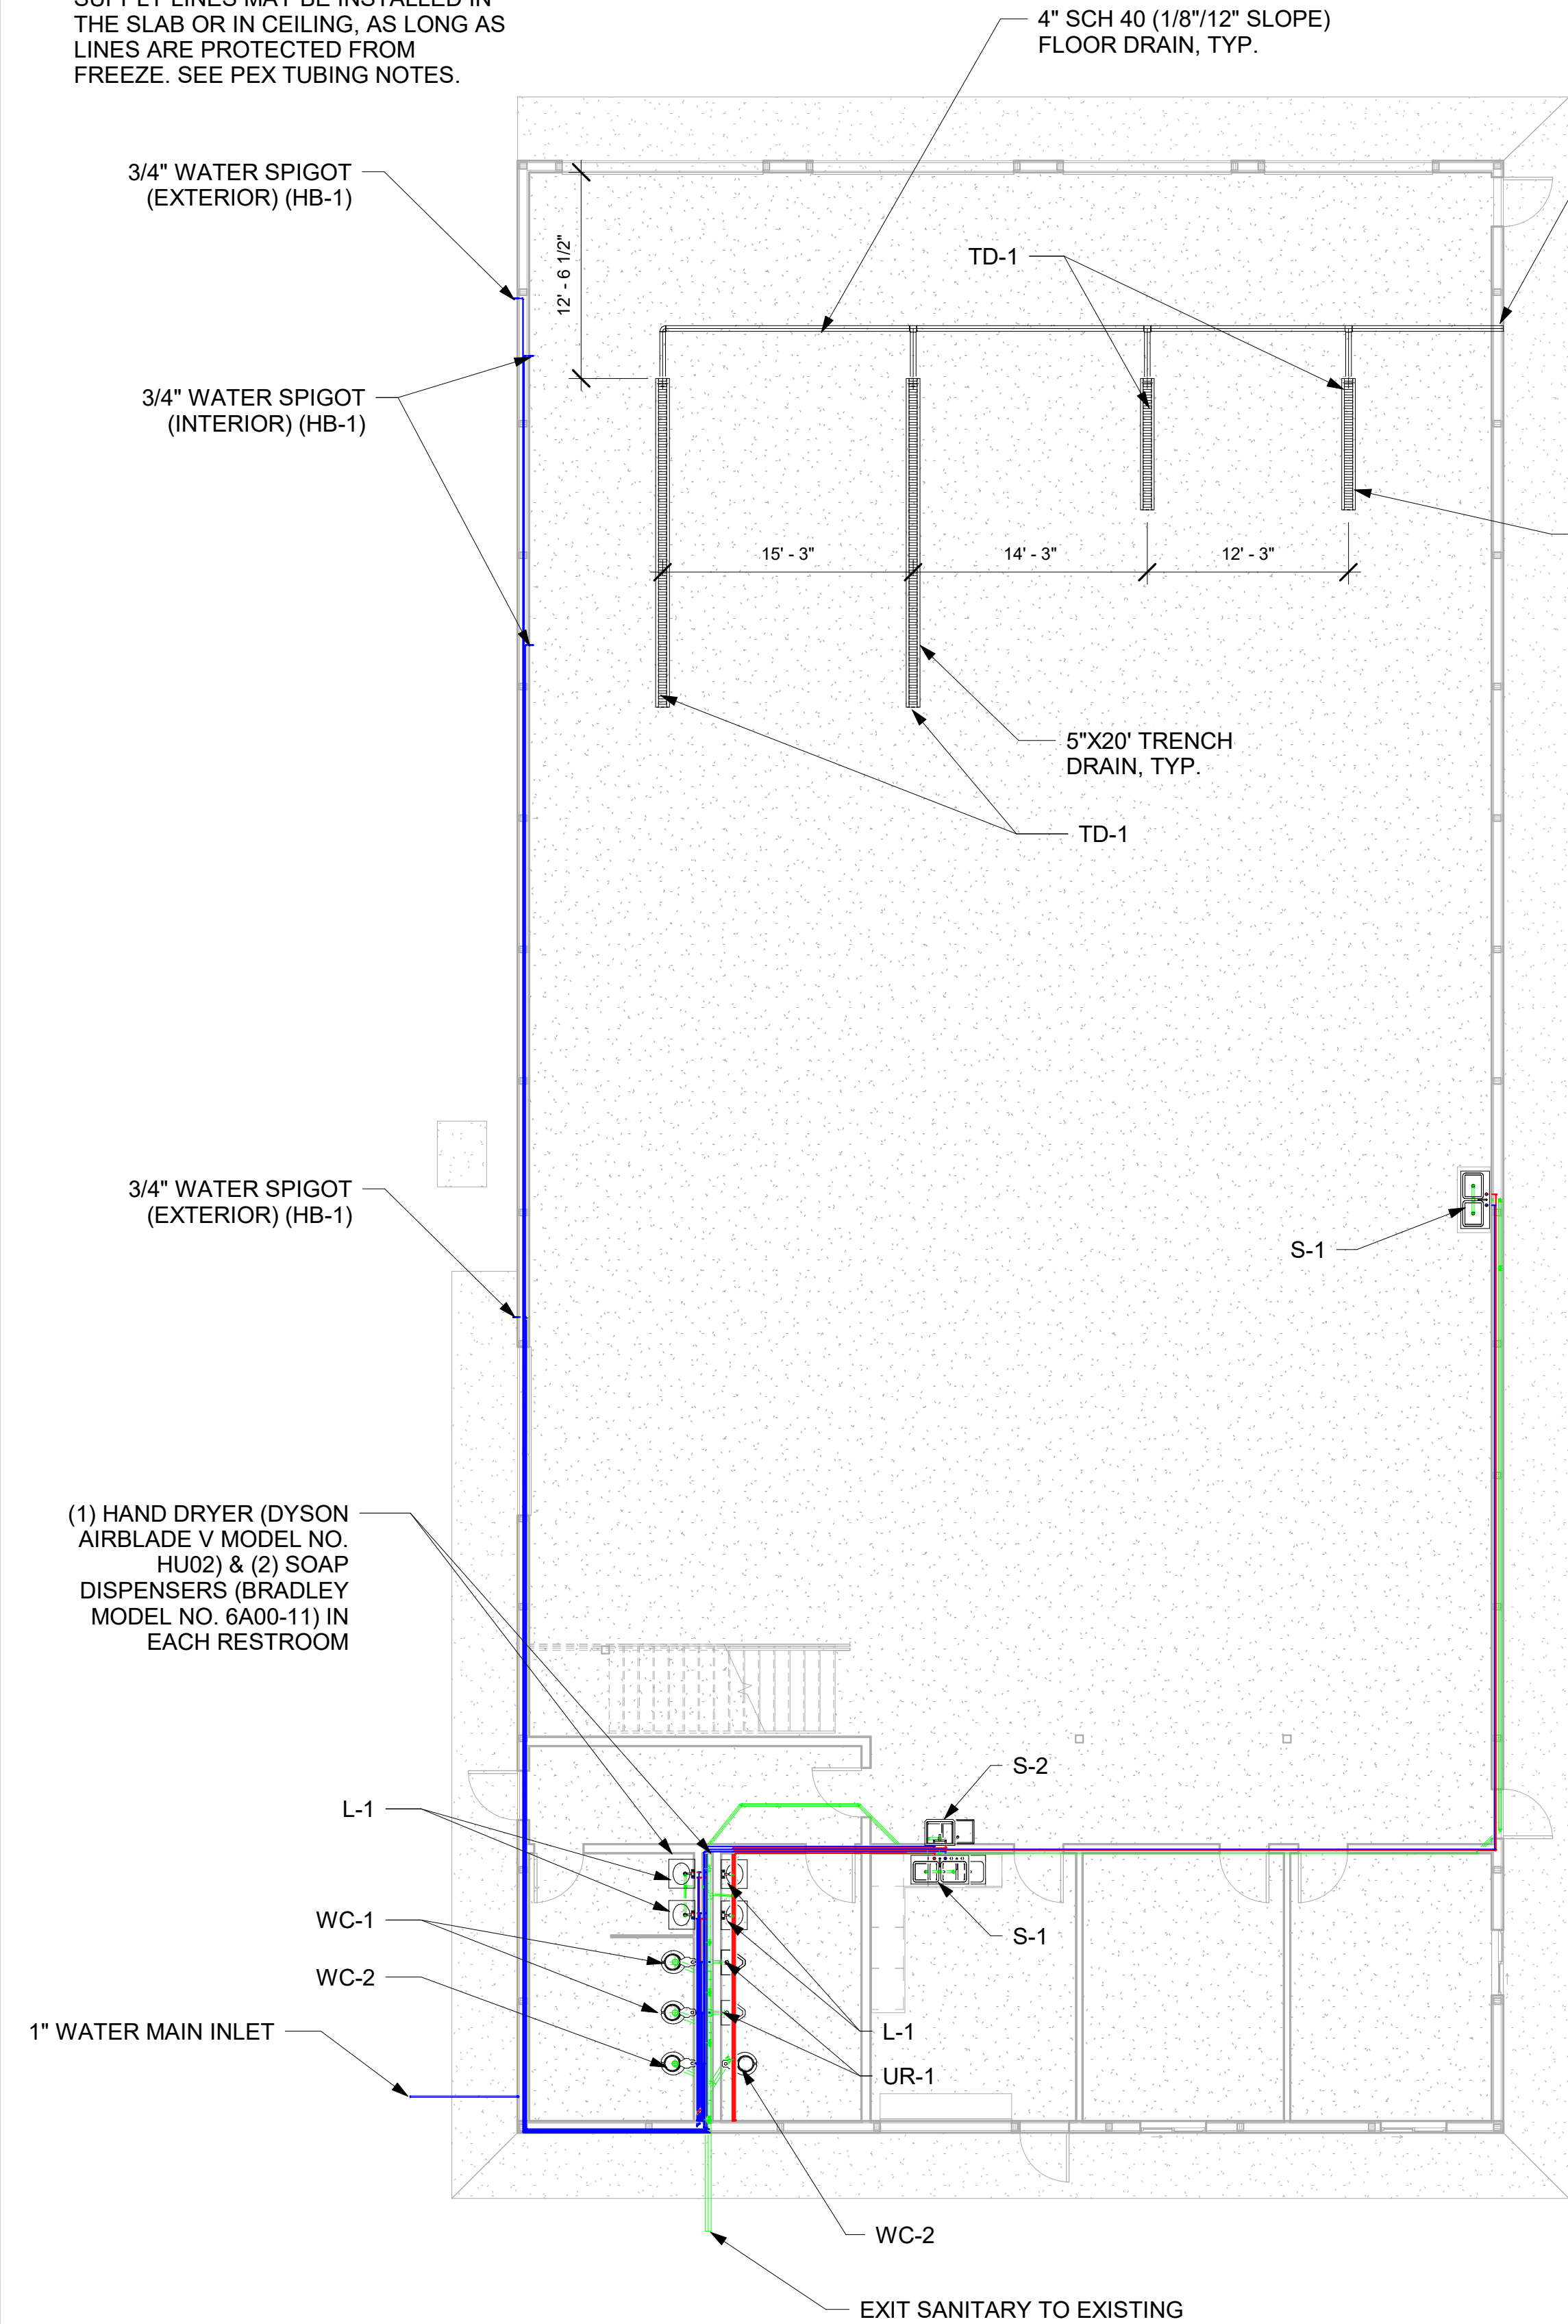


PEX TUBING NOTES:


- LAYING AND SUPPORTING TUBING UNDER SLAB
 - ONLY CONTINUOUSLY-RUN LENGTHS OF TUBING WITHOUT FITTINGS SHALL BE USED WHEN INSTALLING PEX UNDER A SLAB.
 - ALL CONNECTIONS SHALL BE OUTSIDE OR ABOVE THE SLAB.
 - TUBING SHALL BE COMPLETELY BURIED BY A SUITABLE, EASILY COMPACTED.
 - BACKFILL MATERIAL SUCH AS SAND OR PEA GRAVEL, PEX TUBING SHOULD BE INSTALLED UNDER THE REBAR, RE-MESH, OR TENSIONING CABLES IN THE SLAB.
 - PEX TUBING SHALL BE COVERED OR FASTENED TO PREVENT THE TUBING FROM FLOATING OR BEING PULLED UP TO THE SLAB SURFACE.
 - PEX TUBING DOES NOT HAVE TO BE SLEEVED ITS ENTIRE LENGTH WHERE IT LIES BENEATH A SLAB. PEX TUBING SHALL BE PROTECTED WITH A NON-METALLIC SLEEVE WHERE IT COMES THROUGH THE SLAB.
- PROTECTION OF TUBING AND FITTINGS FROM UV EXPOSURE
 - TO PREVENT DAMAGE FROM UV EXPOSURE, PEX TUBING AND FITTINGS THAT ARE EXPOSED ABOVE THE SLAB SHALL BE WRAPPED WITH AN OPAQUE COVERING SUCH AS BLACK POLYETHYLENE BAGS OR SHEETING IMMEDIATELY AFTER THE POURING OF THE SLAB.
 - COVERING SHOULD EXTEND DOWN TO THE SURFACE OF THE SLAB TO PROTECT ALL OF THE TUBE ABOVE THE SLAB FROM EXCESSIVE UV EXPOSURE.
 - FOR SPECIFIC LIMITATIONS ON UV EXPOSURE, CONSULT THE PEX TUBE MANUFACTURER.
- BACKFILLING
 - DO NOT USE CLAY, SILT, OR ROCKY BACKFILL.
 - REMOVE THE CONSTRUCTION MATERIALS, TRASH, OR FOREIGN OBJECTS FROM TRENCH PRIOR TO BACKFILLING.
 - THE TUBING SHOULD BE SURROUNDED WITH GOOD CLEAN FILL, OR SAND, OR RIVER RUN GRAVEL OF 1/2-INCH MAXIMUM PARTICLE SIZE.
 - COMPACT THE INITIAL BACKFILL AROUND THE TUBING TO PROVIDE ADEQUATE TUBING SUPPORT AND PREVENT SETTLEMENT. IT IS PARTICULARLY IMPORTANT TO ADEQUATELY COMPACT THE SOIL AROUND THE TAP CONNECTION.
 - IT IS RECOMMENDED THAT THE TUBING BE PRESSURIZED WITH WATER PRIOR TO BACKFILLING TO REVEAL ANY DAMAGE.

NOTE:
PROVIDE UTILITY METER AT EXTERIOR OF BUILDING FROM GAS UTILITY. METER SHALL PROVIDE 7" W.C. SERVICE INTO BUILDING. COORDINATE CONNECTION TO SITE GAS LINE WITH SITE DEVELOPMENT DRAWINGS. CONTRACTOR RESPONSIBLE FOR UTILITY COORDINATION AND ALL ASSOCIATED FEES TO PROVIDE A COMPLETELY INSTALLED AND FUNCTIONAL NATURAL GAS SERVICE.

NOTE:
WATER METER BY UTILITY CONTRACTOR RESPONSIBLE FOR UTILITY COORDINATION AND ALL ASSOCIATED FEES TO PROVIDE A COMPLETELY INSTALLED AND FUNCTIONAL WATER UTILITY SERVICE.

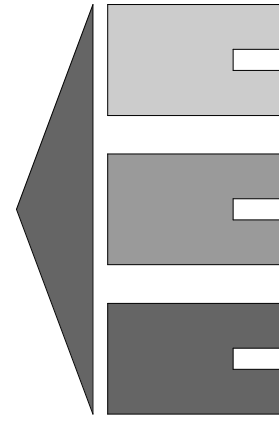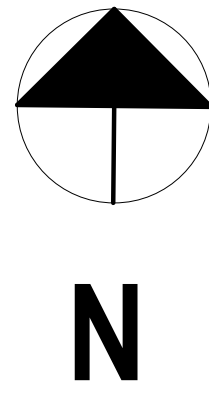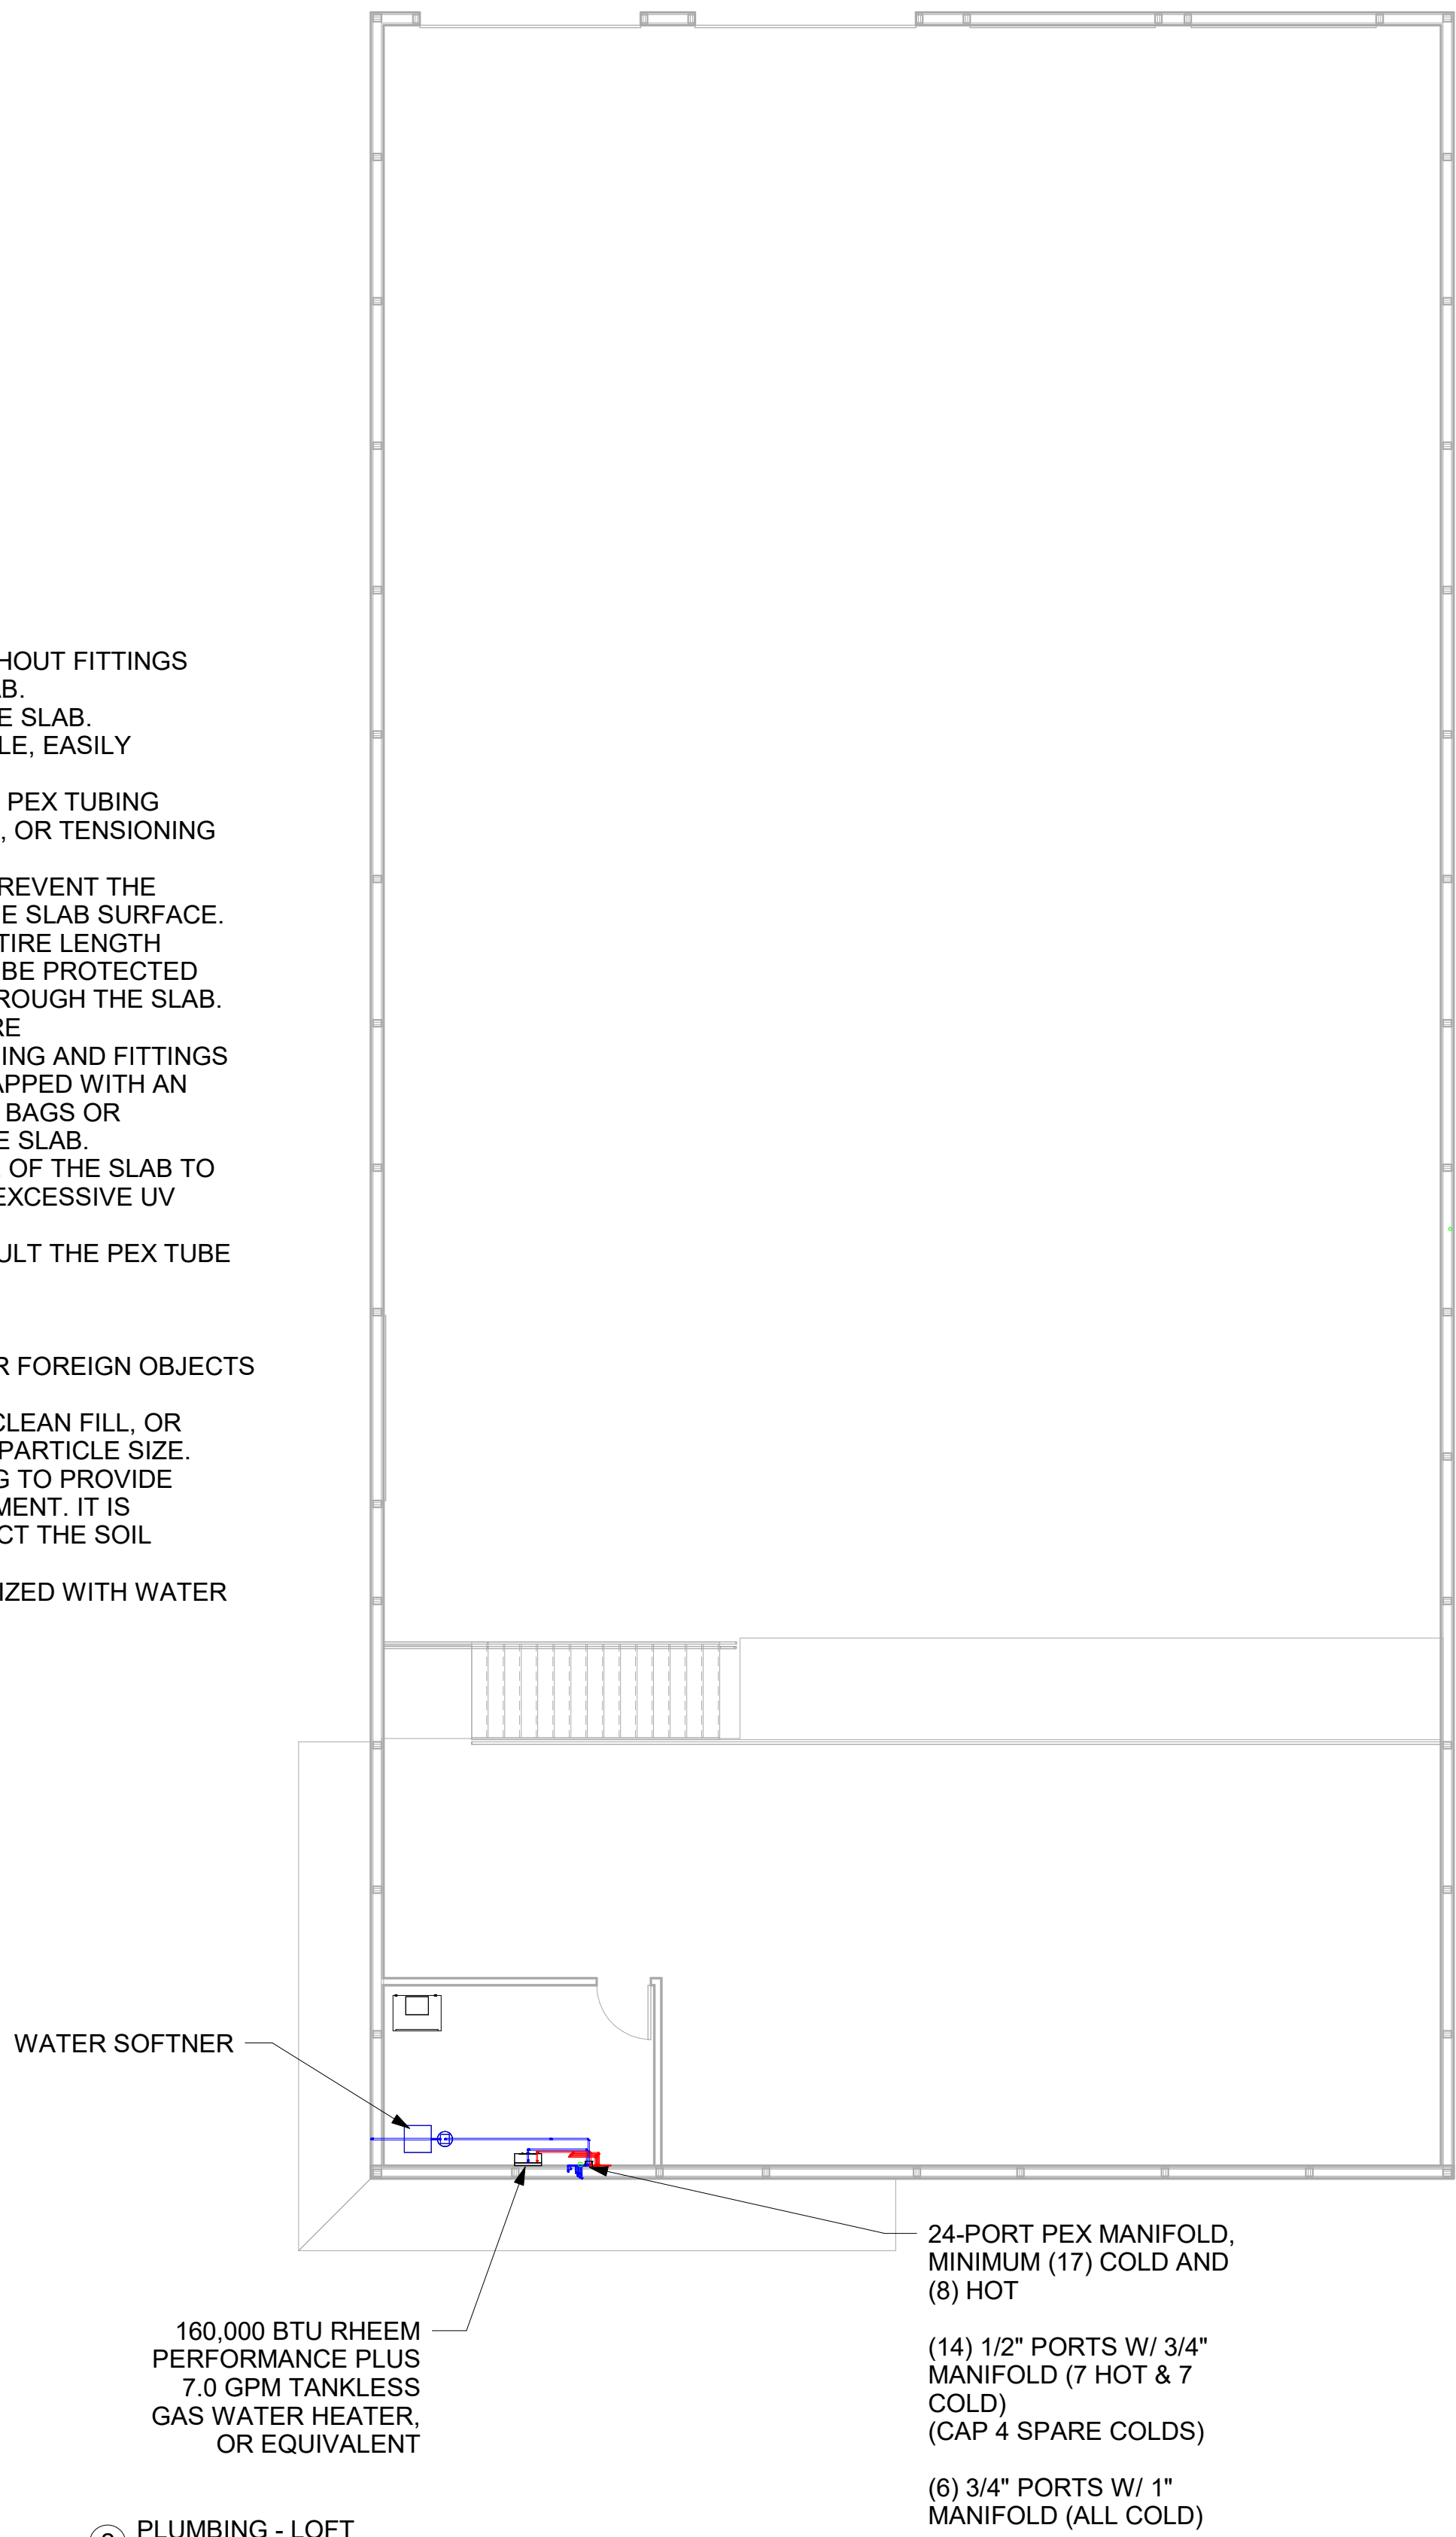

MSS Engineering, LLC
ENGINEERING, CONSULTING & DESIGN
414 W 5th St., Auburn, IN 46706
Phone: (260) 267-7414
Email: tamcdaniel@mssengineer.com
Travis A. McDaniel, PE

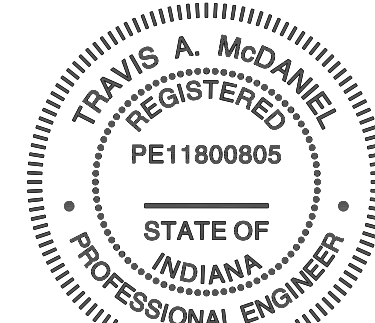

Travis A. McDaniel
05/26/23

PROJECT LOCATION:

560 S 900 E
MARION, IN 46953

PROJECT NAME:

BID SPEC &
DESIGN

DRAWING TITLE:

PLUMBING PLAN

REVISIONS:

NO.	DATE	DESCRIPTION	BY
-----	------	-------------	----

JOB NUMBER:

22.081.171

DRAWN BY: CAS

ENGINEERED BY: TAM


START DATE: 05/12/21

PROGRESS DATE: 07/13/21


CERTIFIED DATE: 05/28/23

SCALE: 1/8" = 1'-0"


PAGE NUMBER:

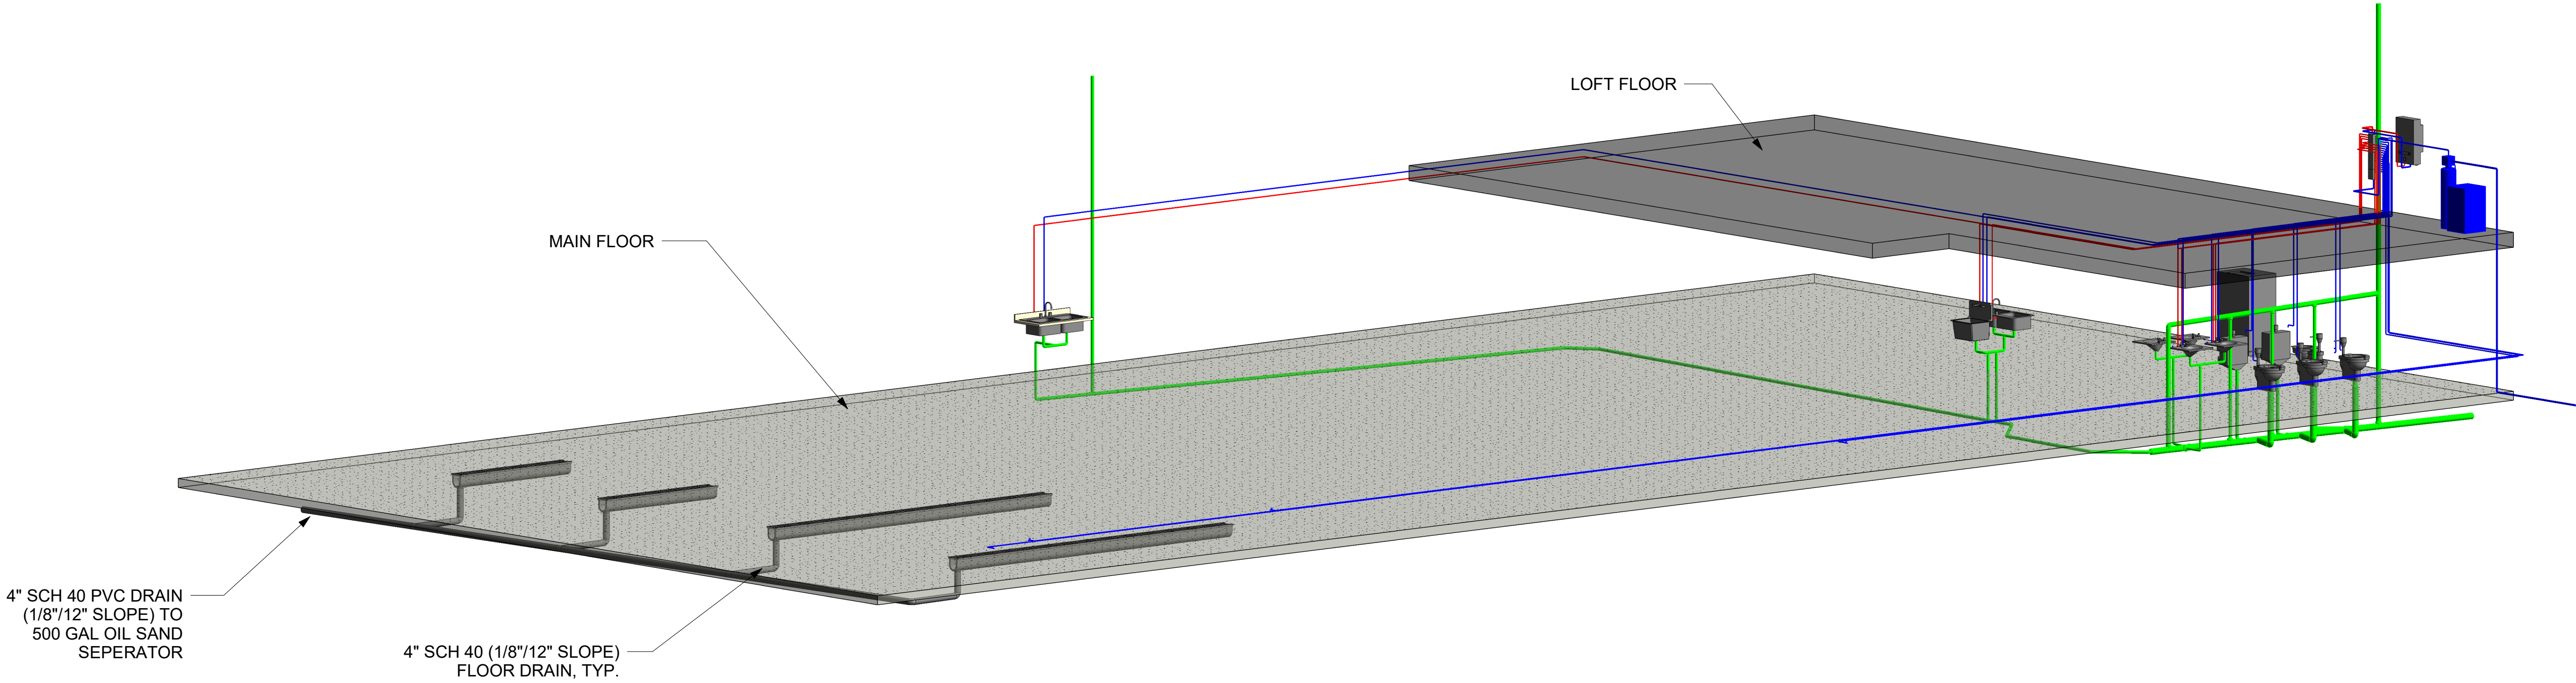


1 PLUMBING - ISOMETRIC 1

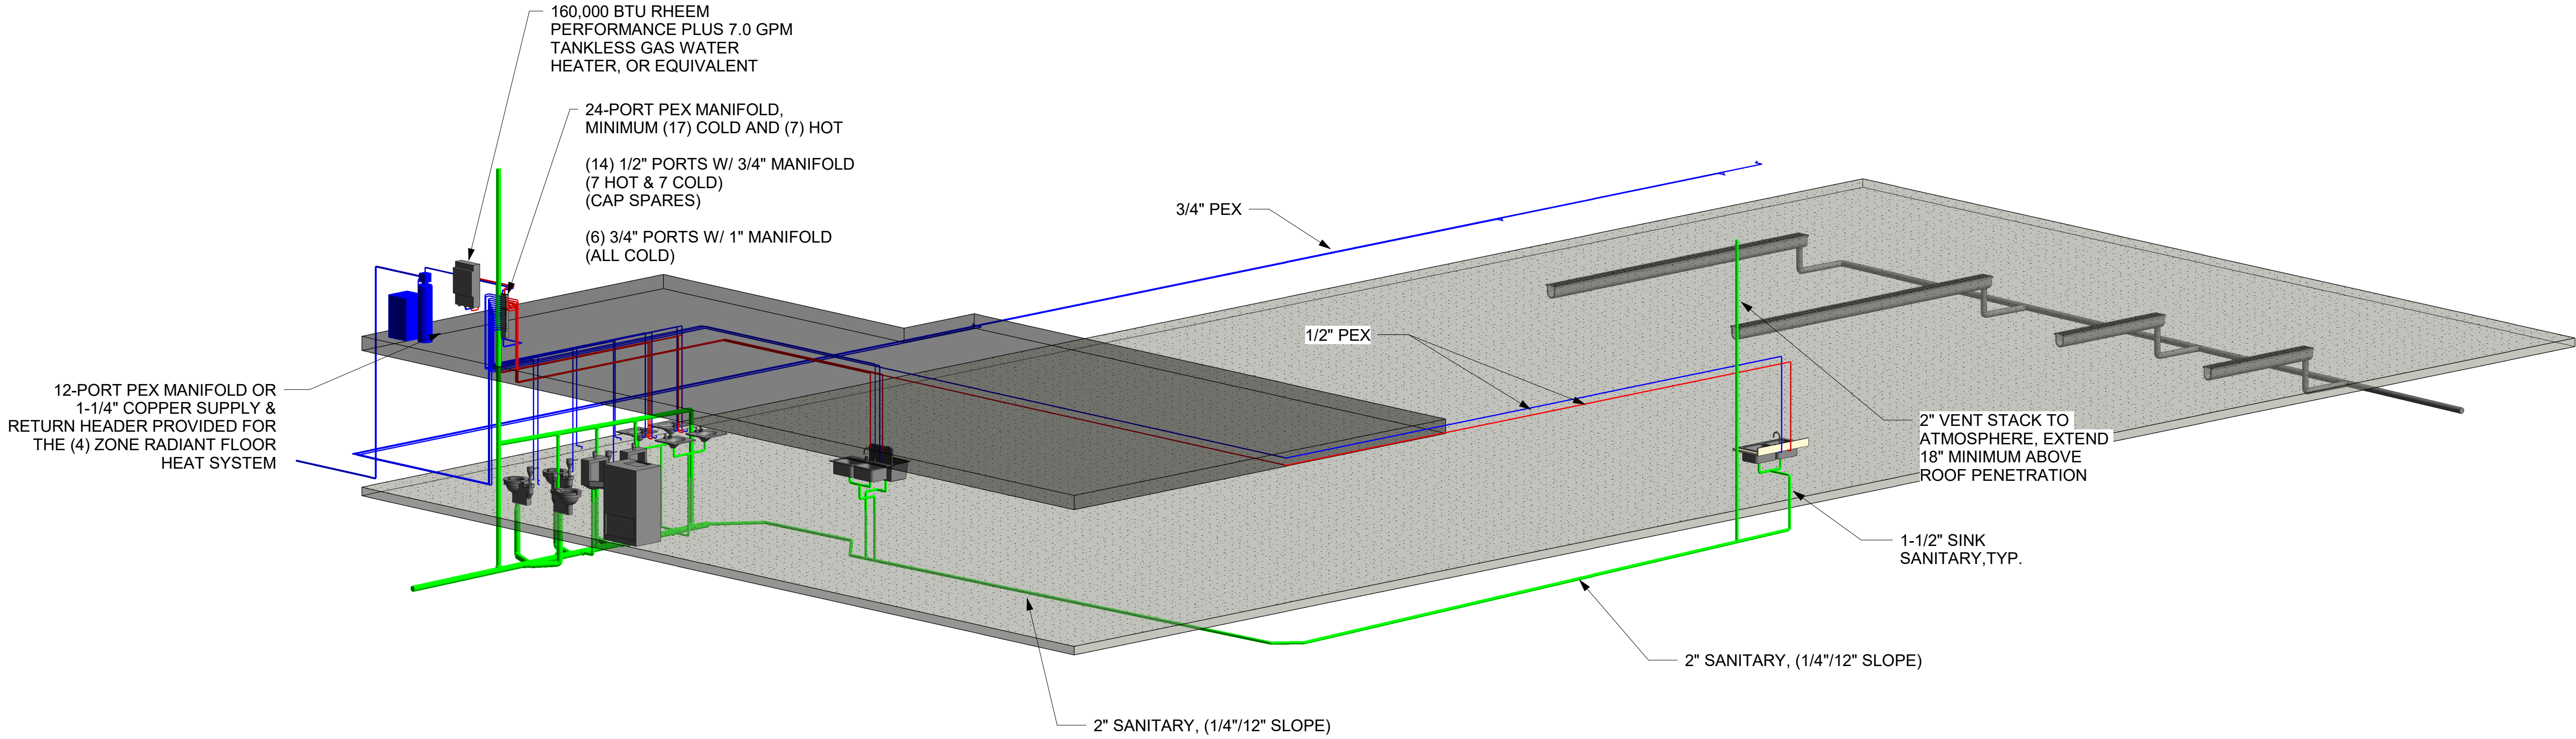

2 PLUMBING - ISOMETRIC 2

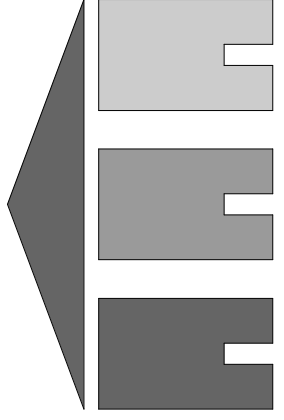

MSS Engineering, LLC
ENGINEERING, CONSULTING & DESIGN
414 W 5th St., Auburn, IN 46706
Phone: (260) 267-7414
Email: tamcdaniel@mssengineer.com
Travis A. McDaniel, PE

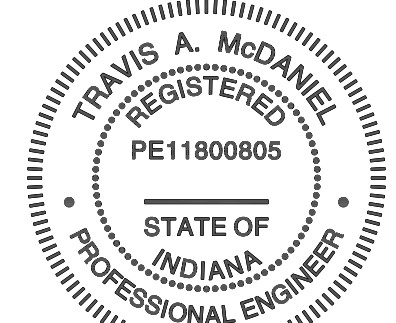

Travis A. McDaniel
05/28/23

PROJECT LOCATION:
560 S 900 E
MARION, IN 46953

PROJECT NAME:
BID SPEC &
DESIGN

DRAWING TITLE:
PLUMBING
ISOMETRICS

REVISIONS:

NO.	DATE	DESCRIPTION	BY
-----	------	-------------	----

JOB NUMBER:
22.081.171

DRAWN BY: CAS

ENGINEERED BY: TAM


START DATE: 05/12/21

PROGRESS DATE: 07/13/21


CERTIFIED DATE: 05/28/23

SCALE:

PAGE NUMBER:

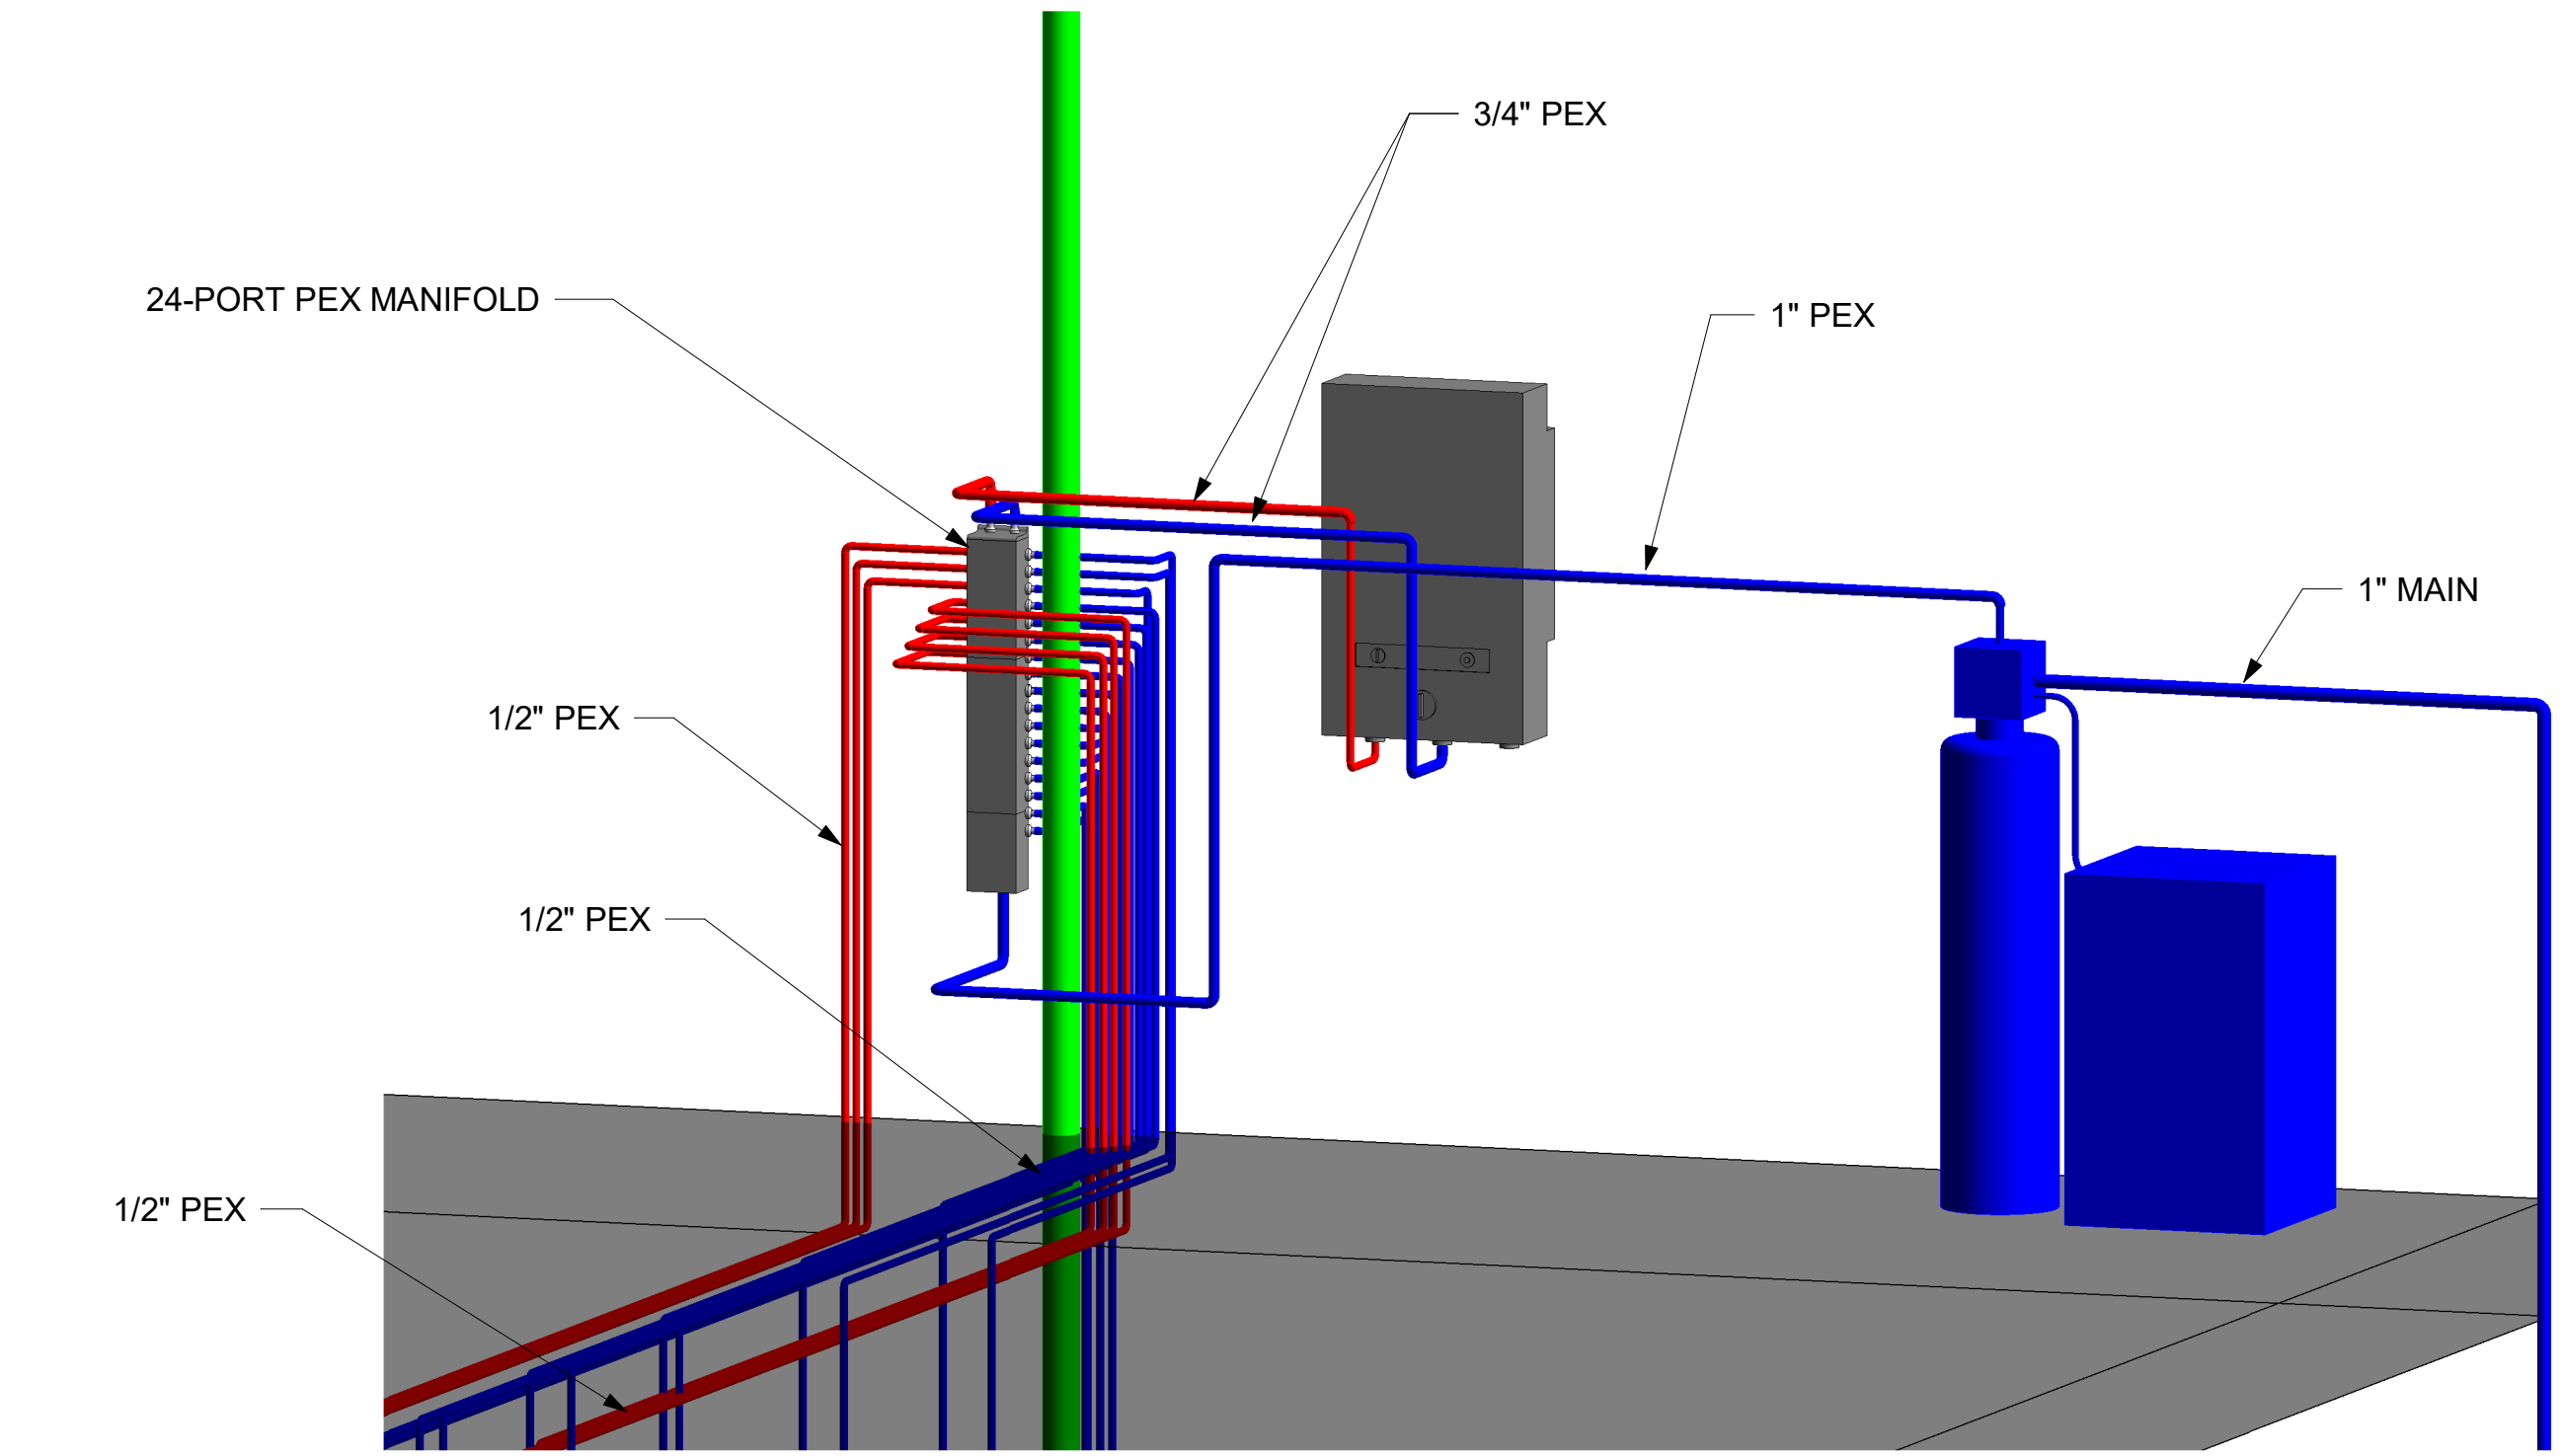


1 PLUMBING - ISOMETRIC 3

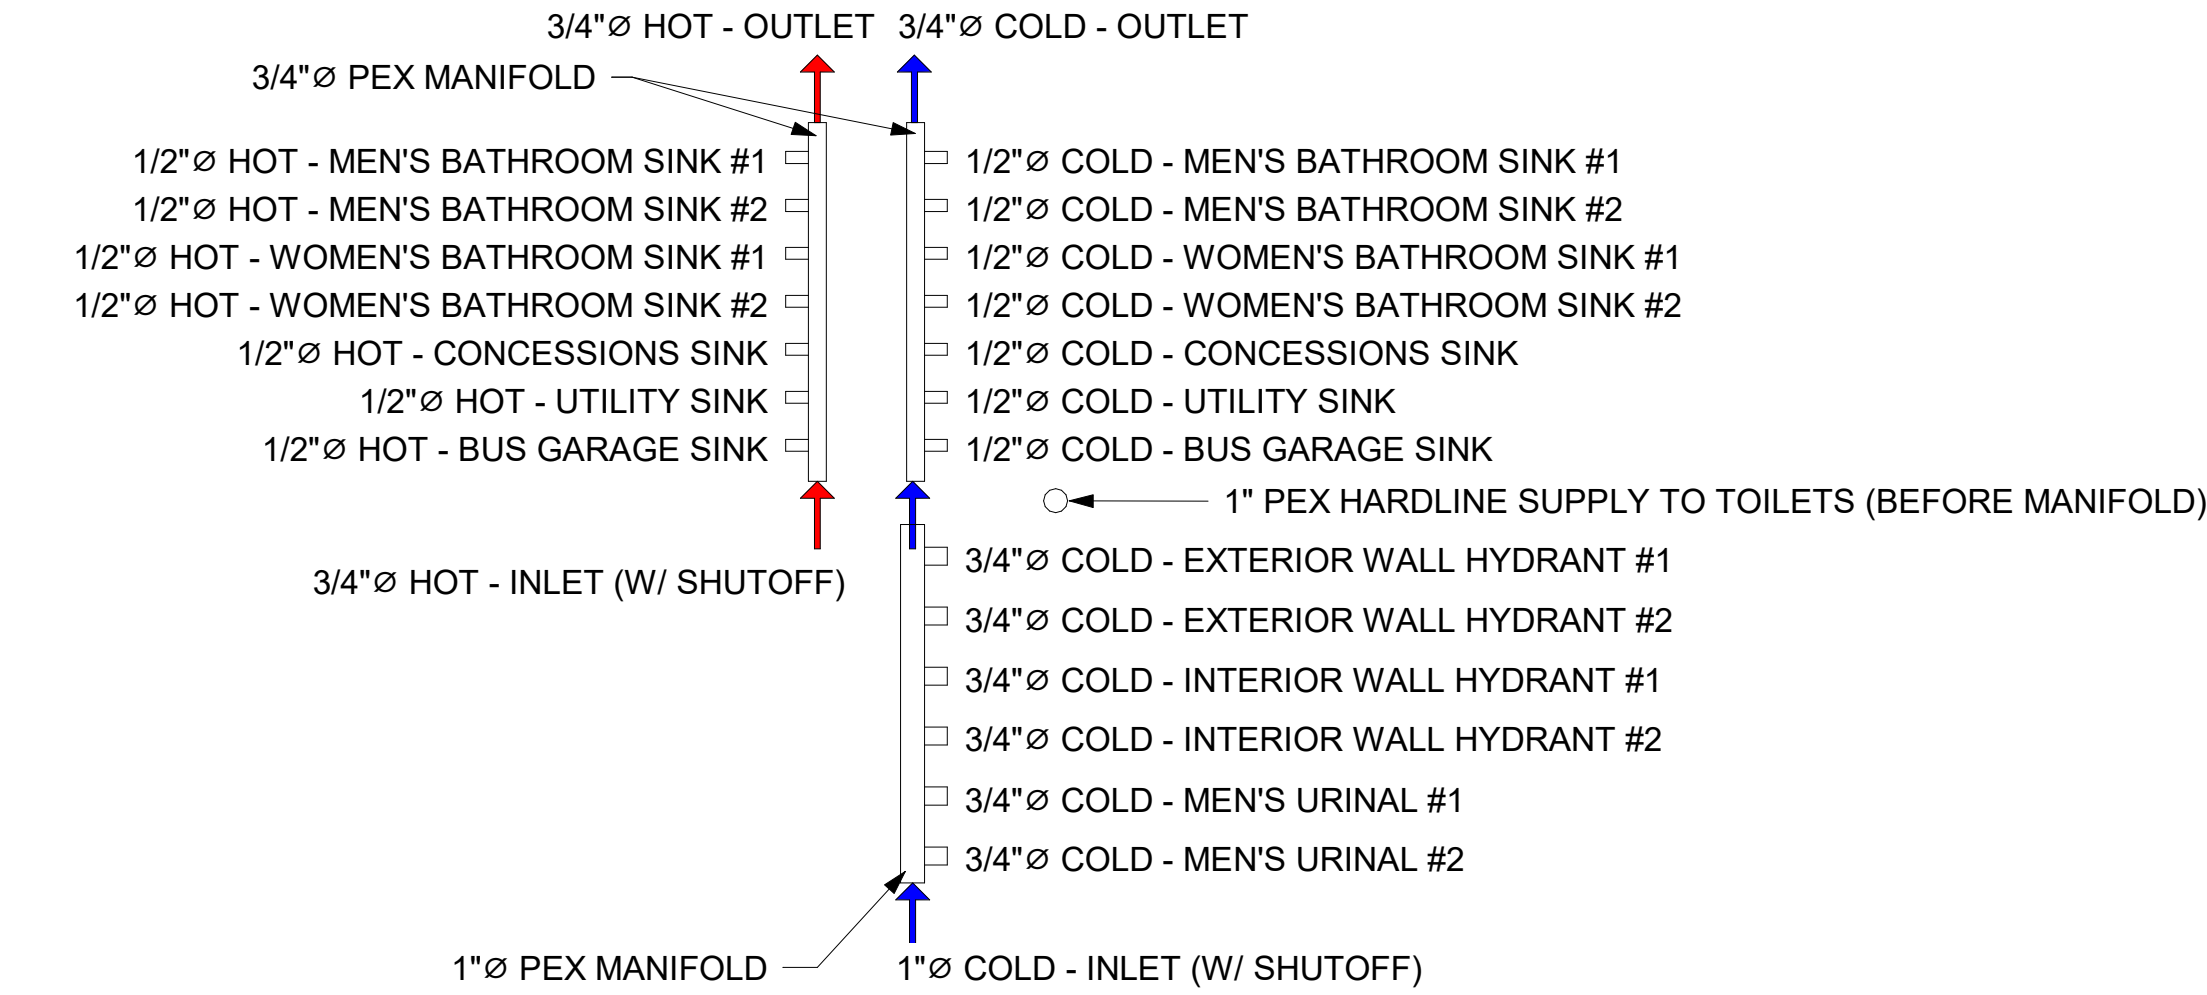


NOTE: ALL SUPPLY WATER SHALL BE SOFTENED. (ALL CONNECTIONS REQUIRE INDIVIDUAL SHUTOFF)

3 SUPPLY PEX MANIFOLD DETAIL
1 1/2" = 1'-0"

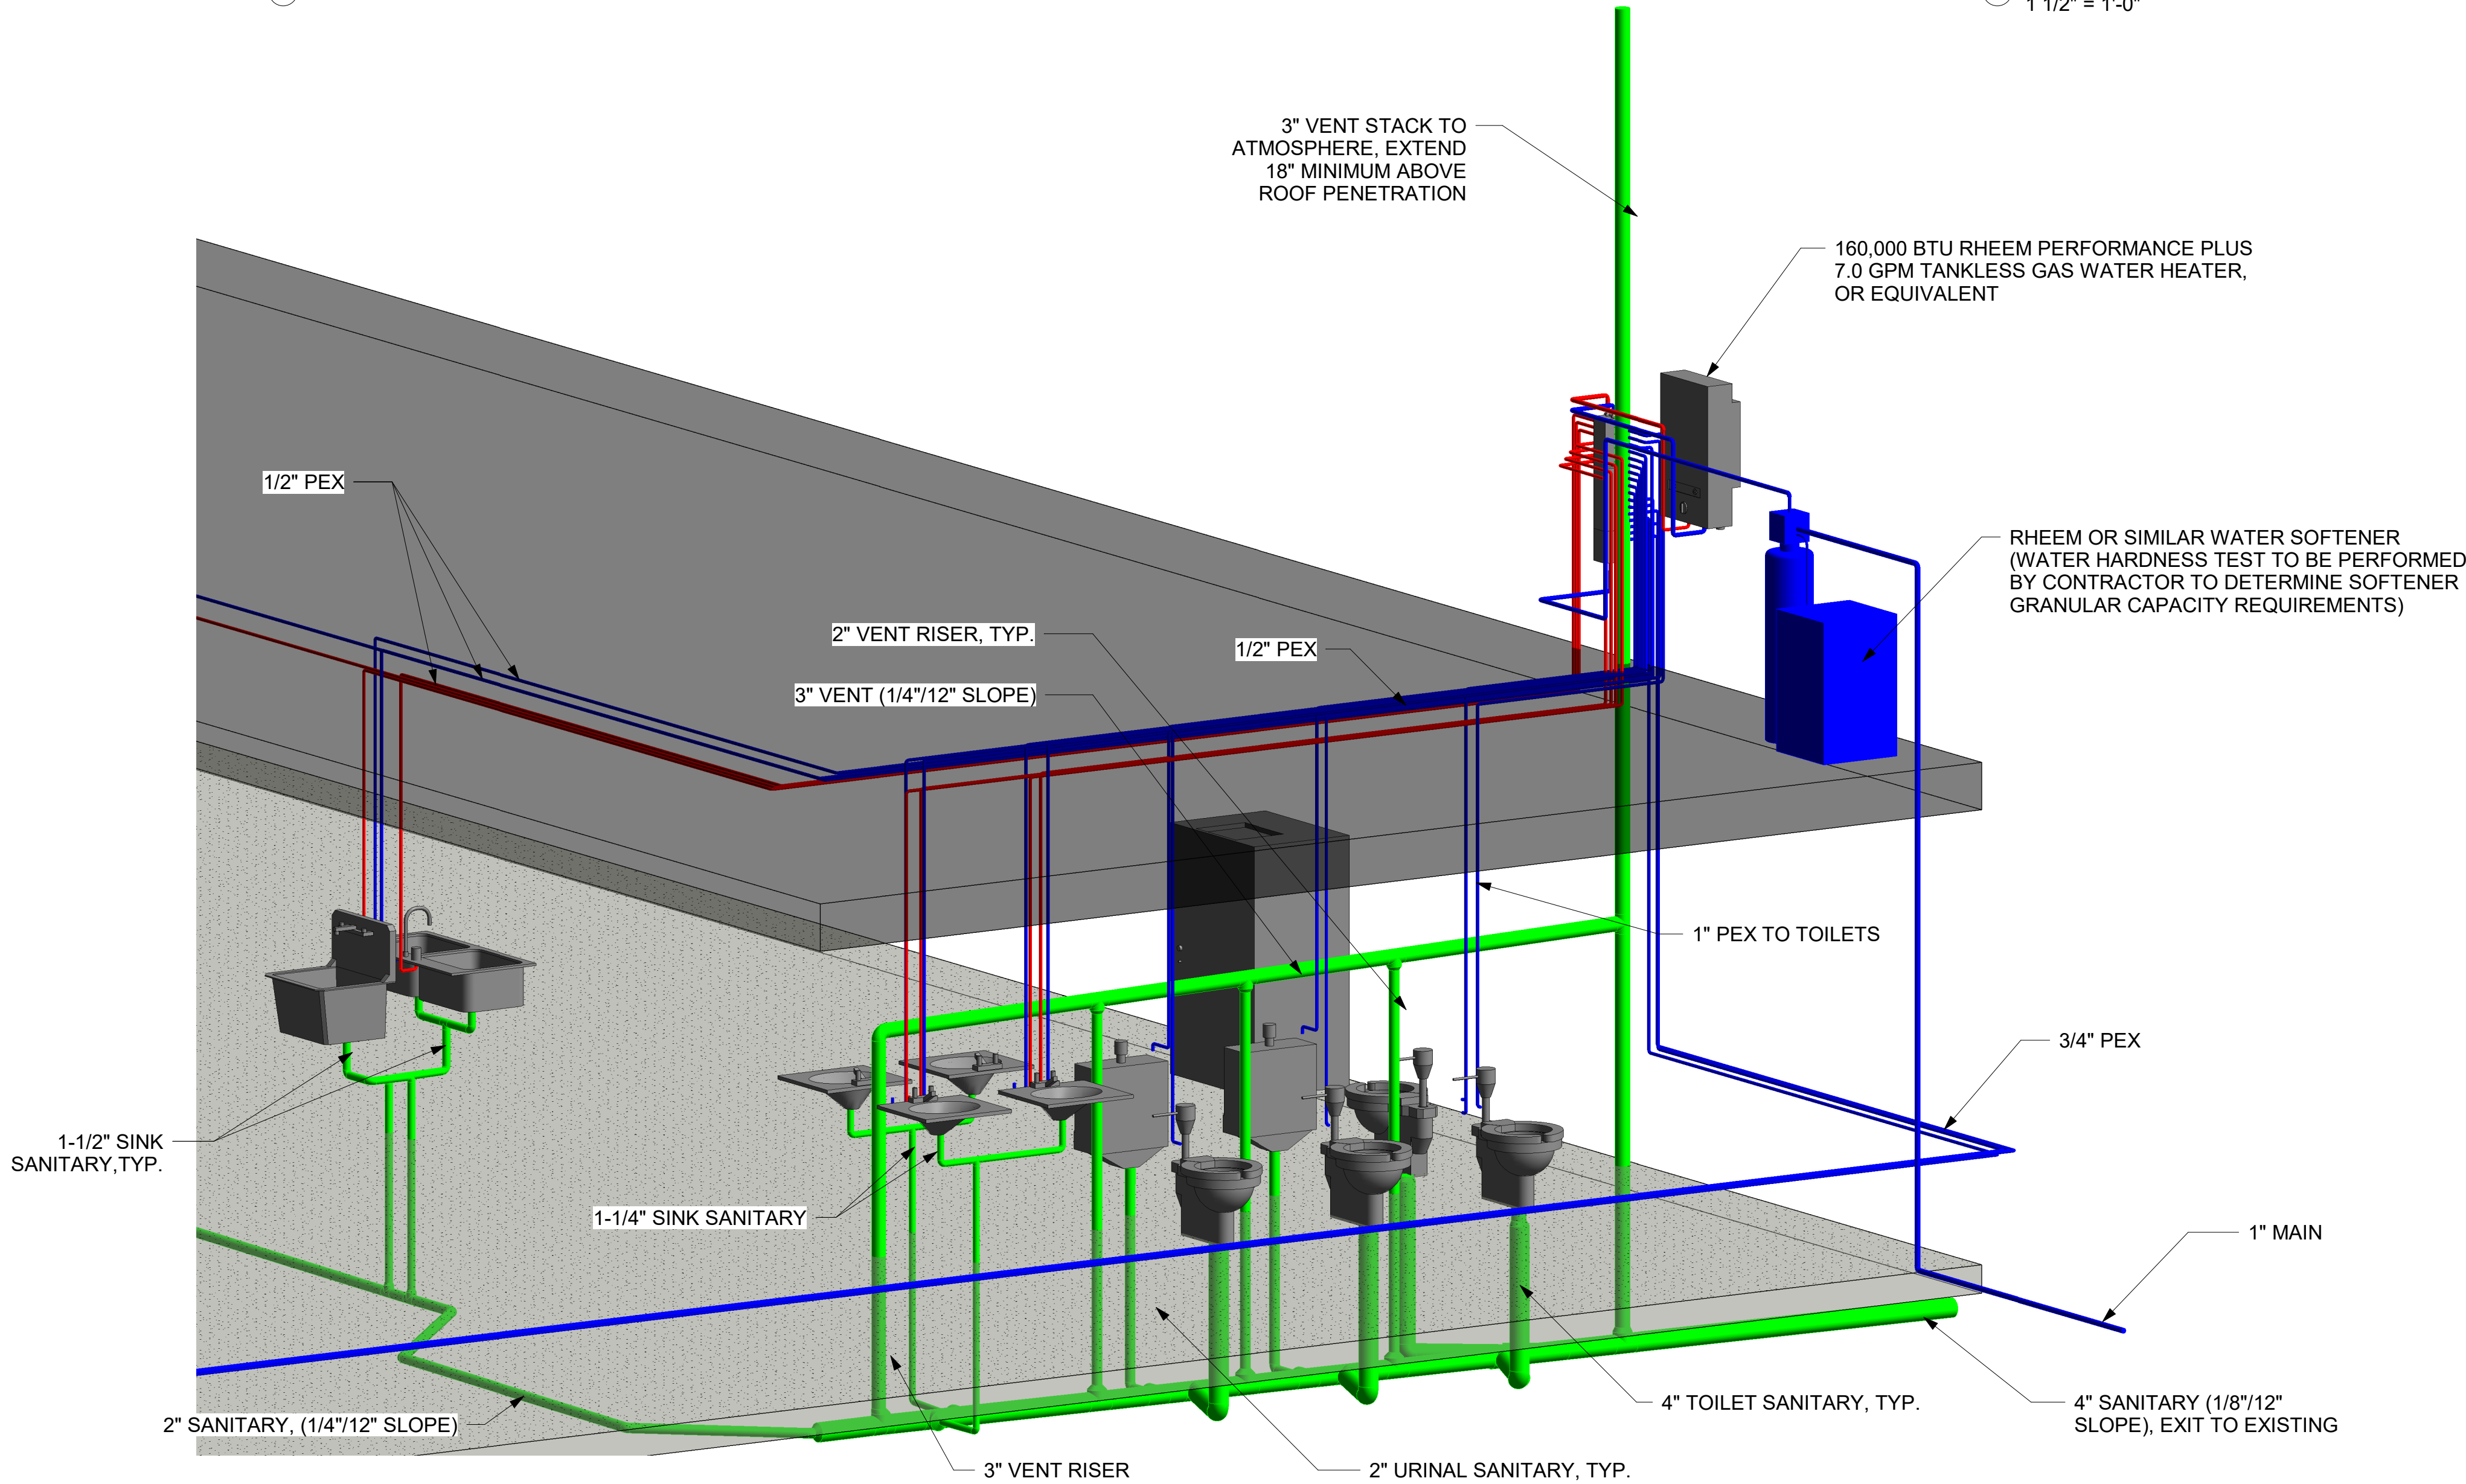

2 PLUMBING - ISOMETRIC 4

MSS Engineering, LLC
ENGINEERING, CONSULTING & DESIGN
414 W 5th St., Auburn, IN 46706
Phone: (260) 267-7414
Email: tamcdaniel@mssengineer.com
Travis A. McDaniel, PE

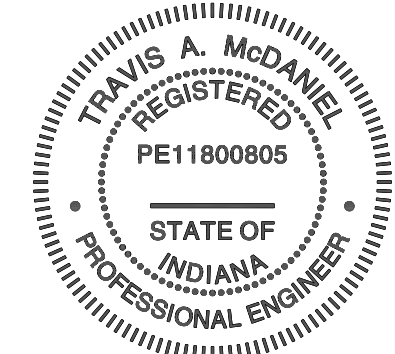

Travis A. McDaniel
05/26/23

PROJECT LOCATION:
560 S 900 E
MARION, IN 46953

PROJECT NAME:
BID SPEC &
DESIGN

DRAWING TITLE:
PLUMBING
ISOMETRIC
DETAILS

REVISIONS:

NO.	DATE	DESCRIPTION	BY
-----	------	-------------	----

JOB NUMBER:
22.081.171

DRAWN BY: CAS

ENGINEERED BY: TAM

START DATE: 05/12/21


PROGRESS DATE: 07/13/21

CERTIFIED DATE: 05/26/23


SCALE: 1 1/2" = 1'-0"

PAGE NUMBER:

PLUMBING FIXTURE SCHEDULE								
TYPE MARK	FIXTURE	DESCRIPTION	MANUFACTURER / MODEL	SAN/WASTE	VENT	COLD WATER	HOT WATER	REMARKS
L-1	LAVATORY	- BOWL - WALL HUNG, VITREOUS CHINA. - FAUCET - 4" CENTERSET FAUCET SHALL BE CAST BRASS CONSTRUCTION WITH ALL BRASS SHANK NUTS AND COUPLING NUTS. VANDAL RESISTANT WRIST-BLADE HANDLES, 0.5 GPM AERATOR, 14 TURN WASHERLESS CERAMIC DISC VALVE CARTRIDGES. - SUPPLIES AND STOPS - LOOSE KEY ANGLE STOPS, 3/8" IPS CHROME PLATED INLET, 3/8" O.D. FLEXIBLE STEEL RISERS, WALL ESCUTCHEON. - TRAP 1-1/4" x 1-1/2" CAST BRASS, CHROME PLATED, WITH ADJUSTABLE GLEANOUT PLUG, TUBING TO WALL AND ESCUTCHEON. - DRAINS: -LAVATORY DRAIN OUTLET FITTING WITH PERFORATED GRID, CHROME PLATED FINISH AND CAST BRASS BODY.	- SINK - AMERICAN STANDARD "DECORUM" MODEL 9024004EC.020 - FAUCET - AMERICAN STANDARD "MONTERREY" MODEL 6055.205 - SUPPLIES AND STOPS - WOLVERINE BRASS INC. MODEL ENCORE; T&S BRASS - TRAP - WOLVERINE BRASS INC.; T&S BRASS	1-1/4"	2"	1/2"	1/2"	MOUNT TO MEET ADA REQUIREMENTS
S-1	KITCHEN SINK	- SINK - 33"X22". DUAL MOUNT, STAINLESS STEEL, 3-HOLE, DOUBLE BOWL - FAUCET - 8" CENTERSET FAUCET SHALL BE CAST BRASS CONSTRUCTION WITH ALL BRASS SHANK NUTS AND COUPLING NUTS. VANDAL RESISTANT WRIST-BLADE HANDLES, 1.5 GPM AERATOR, 14 TURN WASHERLESS CERAMIC DISC VALVE CARTRIDGES. - SUPPLIES AND STOPS - LOOSE KEY ANGLE STOPS, 3/8" IPS CHROME PLATED INLET, 3/8" O.D. FLEXIBLE STEEL RISERS, WALL ESCUTCHEON. - TRAP 1-1/4" x 1-1/2" CAST BRASS, CHROME PLATED, WITH ADJUSTABLE GLEANOUT PLUG, TUBING TO WALL AND ESCUTCHEON. - DRAINS - X" WASTE DRAIN VALVE W/ TWIST HANDLE CHROME PLATED FINISH AND CAST BRASS BODY.	- SINK - AMERICAN STANDARD "COLONY" MODEL 22DB.6332283S.075 - FAUCET - AMERICAN STANDARD "MONTERREY" MODEL 6409170.002 - SUPPLIES AND STOPS - WOLVERINE BRASS INC. MODEL ENCORE; T&S BRASS - TRAP - WOLVERINE BRASS INC.; T&S BRASS - DRAIN - KINGSTON BRASS MODEL NO KBS1001	1-1/2"	2"	1/2"	1/2"	
S-2	UTILITY SINK	17" WALL MOUNTED SINGLE BASIN STAINLESS STEEL UTILITY SINK W/ 1.5 GPM KITCHEN FAUCET AND BASKET STRAINER	SINK - ELKAY MODEL NO. SEHS-17X	1-1/2"	2"	1/2"	1/2"	
UR-1	URINAL	- URINAL, WALL HUNG, VITREOUS CHINA, WASHDOWN FLUSH ACTION 0.125 GAL PER FLUSH, EXTENDED SIDES FOR PRIVACY. INTEGRAL FLUSH SPREADER, OPEN TRAP. WALL HANGER, 2" OUTLET, CONNECTING FLANGE WITH GASKET AND BOLTS, 3/4" TOP SPUD. - FLUSH VALVE - QUIET EXPOSED, DIAPHRAGM TYPE, CHROME PLATED FLUSHOMETER WITH POLISHED EXTERIOR. NON-HOLD-OPEN AND NO LEAK HANDLE, HIGH BACK PRESSURE VACUUM BREAKER, HEX COUPLING NUT AND ADJUSTABLE TAILPIECE, SPUD COPULING AND FLANGE FOR TOP SPUID CONNECTION. INCLUDES SWEAT SOLDER KIT, VANDAL RESISTANT STOP CAP, AND CAST WALL FLANGE.	- AMERICAN STANDARD MODEL 6590.001 0.125 GPF FLUSH VALVE - AMERICAN STANDARD MODEL 6045.013	2"	2"	3/4"	--	
WC-1	WATER CLOSET	- BOWL - VITREOUS CHINA, WHITE, ELONGATED, SIPHON JET, WALL HUNG, 1-1/2" TOP SPUD, LOW WATER CONSUMPTION (1.6 GPF/6.0 LPF). - FLUSH VALVE - QUIET EXPOSED, DIAPHRAGM TYPE, CHROME PLATED FLUSHOMETER WITH METAL OSCILLATING NON-HOLD-OPEN HANDLE, 1" I.P.S. SCREWORIVER BACK-CHECK ANGLE STOP, VANDAL RESISTANT STOP CAP, ADJUSTABLE TAILPIECE, VACUUM BREAKER FLUSH CONNECTION, SPUD COUPLING, WALL AND SPUD FLANGES FOR 1-1/2" TOP SPUD. - SEAT - WHITE HIGH IMPACT, EXTRA HEAVY SOLID PLASTIC, OPEN FRONT, ELONGATED, CHEMICAL RESISTANT. (LESS COVER), MODEL-IN SURFACE CHECK AND STAINLESS STEEL HINGE POSTS. CARRIER - BOLTED TYPE CLOSET FITTING, ADJUSTABLE SHORT FOOT WITH BEARING PLATE, SIZE AND TYPE AS REQUIRED.	- BOWL - AMERICAN STANDARD "MADERA FLOWISE" MODEL NO. 2234.001; KOHLER; CRANE; MANSFIELD; BRIGGS - FLUSH VALVE - AMERICAN STANDARD "LESS EVERCLEAN" MODEL 6047.121 LOW CONSUMPTION (1.28GPF/6.0 LPF); DELANY; SLOAN. - SEAT - BEMIS "ELONGATED OPEN FRONT" MODEL 1955CT; JAY R. SMITH; BENEKE; CENTOCO; SPERGEL. - CARRIER - JAY R. SMITH; ZURN; WADE; JOSAM	4"	2"	1"	--	HARDLINE BEFORE MANIFOLD
WC-2	WATER CLOSET	- BOWL - VITREOUS CHINA, WHITE, ELONGATED, SIPHON JET, WALL HUNG, 1-1/2" TOP SPUD, LOW WATER CONSUMPTION (1.6 GPF/6.0 LPF). - FLUSH VALVE - QUIET EXPOSED, DIAPHRAGM TYPE, CHROME PLATED FLUSHOMETER WITH METAL OSCILLATING NON-HOLD-OPEN HANDLE, 1" I.P.S. SCREWORIVER BACK-CHECK ANGLE STOP, VANDAL RESISTANT STOP CAP, ADJUSTABLE TAILPIECE, VACUUM BREAKER FLUSH CONNECTION, SPUD COUPLING, WALL AND SPUD FLANGES FOR 1-1/2" TOP SPUD. - SEAT - WHITE HIGH IMPACT, EXTRA HEAVY SOLID PLASTIC, OPEN FRONT, ELONGATED, CHEMICAL RESISTANT. (LESS COVER), MODEL-IN SURFACE CHECK AND STAINLESS STEEL HINGE POSTS. CARRIER - BOLTED TYPE CLOSET FITTING, ADJUSTABLE SHORT FOOT WITH BEARING PLATE, SIZE AND TYPE AS REQUIRED.	- BOWL - AMERICAN STANDARD "MADERA FLOWISE" MODEL NO. 2234.001; KOHLER; CRANE; MANSFIELD; BRIGGS - FLUSH VALVE - AMERICAN STANDARD "LESS EVERCLEAN" MODEL 6047.121 LOW CONSUMPTION (1.28GPF/6.0 LPF); DELANY; SLOAN. - SEAT - BEMIS "ELONGATED OPEN FRONT" MODEL 1955CT; JAY R. SMITH; BENEKE; CENTOCO; SPERGEL. - CARRIER - JAY R. SMITH; ZURN; WADE; JOSAM	4"	2"	1"	--	MOUNT TO MEET ADA REQUIREMENTS HARDLINE BEFORE MANIFOLD
HB-1	HOSE BIB	CONCEALED BOX TYPE FREEZELESS WALL HYDRANT, AUTOMATIC DRAINING, ANTI-SIPHON VACUUM BREAKER WITH 3/4" FNPT, LOOSE TEE KEY, CHROME PLATED EXTERIOR FINISH.	WATTS MODEL HY 430	--	--	3/4"	--	MOUNT 24" ABOVE GRADE
TD-1	TRENCH DRAIN	4" PRECAST TRENCH DRAIN, FIBER REINFORCED POLYMER TRENCH DRAIN MATERIAL, STEEL PER ASTM A-36 FRAME MATERIAL, HOT DIP GALVANIZED FRAME COATING, 0.5% SLOPE (TYP.)	DURA TRENCH MODEL NO.DTPF4-HDGS08ZSA	4"	--	--	--	
OT-1	OIL SAND SEPERATOR	3" PLAIN END VENTS, MAX FLOW RATE 314 GPM, LIQUID CAPACITY 560 GALLONS, OIL CAPACITY 285 GALLONS, SOLIDS/SEDIMENT CAPACITY 162 GALLONS, UNIT WEIGHT W/ STANDARD COVERS 1000 LBS, MAXIMUM OPERATING TEMPERATURE 140°F	STRIEM OIL TANKER MODEL OT-500	4"	--	--	--	

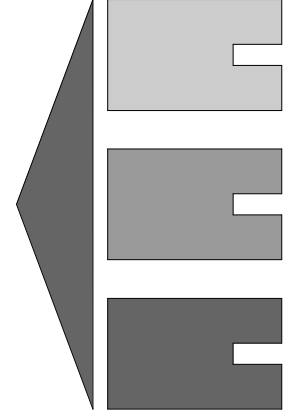

MSS Engineering, LLC
ENGINEERING, CONSULTING & DESIGN
414 W 5th St., Auburn, IN 46706
Phone: (260) 267-7414
Email: tamcdaniel@mssengineer.com
Travis A. McDaniel, PE

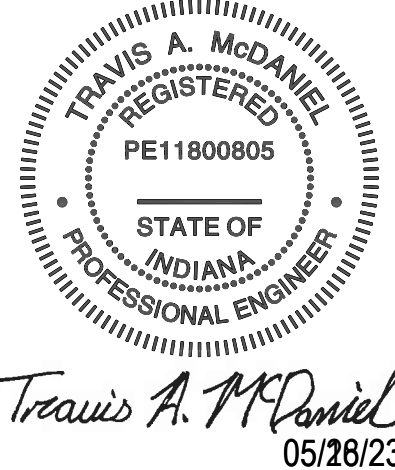

PROJECT LOCATION:
560 S 900 E
MARION, IN 46953

PROJECT NAME:
BID SPEC &
DESIGN

DRAWING TITLE:
PLUMBING
FIXTURE
SCHEDULE

REVISIONS:

NO.	DATE	DESCRIPTION	BY
-----	------	-------------	----

JOB NUMBER:
22.081.171

DRAWN BY: CAS

ENGINEERED BY: TAM

START DATE: 05/12/21

PROGRESS DATE: 07/13/21

CERTIFIED DATE: 05/26/23

SCALE:

PAGE NUMBER:

